


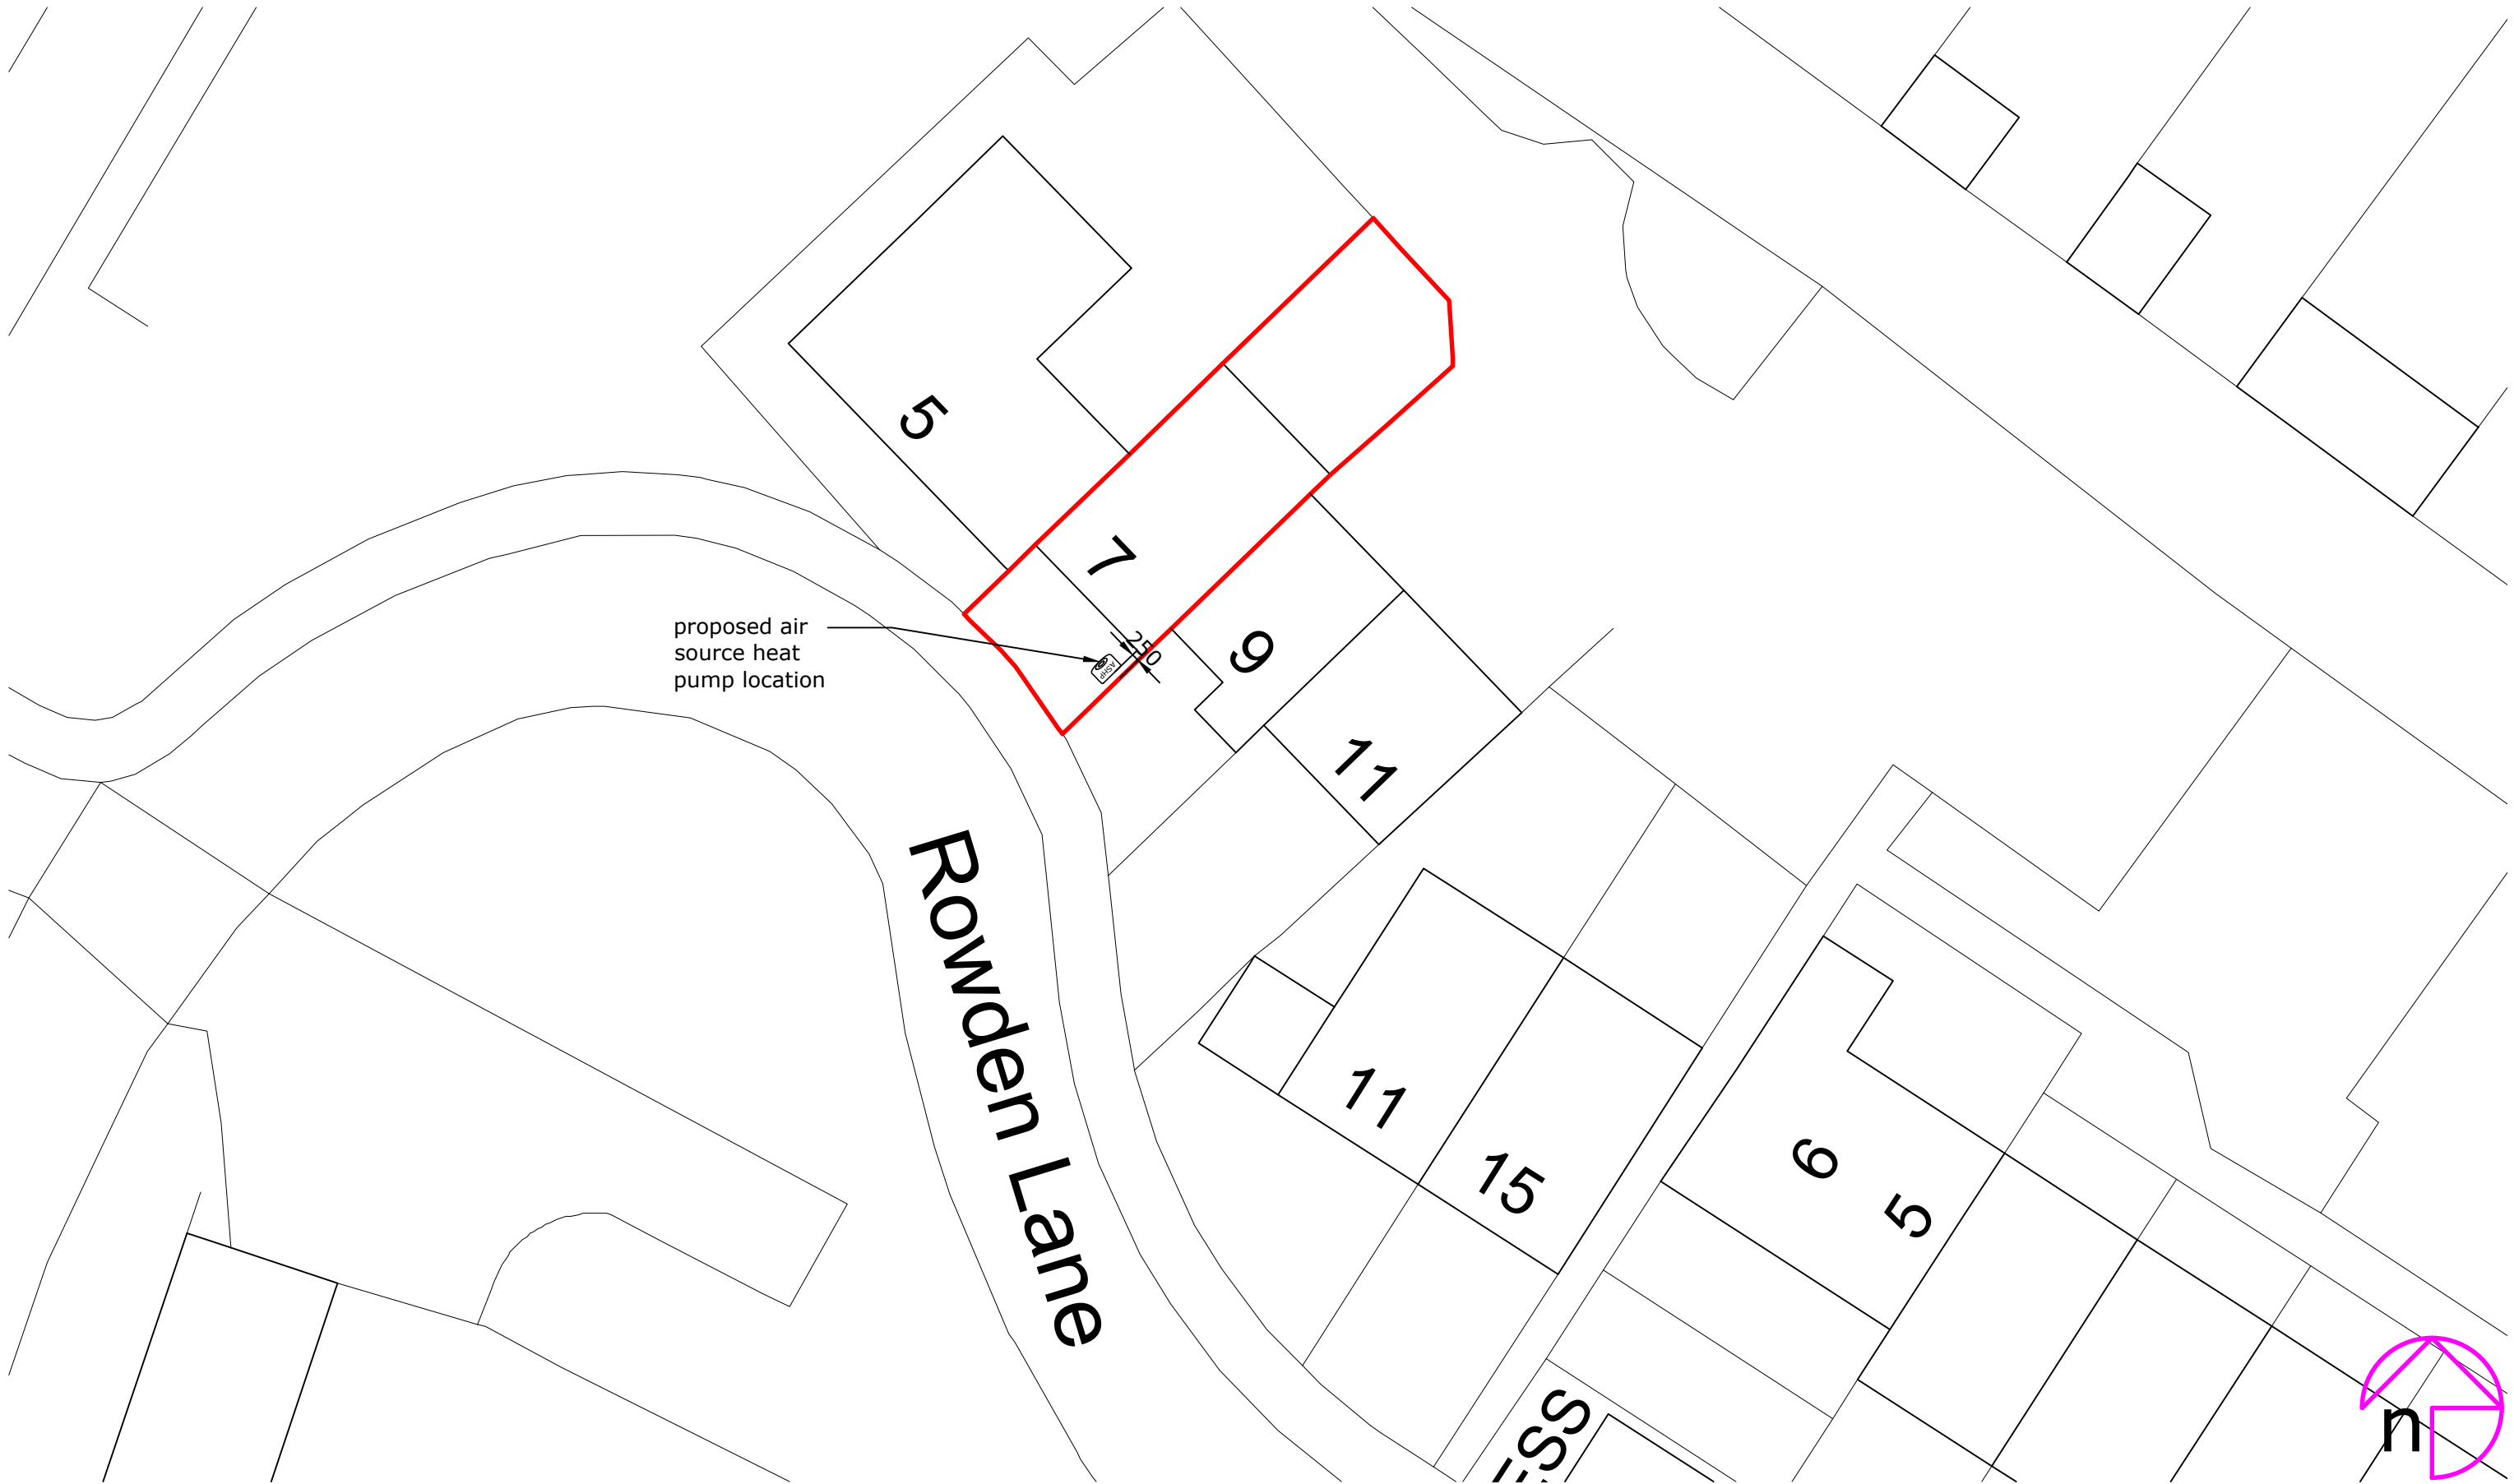

1:200 0 2 4 6 8 10 12 14 16 18 20 30 40m

Rev:	Description:	By:	Date:
------	--------------	-----	-------



octopusenergy

services

Client/Project: Yuk Ching Li 7 Rowden Lane, Chippenham Wiltshire, SN15 2FF	Project status: PLANNING (installation of air source heat pump) Drawing title: Site plan as proposed
---	---

Scale: 1:200	Paper Size: A3	Drawn: O Sage	Checked: Dinho Chan
Project ID: J-603E7ABB	Drawing No: 02	Revision:	Date: 20.08.25