


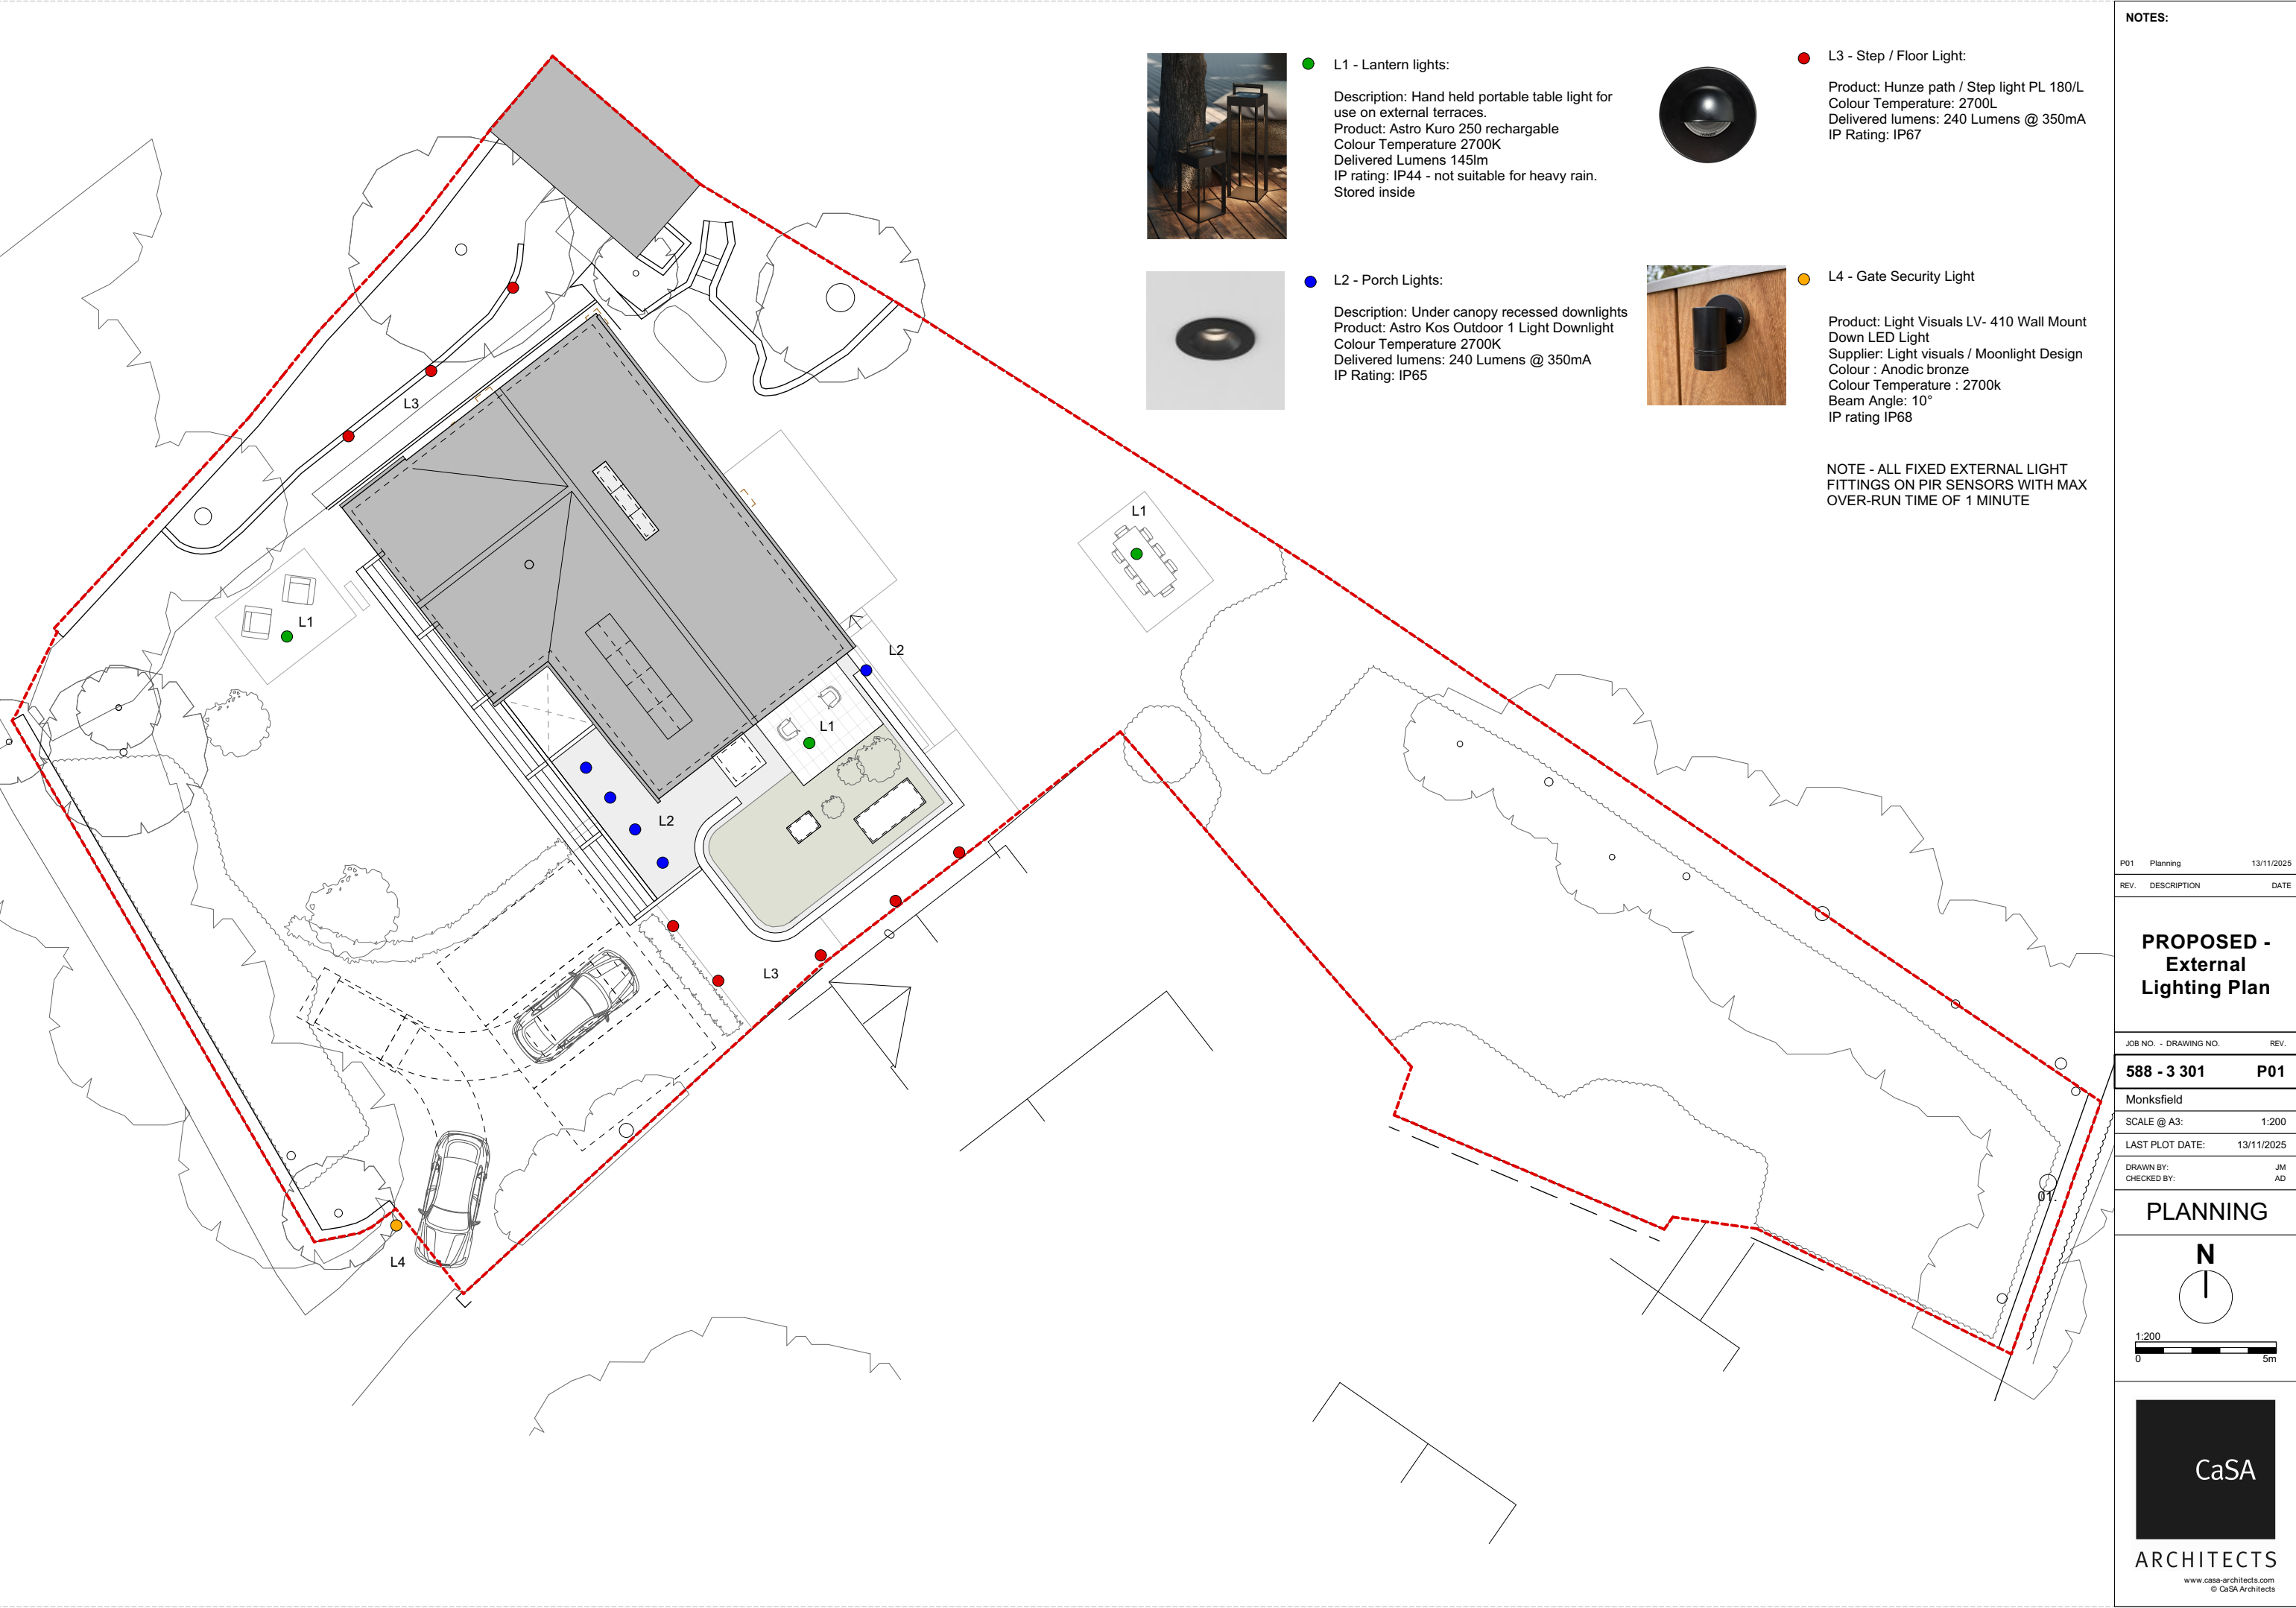

L1 - Lantern lights:
Description: Hand held portable table light for use on external terraces.
Product: Astro Kuro 250 rechargeable
Colour Temperature 2700K
Delivered Lumens 145lm
IP rating: IP44 - not suitable for heavy rain.
Stored inside



L2 - Porch Lights:
Description: Under canopy recessed downlights
Product: Astro Kos Outdoor 1 Light Downlight
Colour Temperature 2700K
Delivered lumens: 240 Lumens @ 350mA
IP Rating: IP65



L3 - Step / Floor Light:
Product: Hunze path / Step light PL 180/L
Colour Temperature: 2700L
Delivered lumens: 240 Lumens @ 350mA
IP Rating: IP67



L4 - Gate Security Light
Product: Light Visuals LV- 410 Wall Mount Down LED Light
Supplier: Light visuals / Moonlight Design
Colour : Anodic bronze
Colour Temperature : 2700k
Beam Angle: 10°
IP rating IP68

NOTE - ALL FIXED EXTERNAL LIGHT FITTINGS ON PIR SENSORS WITH MAX OVER-RUN TIME OF 1 MINUTE

NOTES:

REV.	DESCRIPTION	DATE
P01	Planning	13/11/2025

PROPOSED - External Lighting Plan

JOB NO. - DRAWING NO.	REV.
588 - 3 301	P01

Monksfield

SCALE @ A3:	1:200
LAST PLOT DATE:	13/11/2025
DRAWN BY:	JM
CHECKED BY:	AD

PLANNING

N

1:200
0 5m

CaSA

ARCHITECTS
www.casa-architects.com
© CaSA Architects