


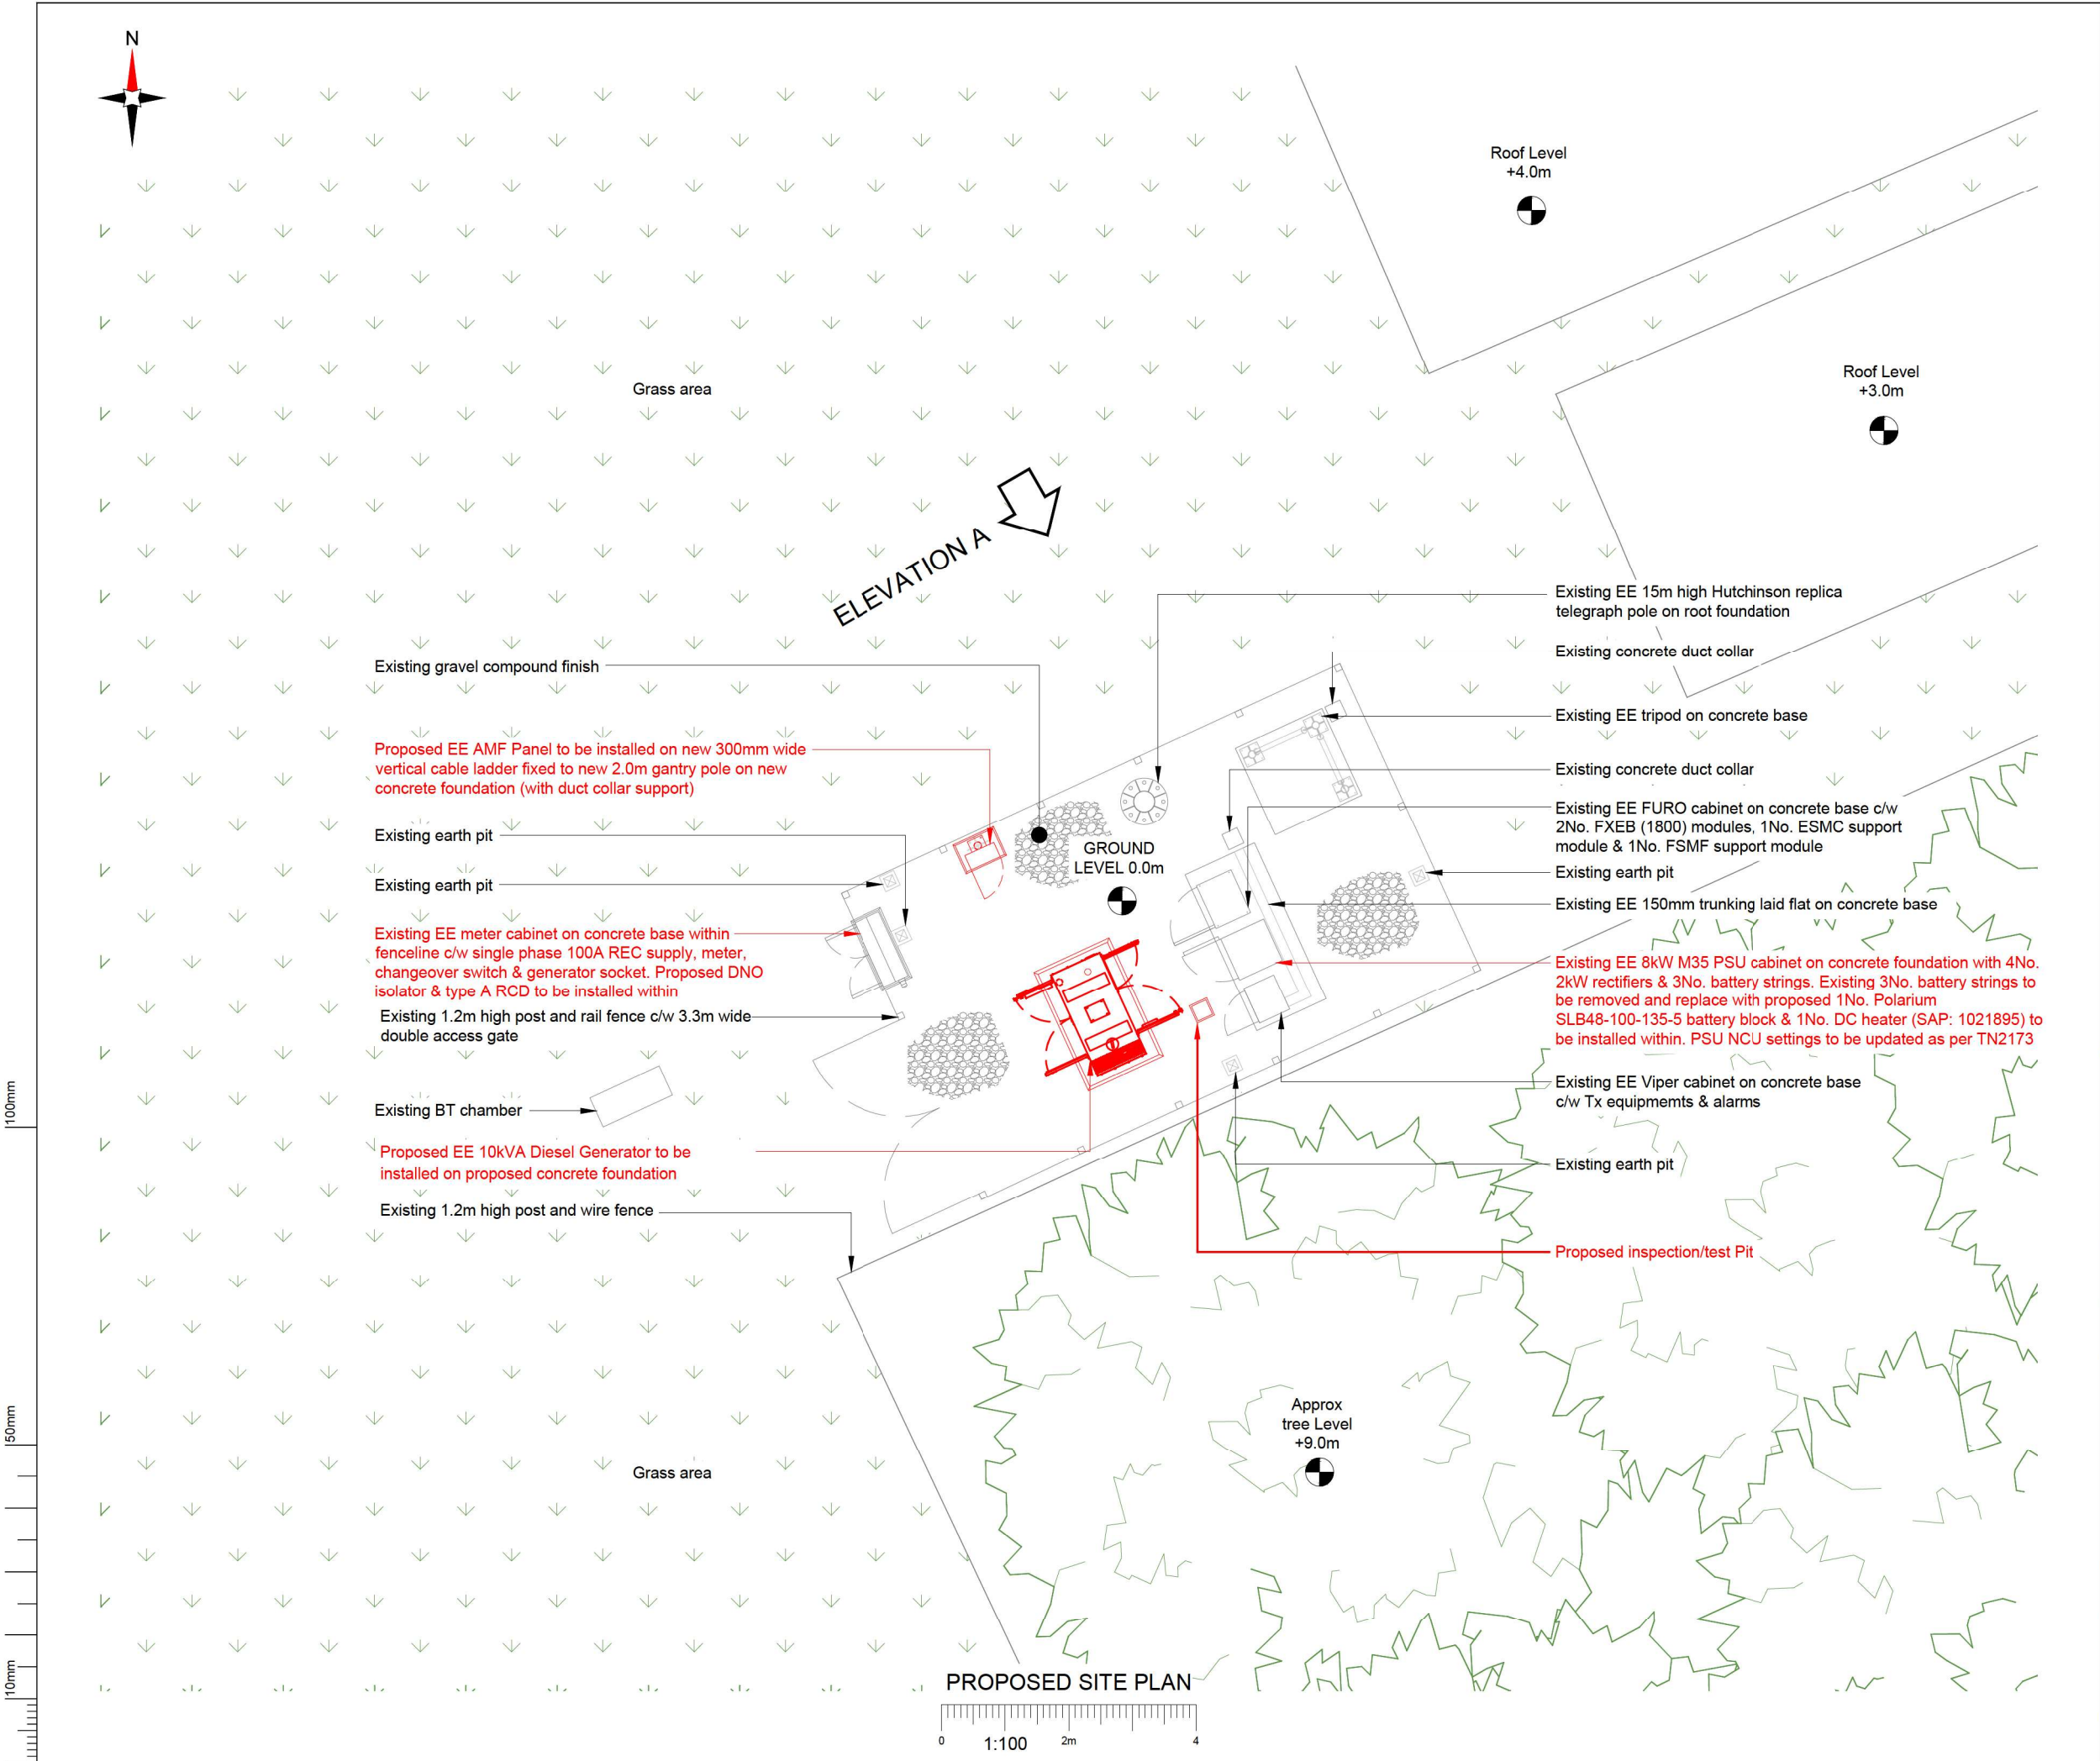

- NOTES:
- ALL DIMENSIONS IN MM UNLESS OTHERWISE NOTED.

Note:-
All DC cables on tray to be installed in Ronbar galvanised steel PVC flexible conduit

Note:
Generator changeover switch should only be operated in the event of a fixed generator failure, when a tow to site generator is being used as back up. Warning notice to be added to changeover switch, please see drawing 800 for details

Master:		Project:		Purpose of Issue:		Issue:	
DDD		Power Area Power Resilience		Detailed Design		A2	
Date:		27.10.2025		Revision / Upgrade Description:			
Drawn:		H.Cameron		AMF Panel updated to Single Phase - Lightning protection layout			
Checked:		H.Cameron		corrected - Electrical Schematic updated			
Approved:		J.Alexander					
Master:		Project:		Purpose of Issue:		Issue:	
DDD		Power Area Power Resilience		Detailed Design		A1	
Date:		08.10.2025		Revision / Upgrade Description:			
Drawn:		SUC		Detailed Design			
Checked:		H.Cameron					
Approved:		J.Alexander					



Everything Everywhere

One Braham Street
London
E1 8EE

Tel: 020 7356 5000

Design Consultant:



M-GROUP TELECOM
WEST LODGE
STATION APPROACH
WEST BYFLEET
SURREY
KT14 6NG

TEL : 01932 411011
FAX : 01932 411012

Site Name: RUSHMORE FARM

Site ID: 1482074

Address: LAND AT RUSHMORE FARM
TOLLARD ROYAL
SALISBURY
WILTSHIRE
SP5 5PT

Title: 150 PROPOSED SITE PLAN

Project: PRIMARY AREA POWER RESILIENCE

Purpose of Issue: DETAILED DESIGN

EE Cell ID:	MBNL Cell ID:	H3G Cell ID:
75260	SSB078	H3GNA

File name: SSB078_75260_H3GNA_EE_PR_DDD_A2