



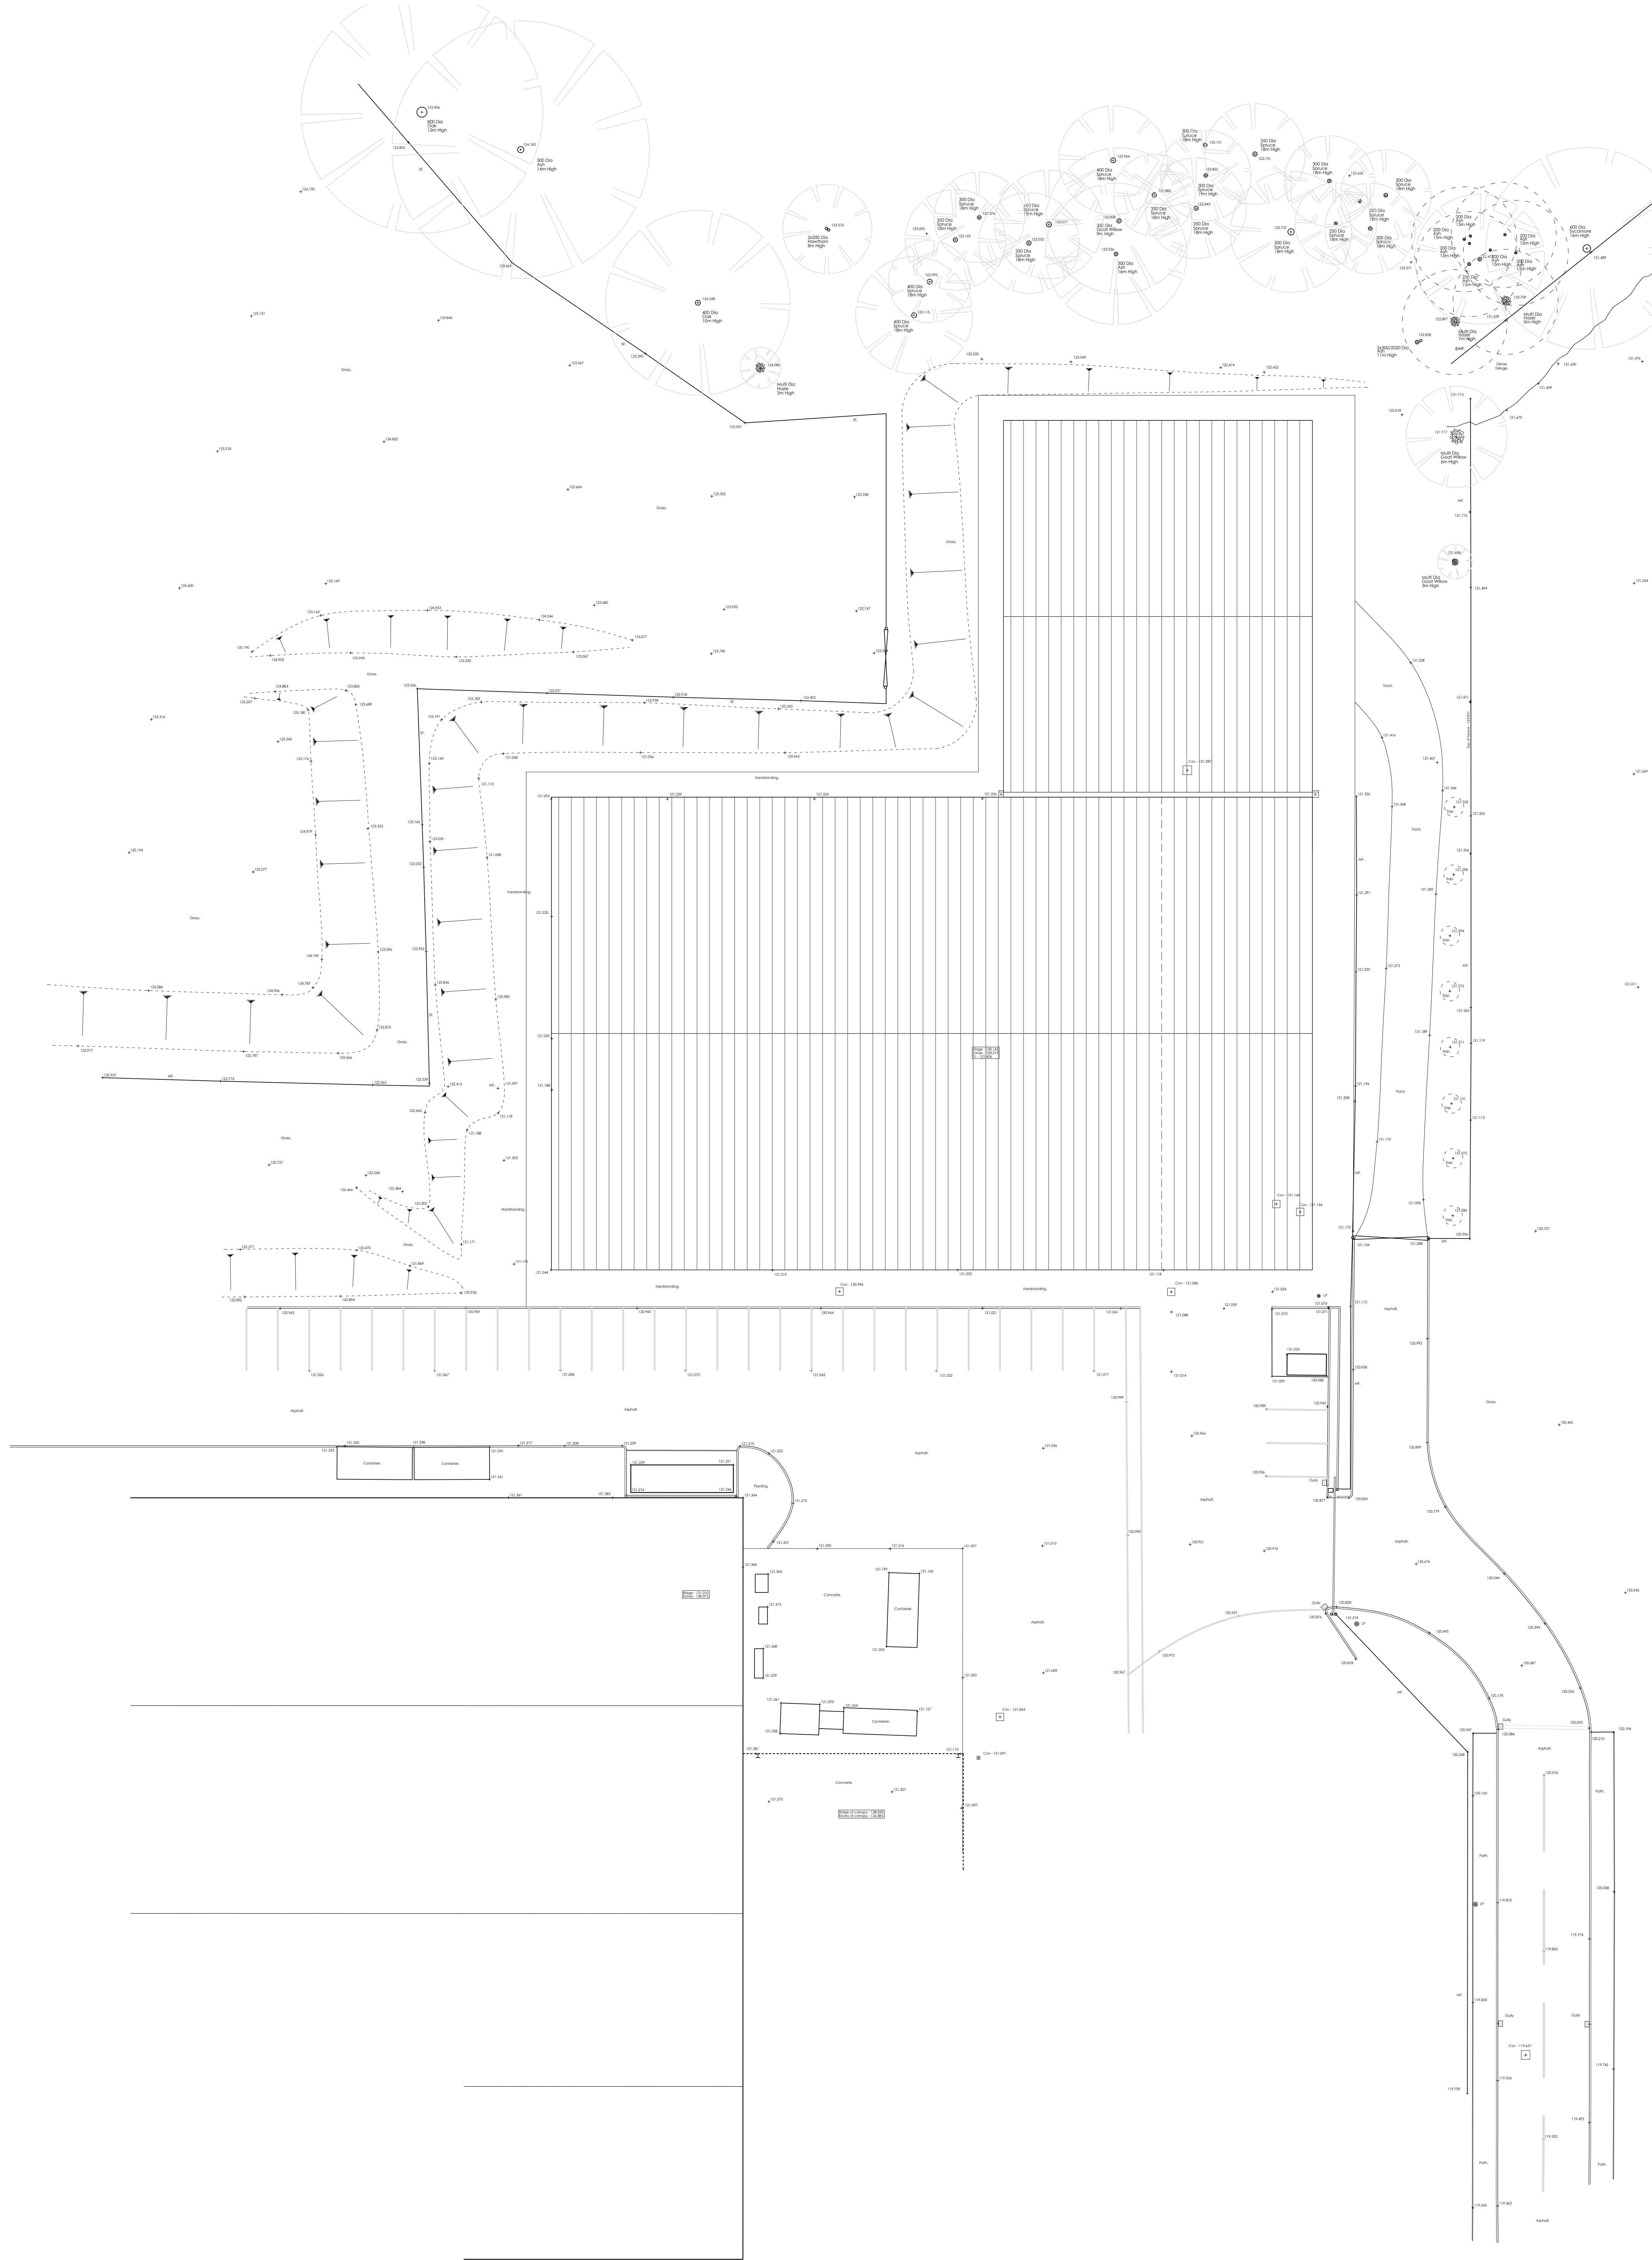

KEY

- Contour lines
- Roof overhang
- FW drainage run
- Overhead wires BT
- Overhead wires Electricity
- Tree (pole and approximate canopy)
- Tree off site - indicative canopy
- Inspection Chamber cover and invert level

TEXT Key			
	At Valve	IC	Inspection Chamber
	Bollard	INV	Invert Level
	BT Pole	KO	Kerb Outlet
	BT Cover	LP	Lamp Post
WF	Barbed Wire Fence	WM	Water Meter
	Window/Door Cill	FH	Fire Hydrant
TV	Cable Television Cover	OM	Bench Mark
	Cabinet	PB	Post Box
	Chain Link Fence	PPF	Post Panel Fence
OV	Cover Level	PRF	Post Rail Fence
	Electric Power Pole	RS	Road Sign
	Eaves Level (u/s fascia)	RWP	Rain Water Pipe
	Fire Hydrant	SVP	Sol Vent Pipe
	Floor Level	SF	Stock Fence
	Fence Post	TL	Traffic Light
	Gully	UTL	Unable To Lift
	Gate Post	WM	Water Meter
	Gas Valve	WST	Water Stop Tap
	Window/Door Head	WO	Wash Out
Gates			

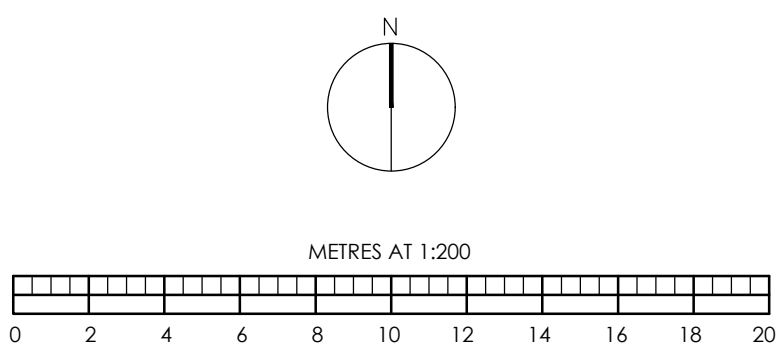

BRIMBLE LEA
Chartered Planning Consultants & Architects
Unit 3, Kingsmead Business Park,
Gillingham, Dorset, SP8 5FB
T (01747) 823232 www.brimblelea.com

PROJECT Hillbush,
Norwood Park,
Castle Street,
Mere,
BA12 6FE.

DRAWING Proposed Site Plan

SCALE 1:200 @ A0	DRAWING ORIGINATOR DWR	DRAWING No. 25103 - 5	REVISION A
DATE 18.11.2025			