



NOTES

1. REFER TO DRAWING NO. 99982/M001 FOR SYMBOLS.
2. THIS DRAWING IS TO BE READ IN CONJUNCTION WITH THE SPECIFICATION AND ALL OTHER ASSOCIATED DOCUMENTS.
3. THE CONTRACTOR SHALL BE RESPONSIBLE FOR SITE MEASURING ALL REQUIRED MATERIALS PRIOR TO ORDERING.
4. SETTING OUT OF ALL EQUIPMENT TO BE CONFIRMED ON CONTRACTORS WORKING DRAWINGS FOLLOWING AGREEMENT WITH ARCHITECT. REFER TO ARCHITECT'S DRAWINGS FOR INDICATIVE SETTING OUT.

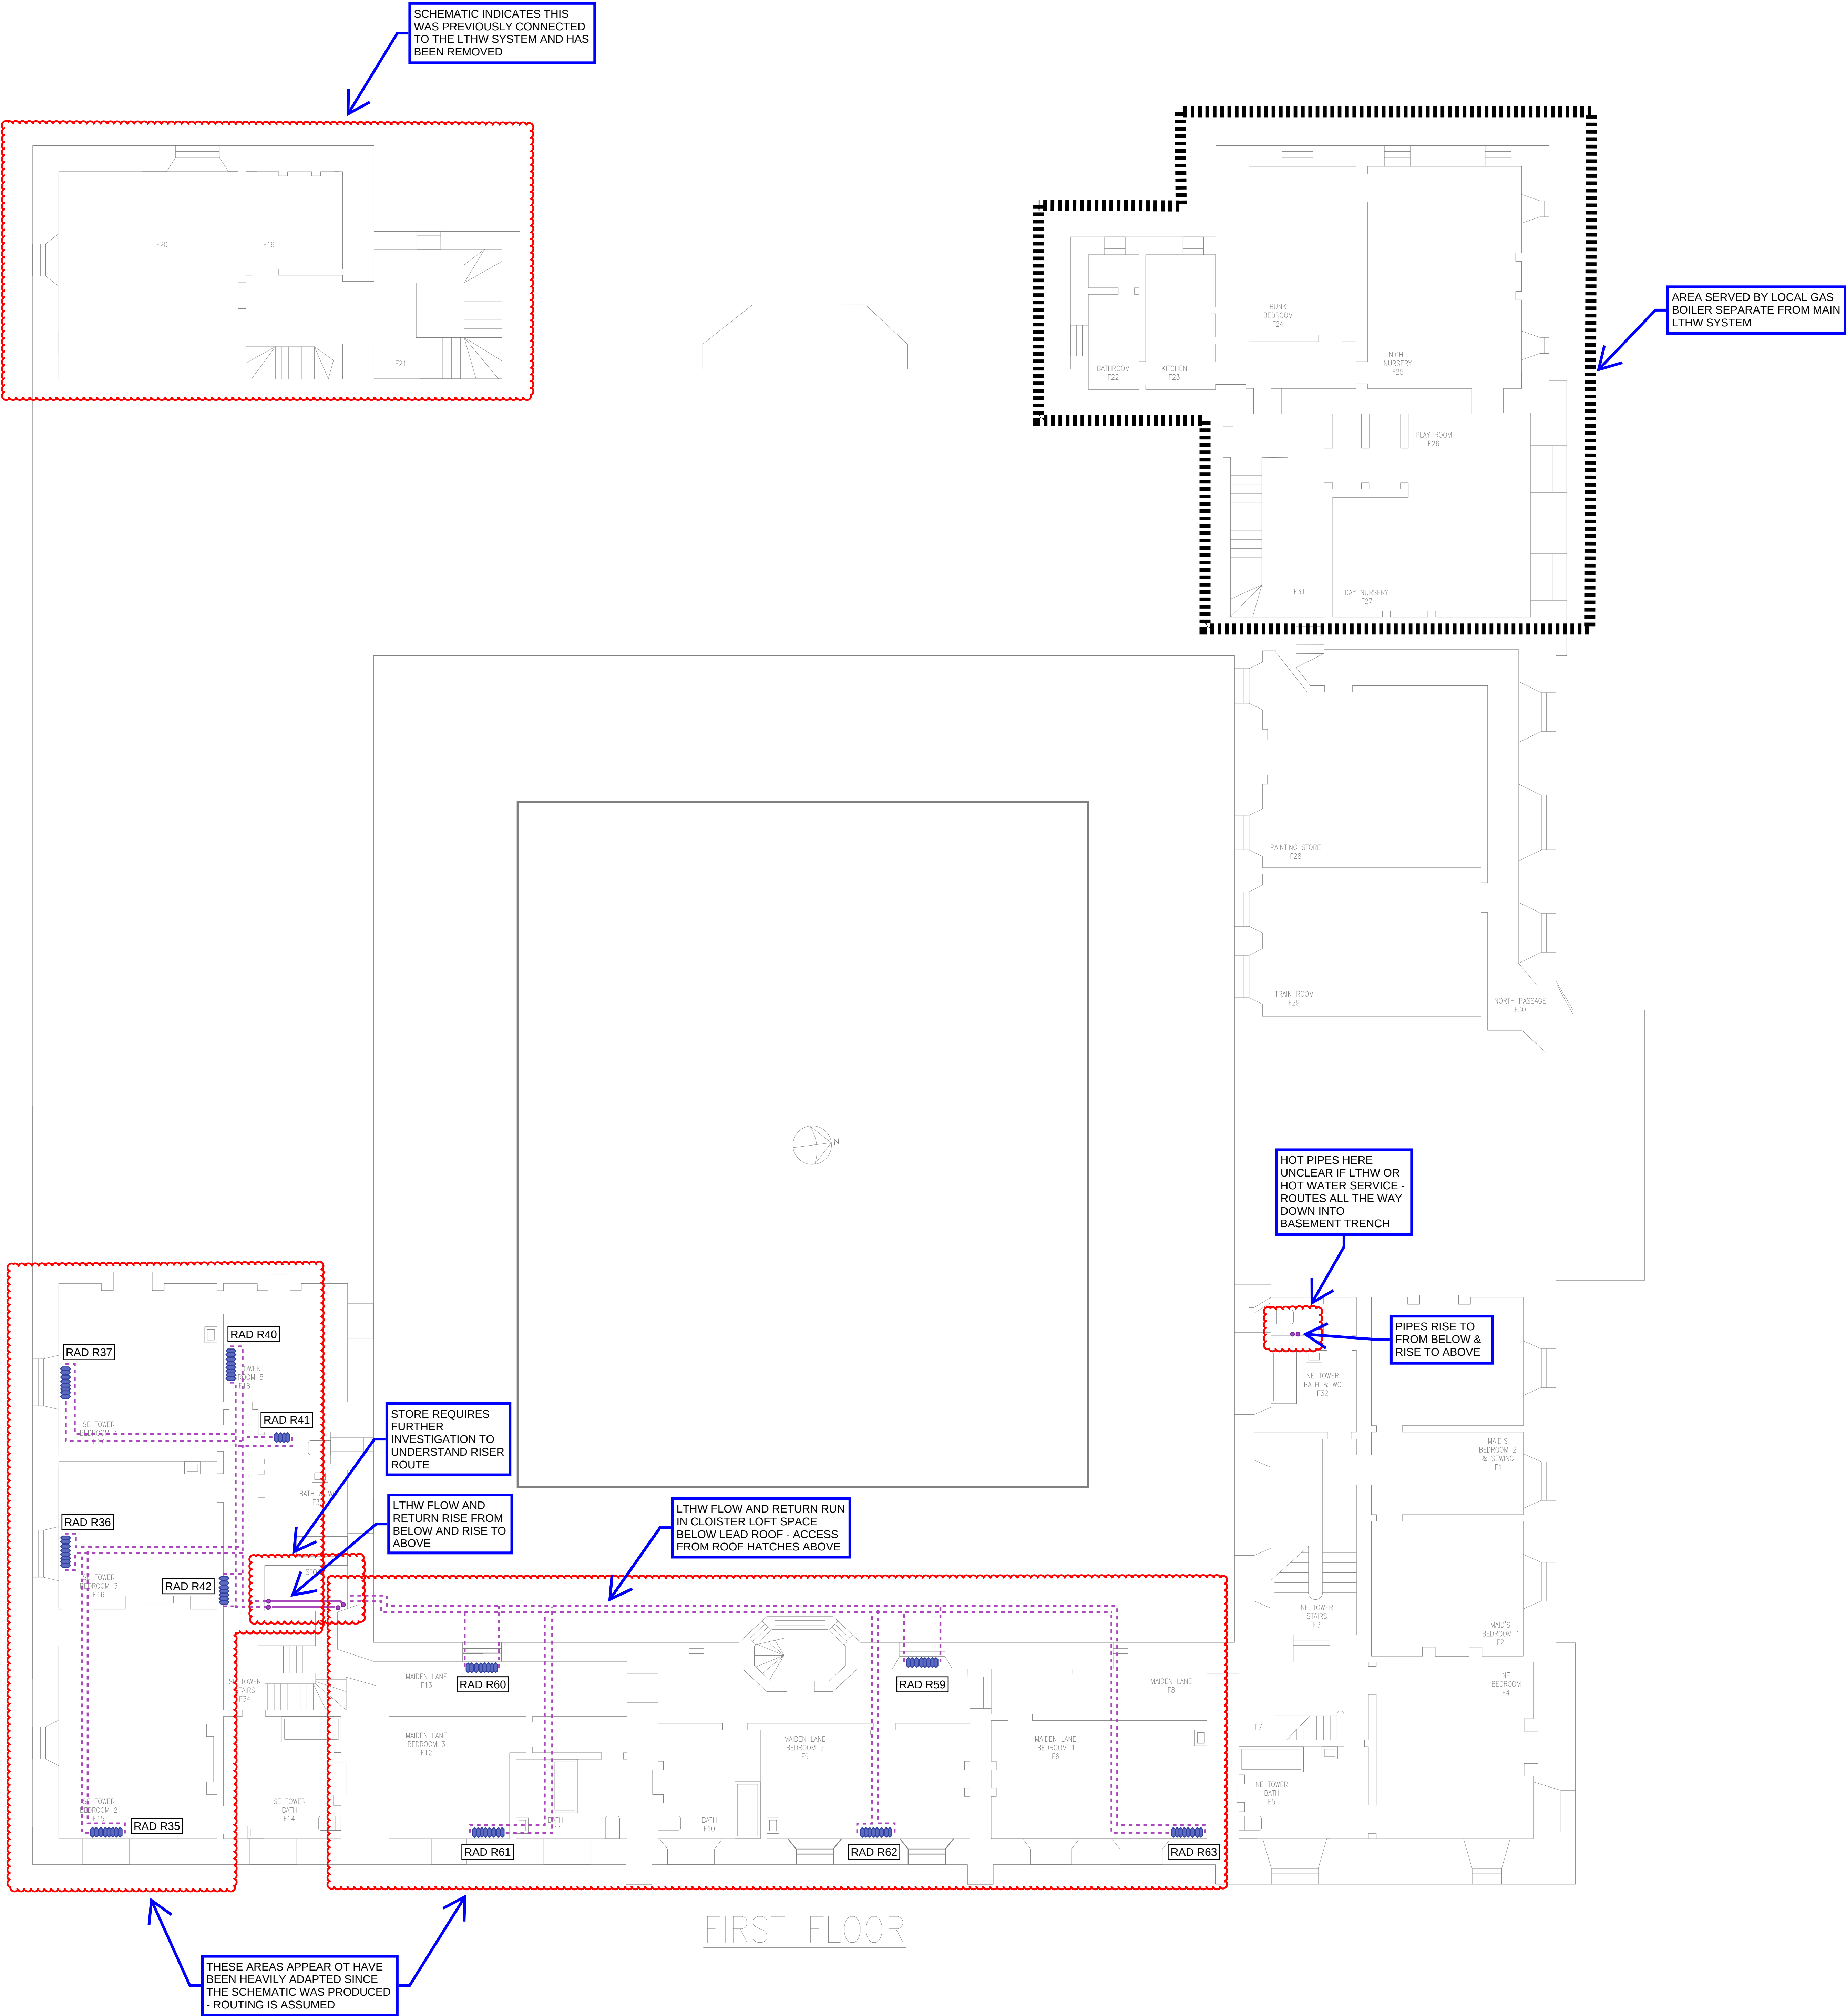

KEY	
.....	MAIN PIPE LOOP IN TRENCH
.....	PIPEWORK BELOW FLOOR
.....	PIPEWORK AT HIGH LEVEL

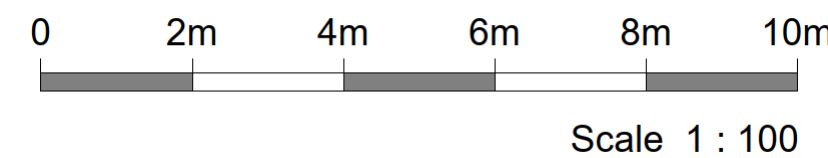

P1	ISSUED FOR INFORMATION	PT
REV	DATE	DESCRIPTION
mta BUILDING SERVICES CONSULTANTS HISTORIC BUILDINGS & CULTURAL HERITAGE Suite 7, Chantry Estate, Cowley Hill, West Hallow, Hampshire, SO21 6AP www.mtaassociates.co.uk 01754 247025		
Client WILTON HOUSE SALISBURY		
Architect		
Project Title WILTON HOUSE SALISBURY		
Drawing Title FIRST FLOOR PLAN INDICATIVE EXISTING HEATING LAYOUT		
Engineer PT	Drawn by RCT	Checked
Date	Scale of A0 1:100 APPROX	
Orig. No. 99982/M103	Rev.	P1