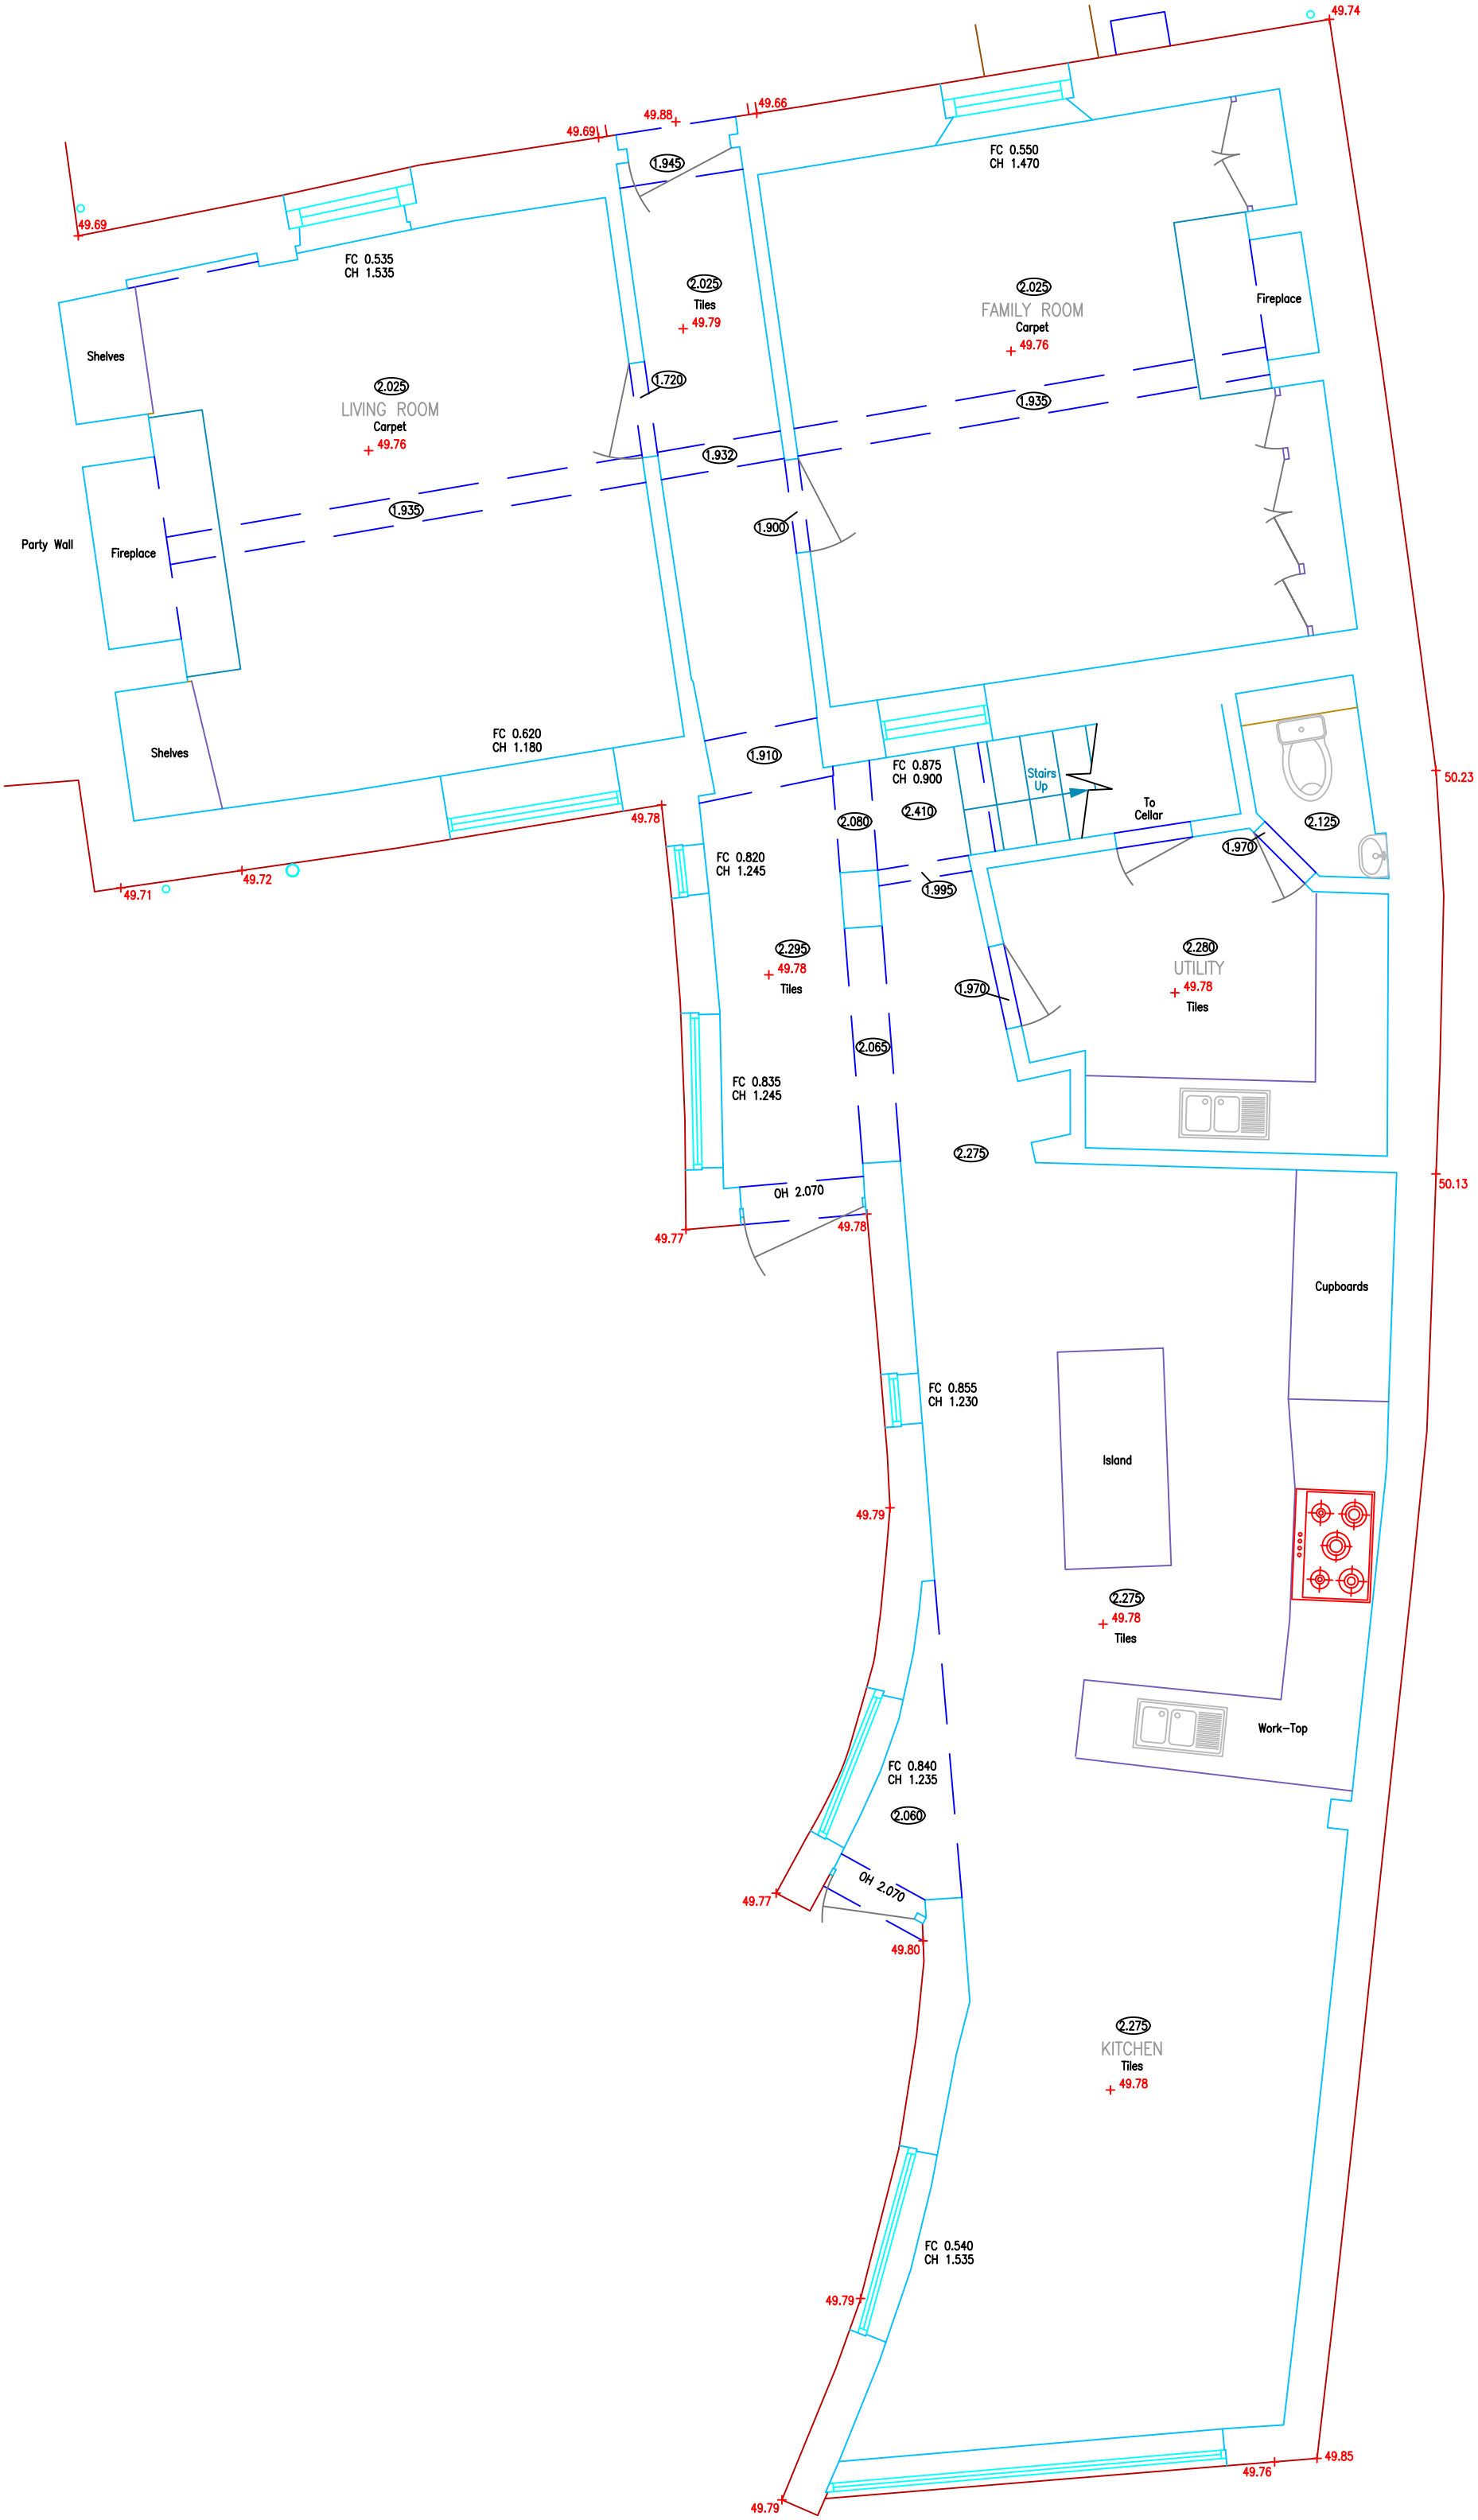
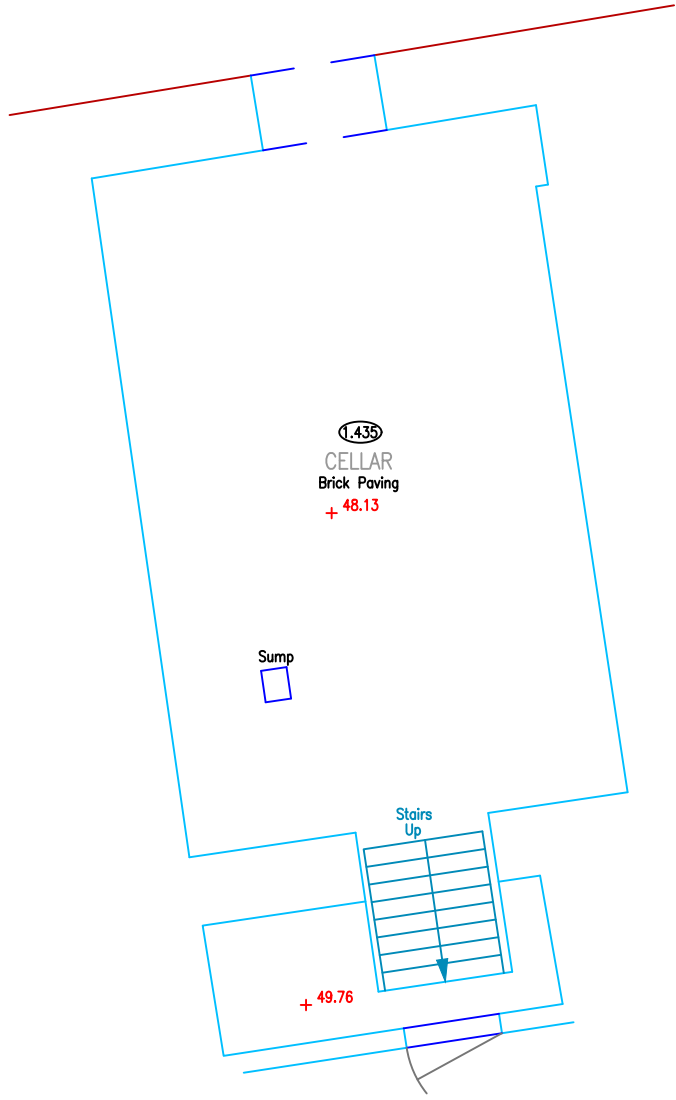


LEGEND	
AH	ARCH HEAD
BT	BRITISH TELECOM
FC	FLOOR TO CILL
CH	CILL TO HEAD
CA	CILL TO ARCH
CS	CILL TO SPRING
CSU	CEILING SLOPES UP
DH	DOOR HEIGHT
DP	DOWN PIPE
HWC	HOT WATER CYLINDER
IC	INSPECTION COVER
OH	OVERHEAD HEIGHT
SP	SPRING POINT
OH	OVERHEAD HEIGHT
RAD	RADIATOR
SVP	SOIL VENT PIPE
WV	WATER VALVE
CH	CEILING HEIGHT
FL	FLOOR LEVEL

Rev.

Comments

By

Chkd

Date

RJM SURVEYS

Land & Building Surveyors

53 Blounts Court, Potterne, Devizes,
Wiltshire, SN10 5QD

rjmsurveys@icloud.com
www.rjmsurveys.com

Project Title:

79 High Street, Ramsbury,
Marlborough, SN8 2QN

CAD Drawing Name:

24591_2_GF.dwg

Drawing Title:

Ground Floor Plan

Client:

James & Samantha Irvine

Date:

June 2024

Scale:

A1 @ 1:50

Drawn by:

RC

Checked by:

RC

Project Code:

24591

Revision:

Grid Orientation:

Local

Site Level Datum:

Local, STN 1 - 50.000m

All dimensions are to be checked on site where applicable. This drawing must not be scaled, and only written dimensions should be respected.