




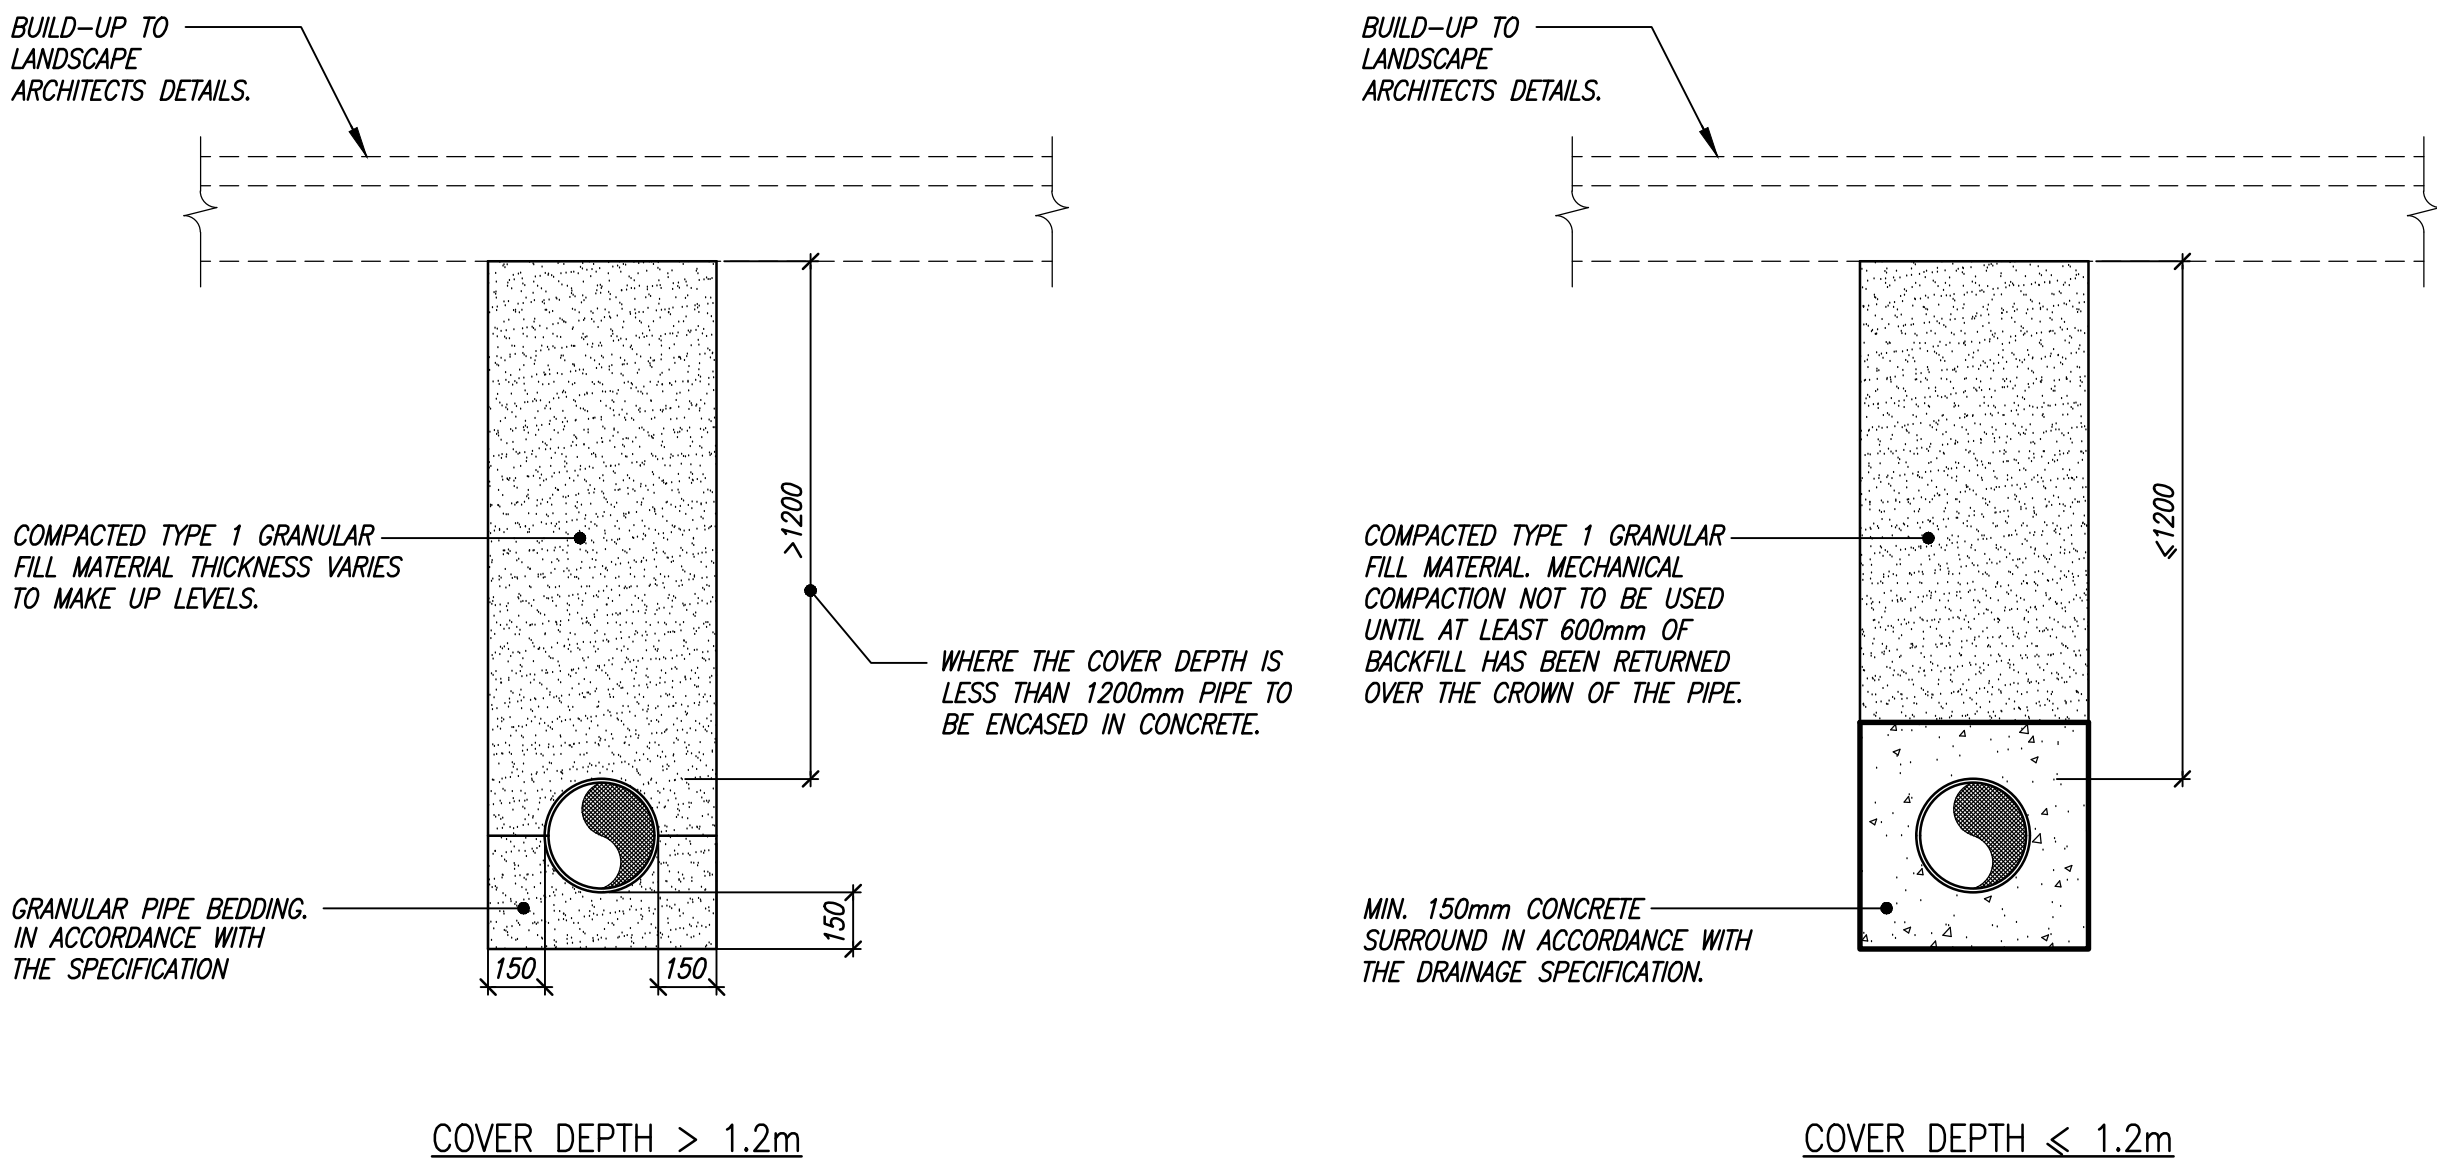

**DETAIL 6**  
TYPICAL PIPE BEDDING DETAIL FOR EXTERNAL PIPEWORK

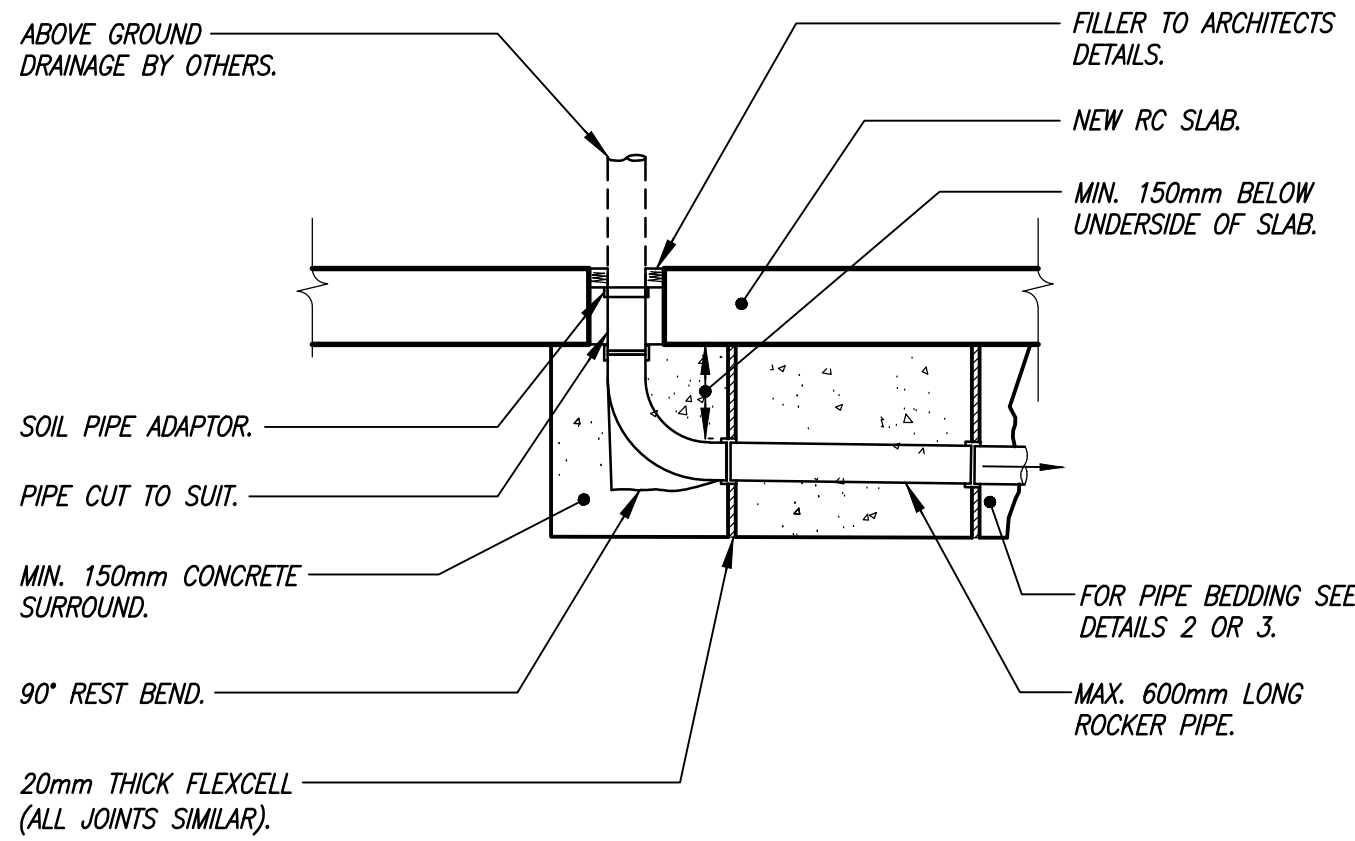

**DETAIL 7**  
TYPICAL SOIL & VENT PIPE CONNECTION DETAIL

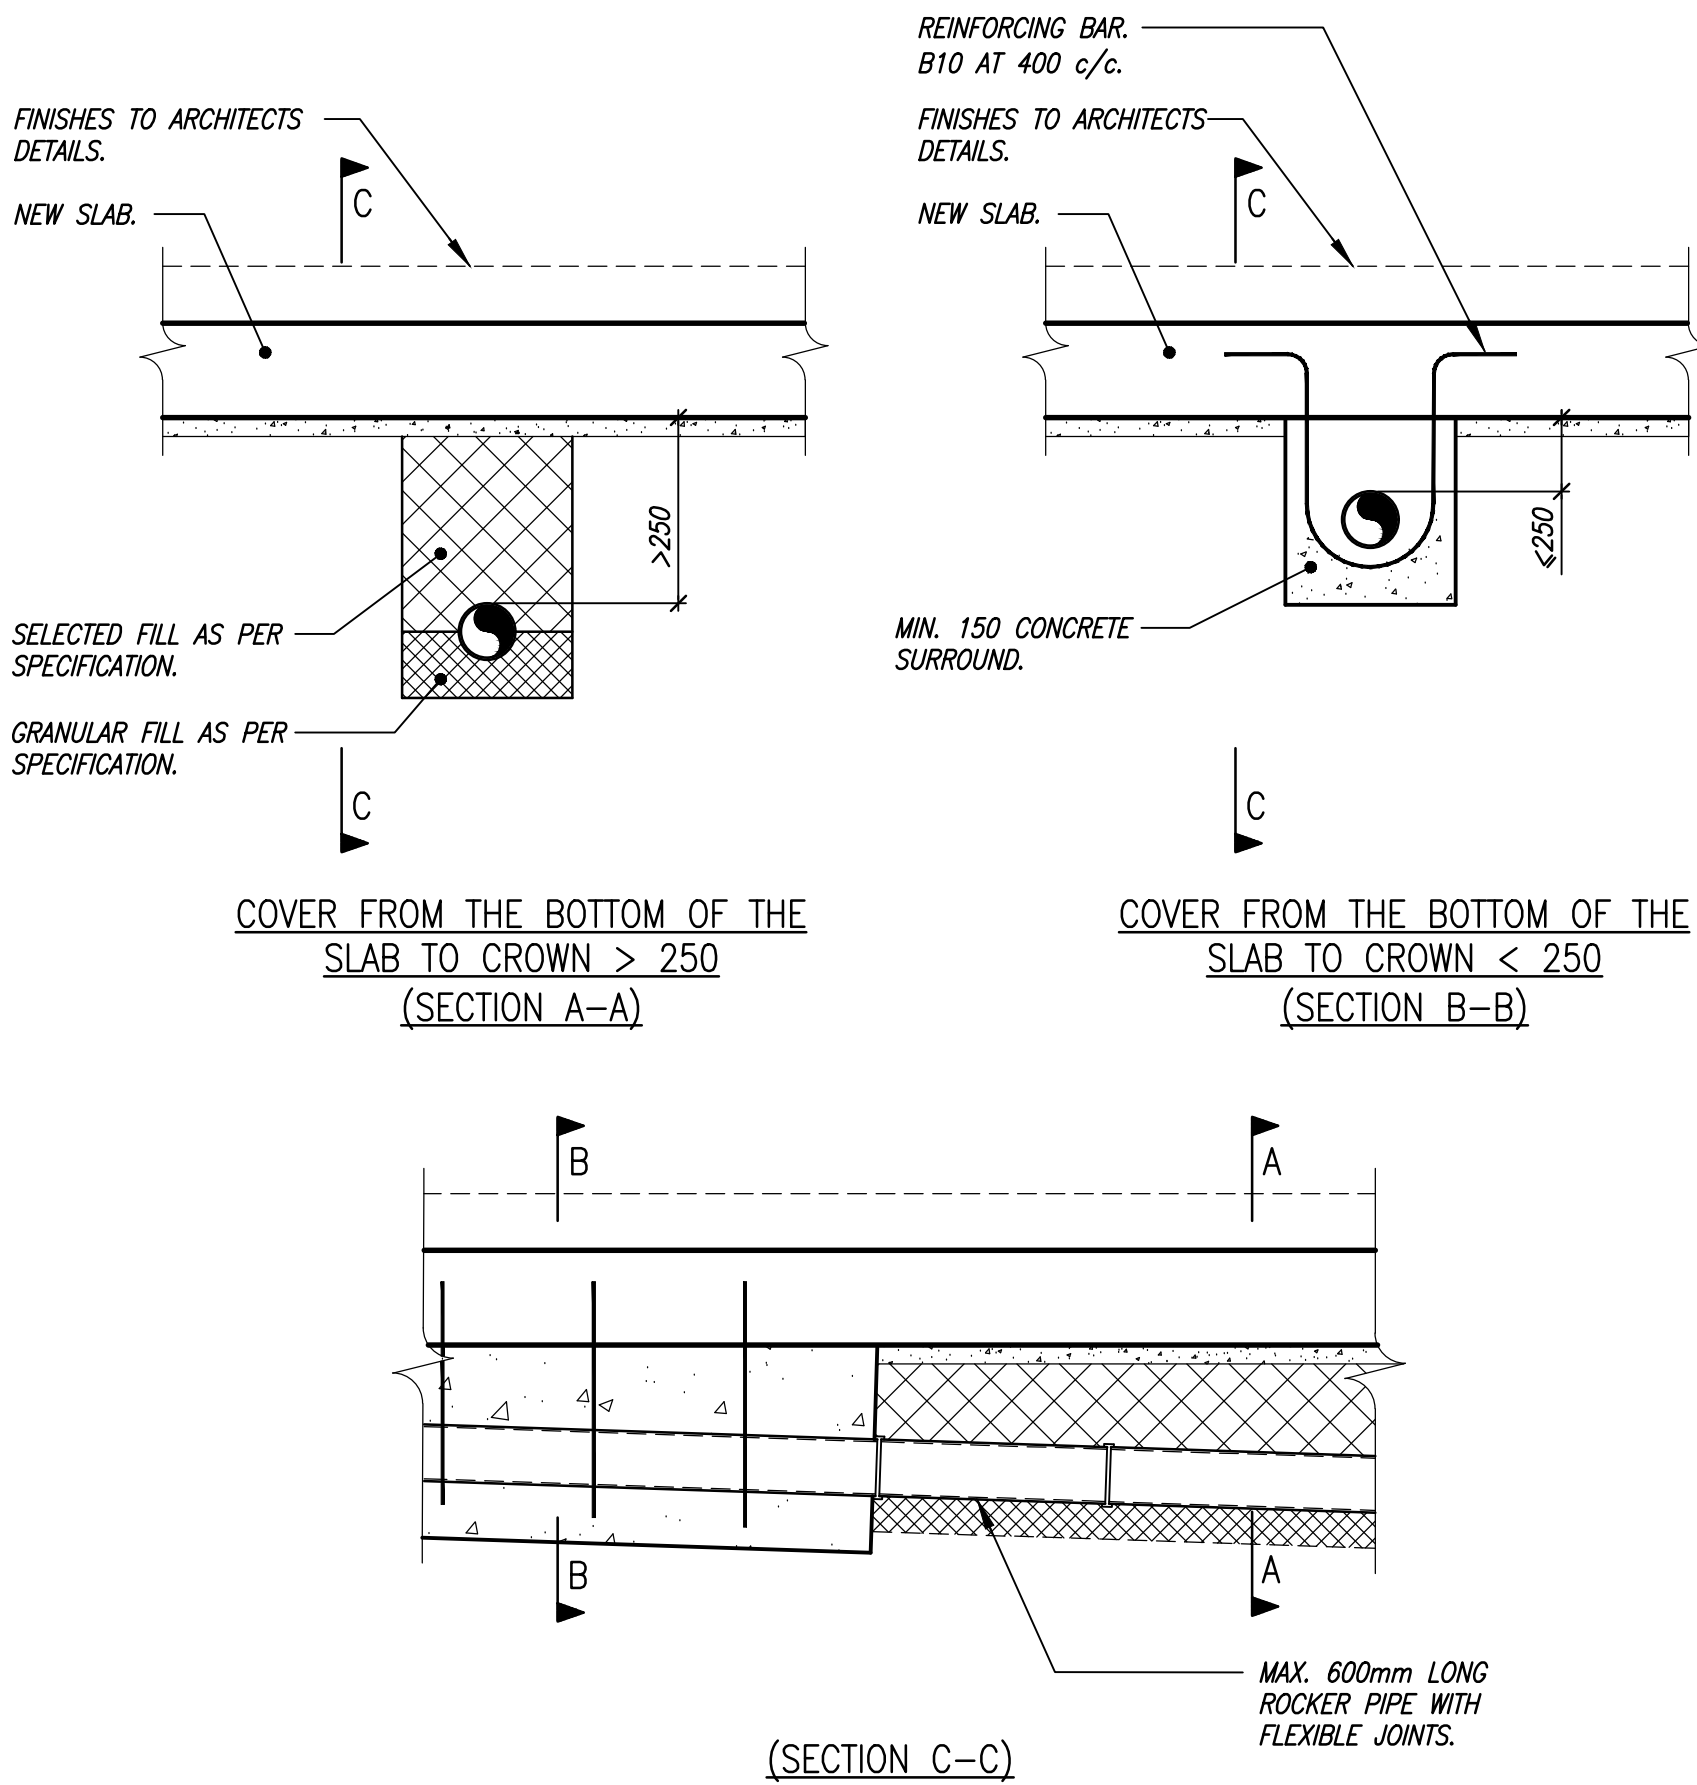

**DETAIL 8**  
PIPE BEDDING DETAILS



- notes
- THIS DRAWING IS TO BE READ IN CONJUNCTION WITH ALL RELEVANT ARCHITECT'S AND ENGINEER'S DRAWINGS AND THE SPECIFICATION.
  - FOR DRAINAGE LAYOUT PLAN, REFER TO DRAWING 1969/020/300.

NOT FOR  
CONSTRUCTION

|   |          |                      |  |    |
|---|----------|----------------------|--|----|
|   |          |                      |  |    |
| B | 18.06.24 | ISSUED FOR PLANNING. |  | HS |
|   | 23.10.23 | ISSUED FOR COMMENT.  |  | HS |

job  
**DEVIZES CASTLE**

title  
**PROPOSED BELOW GROUND DRAINAGE  
DETAILS  
SHEET 2**

|                 |                               |
|-----------------|-------------------------------|
| drawn<br>CW     | checked<br>JD                 |
| date<br>OCT '23 | scale (original - A1)<br>1:20 |

**Alan Baxter**

75 Cowcross Street London EC1M 6EL  
tel 020 7250 1555  
email aba@alanbaxter.co.uk

www.alanbaxter.co.uk

|                                 |                  |
|---------------------------------|------------------|
| dig. no.<br><b>1969/020/351</b> | rev.<br><b>B</b> |
|---------------------------------|------------------|