

UNDERGROUND SERVICES

DRAINAGE
 DUCTS
 FEEDERS
 FENCE PLAN
 GAS
 LIGHTNING PROTECTION - EARTHING

ACCESS ARRANGEMENTS

SURVEY REQUIRED TO CONFIRM ACCESS KEYS FOR
REMAINING ROOMS AND SITE ENTRANCE

SP0055

A	COL.MOD.UK.0006528 PLANNING APPLICATION	19/1125	ULC	ULC
ISS	REVISION	DATE	DRN	APP



SP1 3TR

OS GRID	414438 130201
---------	---------------

TITLE
SITE PLAN
EXISTING

SCALE 1:200


DRAWN	ULC	19/11/25
-------	-----	----------

APPROVED	ULC	19/11/25
----------	-----	----------

DRG No.	Sheet 2 of 2	Re
---------	--------------	----

UK-WI-001346-04-000-MD047 A

A3

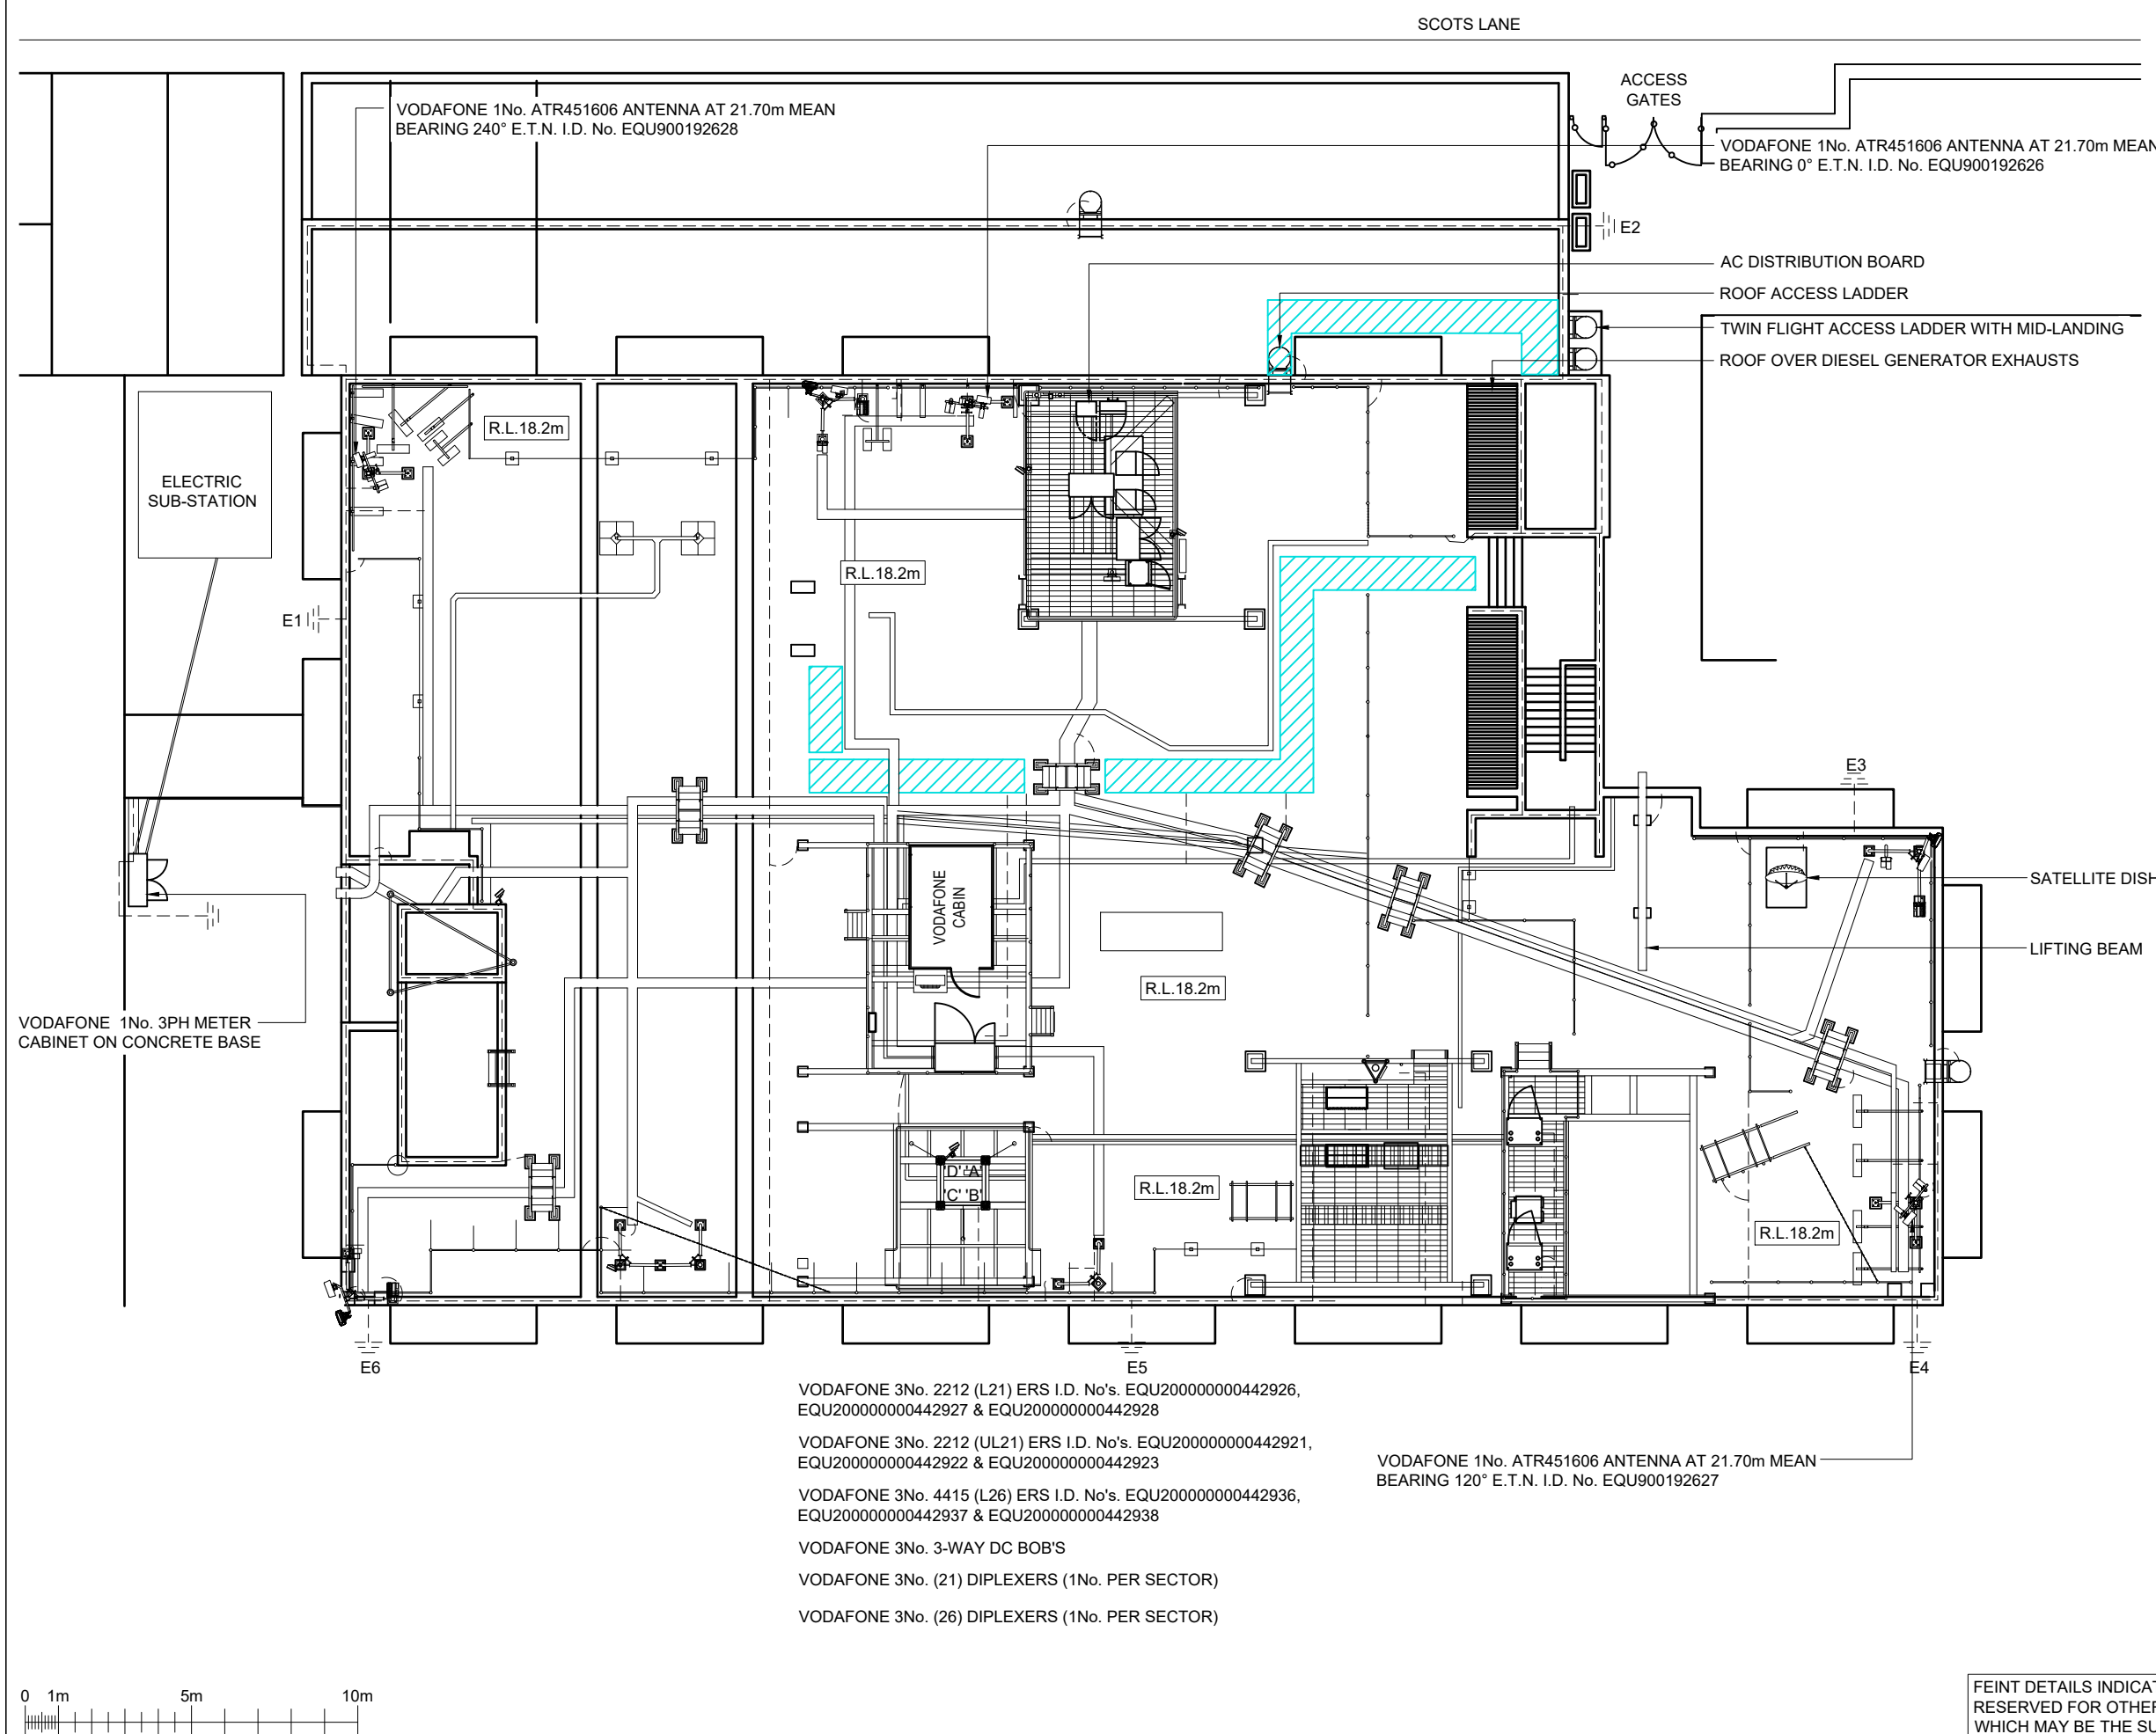

FEINT DETAILS INDICATE LOCATIONS
RESERVED FOR OTHER PROPOSALS
WHICH MAY BE THE SUBJECT OF
SEPARATE APPLICATIONS