


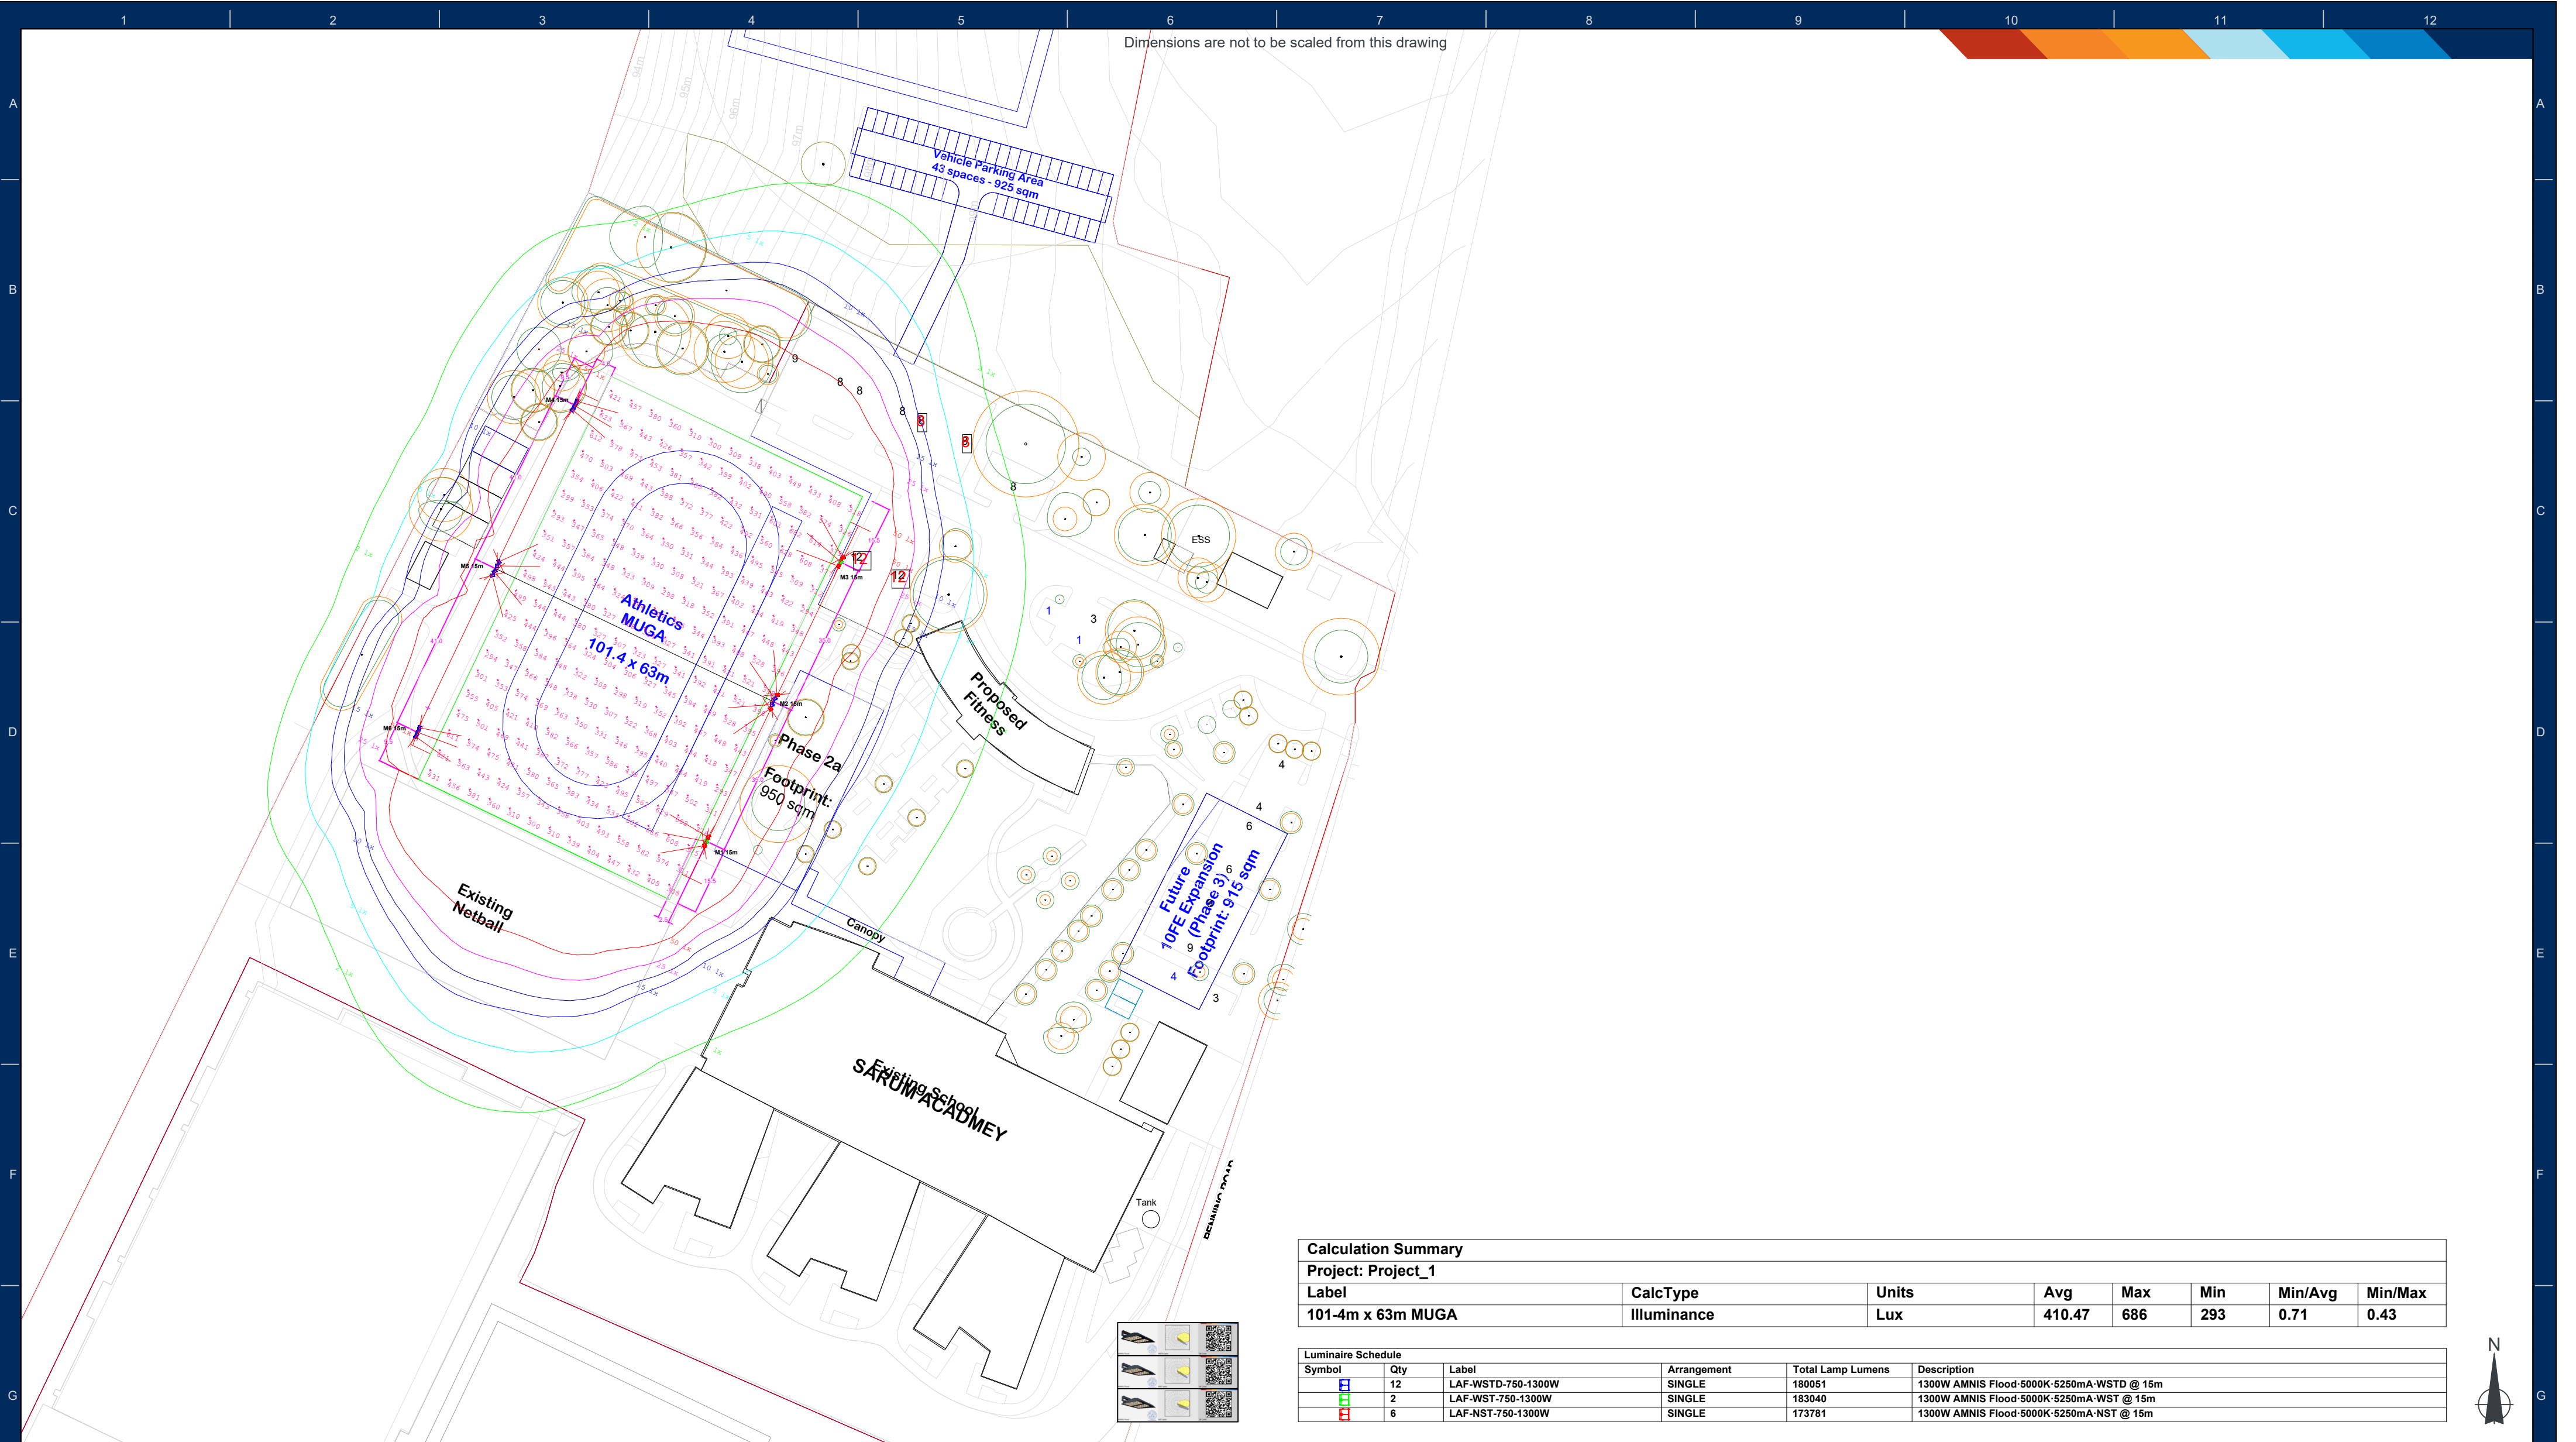

Dimensions are not to be scaled from this drawing

Calculation Summary							
Project: Project_1							
Label	CalcType	Units	Avg	Max	Min	Min/Avg	Min/Max
101-4m x 63m MUGA	Illuminance	Lux	410.47	686	293	0.71	0.43

Luminaire Schedule					
Symbol	Qty	Label	Arrangement	Total Lamp Lumens	Description
	12	LAF-WSTD-750-1300W	SINGLE	180051	1300W AMNIS Flood-5000K-5250mA-WSTD @ 15m
	2	LAF-WST-750-1300W	SINGLE	183040	1300W AMNIS Flood-5000K-5250mA-WST @ 15m
	6	LAF-NST-750-1300W	SINGLE	173781	1300W AMNIS Flood-5000K-5250mA-NST @ 15m

Sarum Academy - Muga

- 6 Masts Option

Scale

1: 1000 at A2

Project Number

D93234

Date

6 January 2026

Drawing No.

Rev A

Designed By :

JC

For this lighting design a 1mf has been used. If it differs from the maintenance plan for this project then you must advise us accordingly

A lighting applications design service is provided by us in good faith and without charge, relating to Kingfisher products only. As such, whilst every endeavor is made for accuracy from information provided by yourselves, the final responsibility for the suitability of the design lies with the client. The company cannot, therefore, accept any liability or consequential loss incurred. *If the drawing supplied to Kingfisher is a PDF then an AutoCAD drawing is to be provided prior to order. When converting a PDF, the scale is not precise.*

Kingfisher

SPORT

A division of the

LUCECO

group

Rev.	Description	Initials

Commercial

sync energy

For more information on EV charging for your installation please visit

www.sync.energy or click the image

A2