


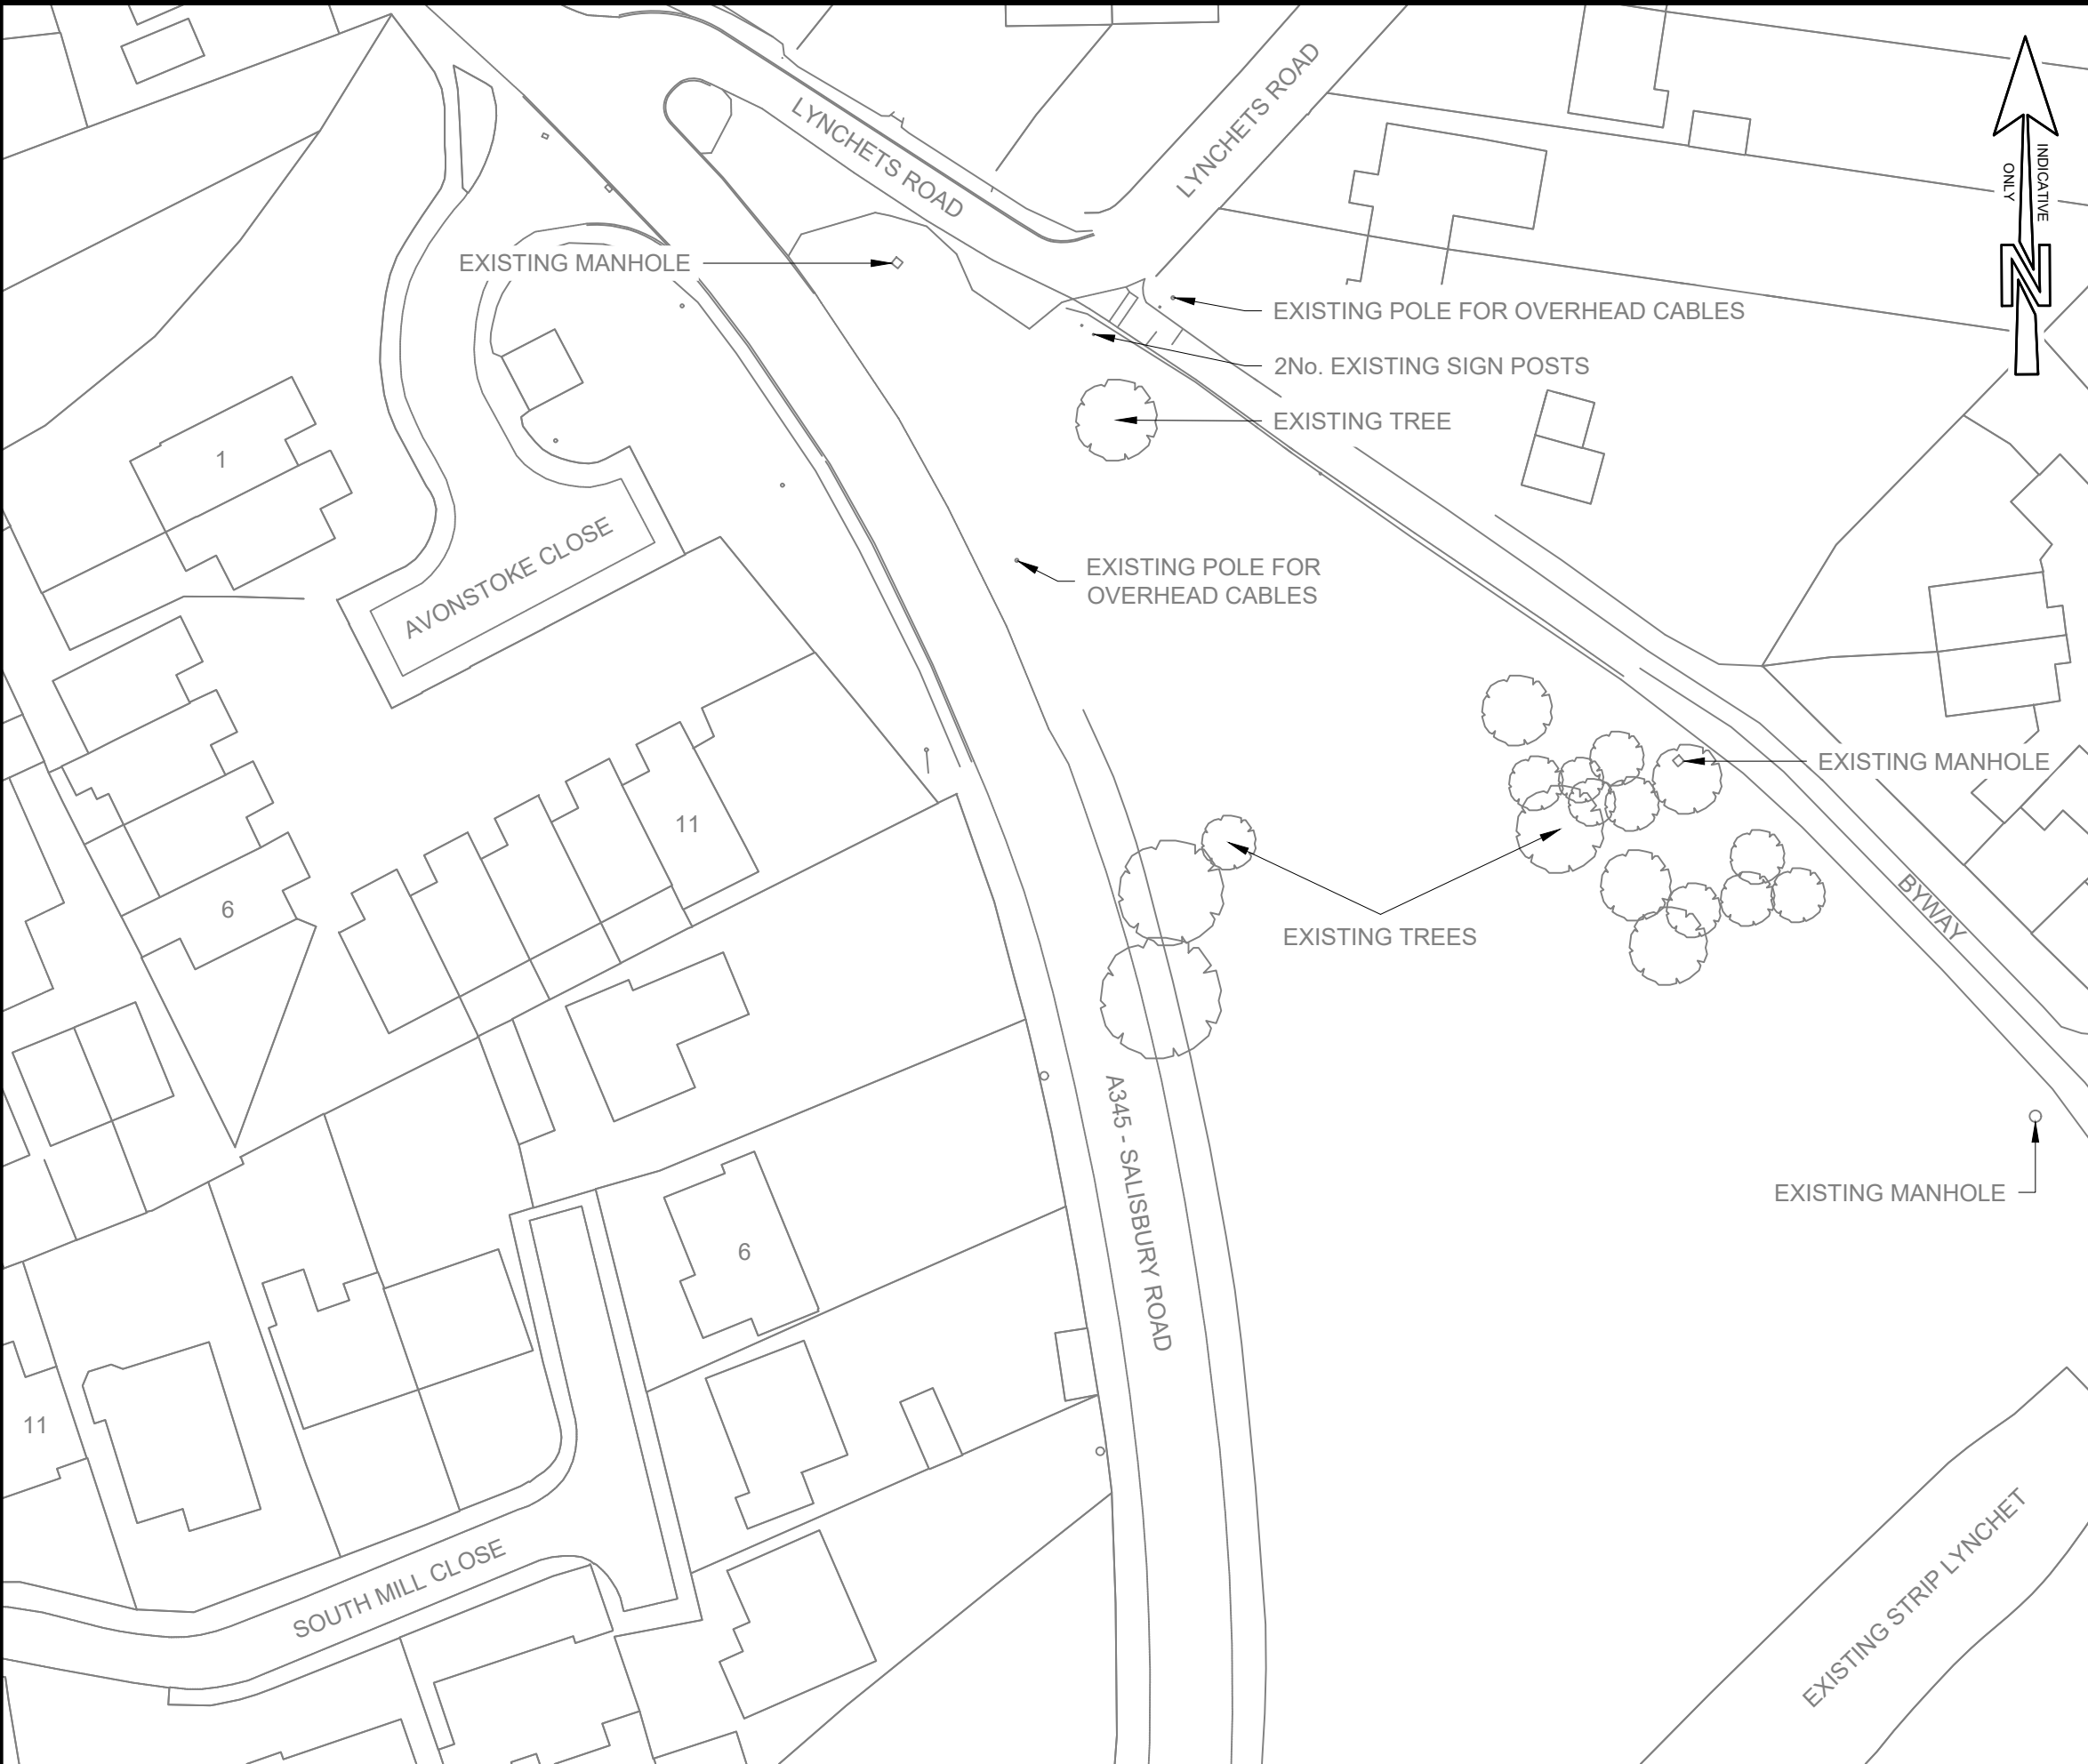

SITE ID90455

NGR415866, 140966

NOTES

1.

ANY MAPS ON THIS DRAWING ARE REPRODUCED FROM THE ORDNANCE SURVEY MAP WITH THE PERMISSION OF HIS MAJESTY'S STATIONERY OFFICE © CROWN COPYRIGHT RESERVED, LICENCE No. 100019539.

2.

UNLESS NOTED OTHERWISE, ALL DIMENSIONS ARE IN MILLIMETRES AND ALL LEVELS ARE IN METRES AOD.

C01	FIRST ISSUE	DHI	OJE	JZS	15/01/2026
MK	REVISIONS	DRN	CHK	APP	DATE

KINGS GATE

AMESBURY

BELOW GROUND

STORM WATER STORAGE TANK

PLANNING APPLICATION

EXISTING SITE PLAN

APPROVED FOR ISSUE

ORIGINAL DRAWING SIZE A3

INITIALS	DATE	SCALES	REV.
DESIGNED: PR	08/04/2025	1:500	C01
DRAWN BY: DHI	08/04/2025		

DRAWING NUMBER

C00520-WWSL-XX-XX-D-T-7201

Wessex Water

YTL GROUP

SITE PLAN
SCALE: 1:500

