


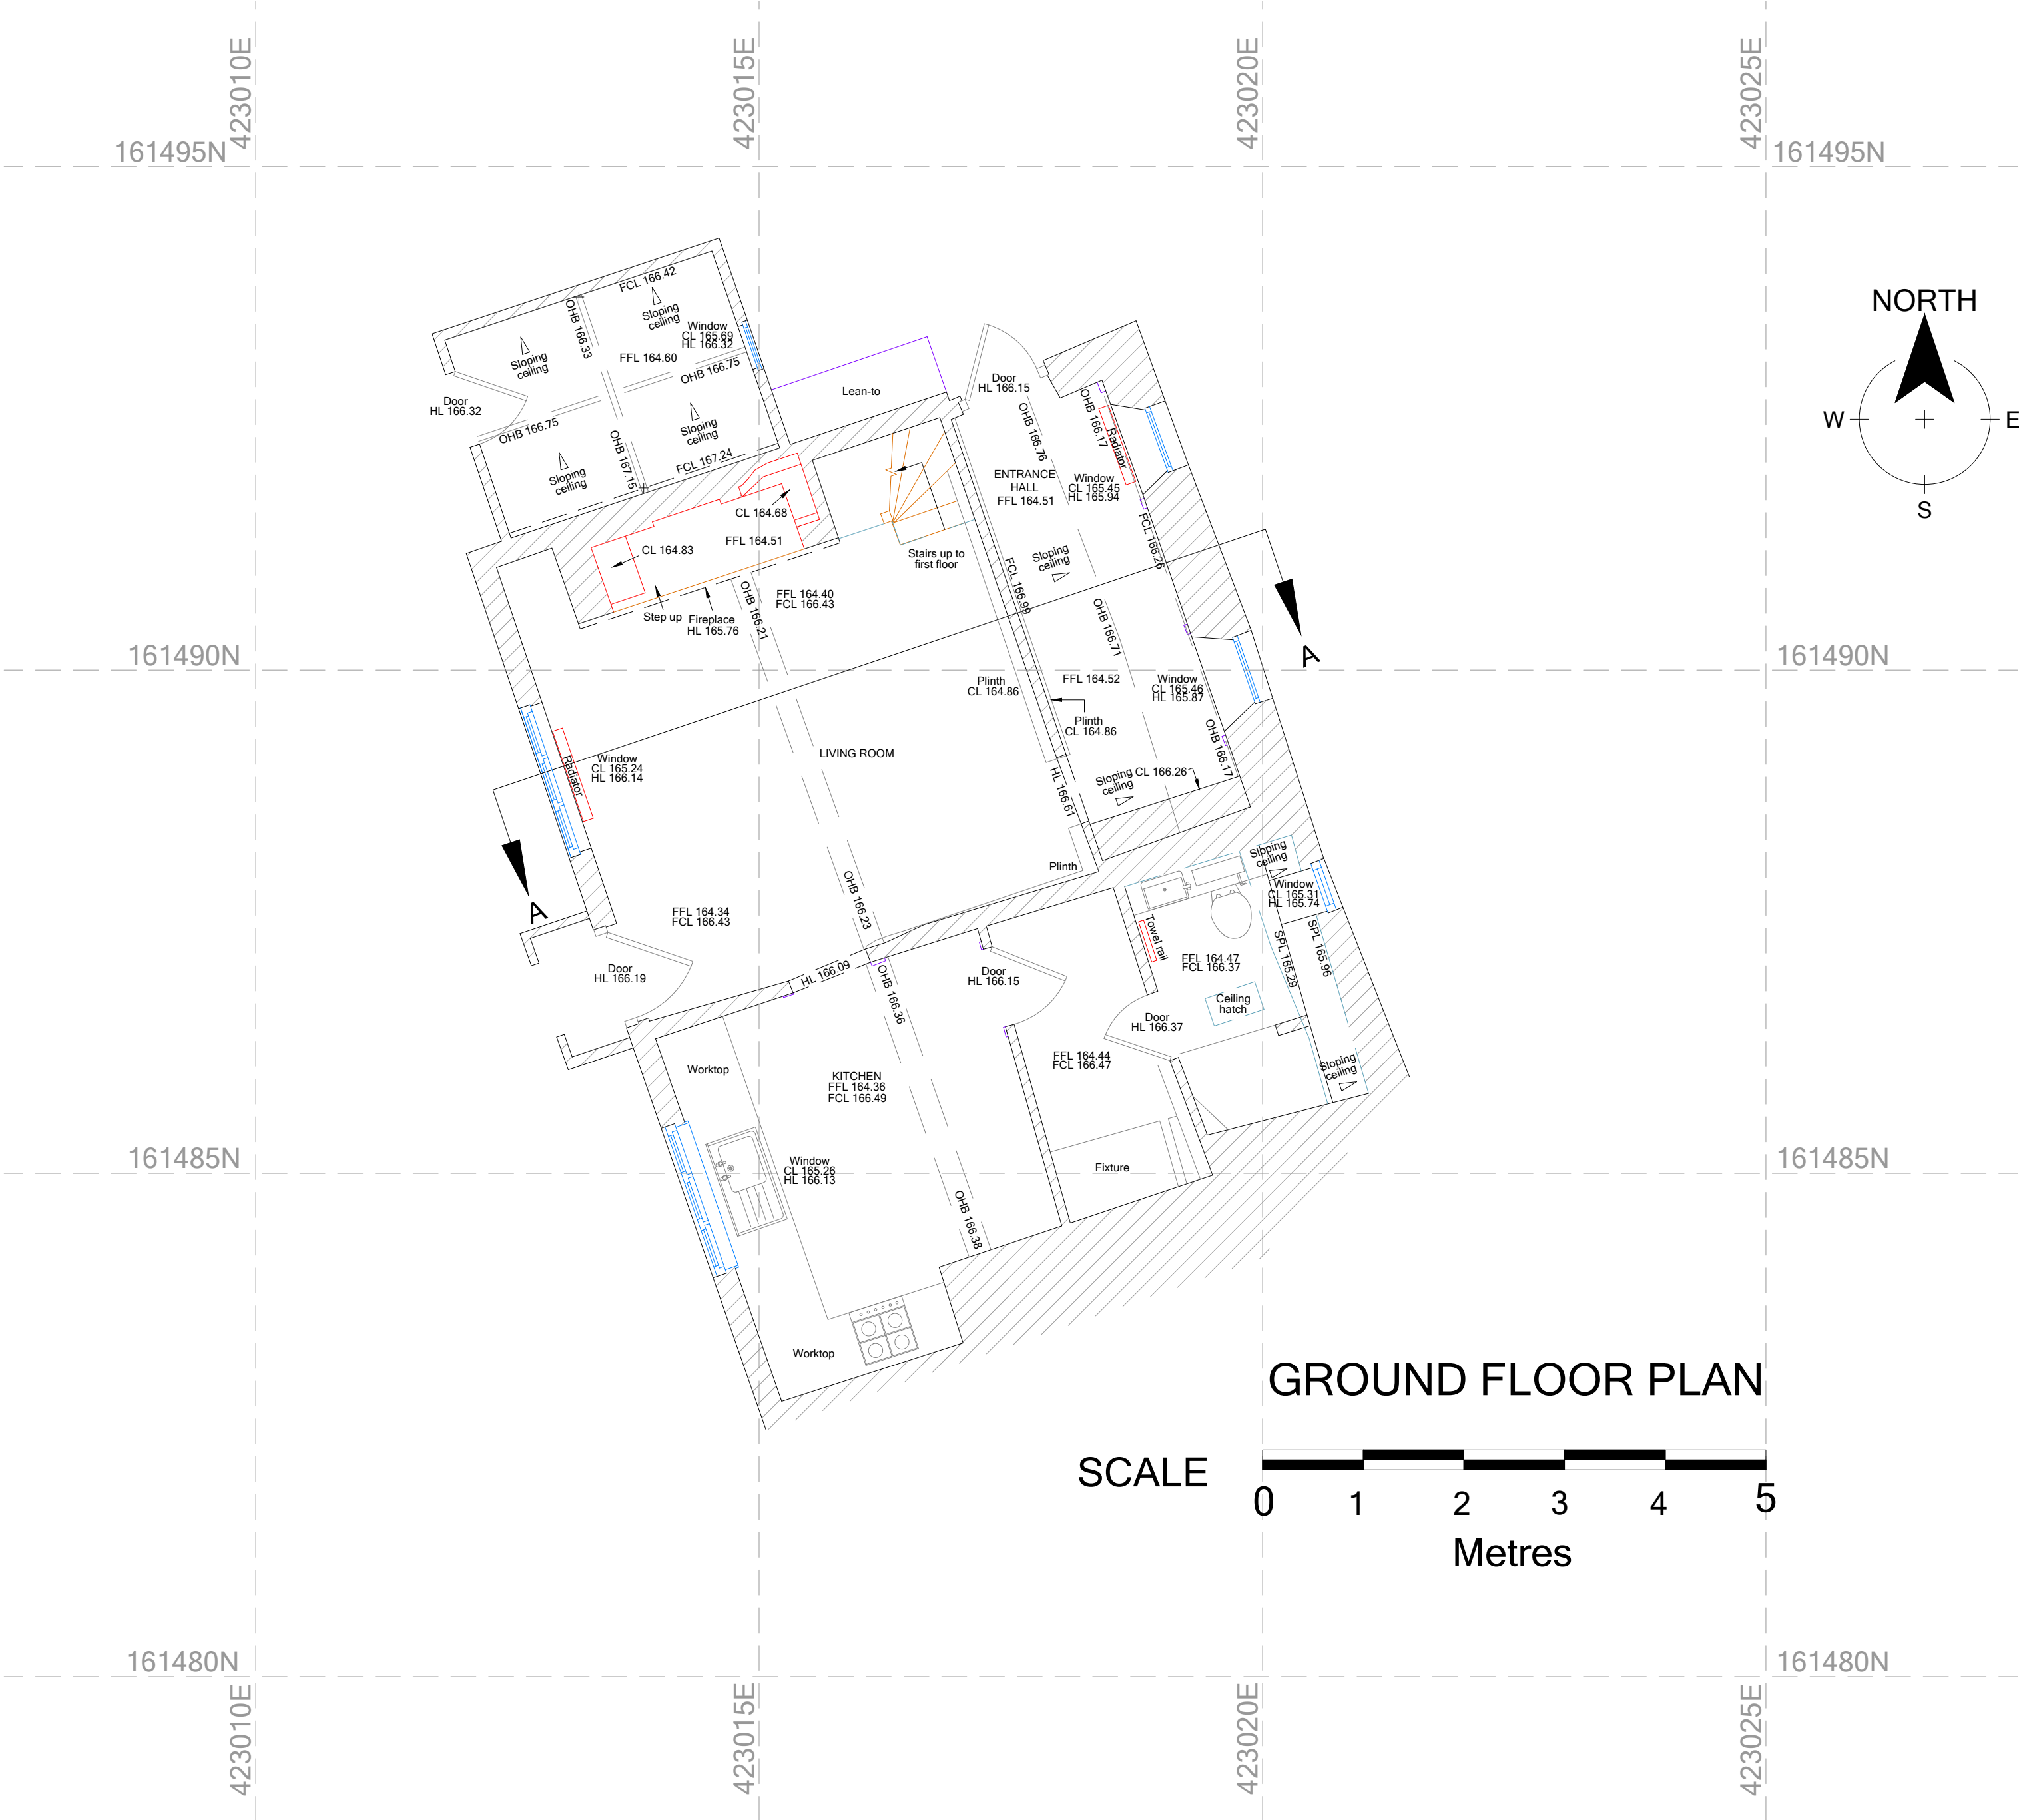

LEGEND		SYMBOLS	
CL	Cill Level		Electricity Meter/ Panel
DP	Down pipe		Gas Meter/Panel
FFL	Finished Floor Level		Water Meter
FCL	Finished Ceiling Level		Arched ceiling
GY	Gully		Sloping ceiling
HL	Head Level		
IC	Inspection Cover		
MH	Manhole		
OHB	Underside Overhead Beam Level		
SHL	Structural Head Level		
SPL	Spring Point Level		
SVP	Soil Vent Pipe		
TWL	Top of Wall Level		

NOTES

Level Datum: OS National Grid OSGM15

Grid Orientation: OS National Grid OSTN15

Scale Factor: Scale Factor 1

Scale Factor 1 is based on a true OS National Grid co-ordinate at:
S1 423006.550,161439.133,160.423

The contractor is to check and verify all critical dimensions and levels before work starts.

Every effort is made to identify all visible above ground features. However, it may be possible that certain features are obscured at the time of survey.



Unit 59, Shrivensham Hundred Business Park
Watchfield, Swindon, Wiltshire, SN6 8TY
EMAIL : admin@brunelsurveys.com
WEB : www.brunelsurveys.com
TEL : 01793 784700

CLIENT	
A L Associates Ltd.	
JOB TITLE	
113 High Street Burbage SN8 3AA	
House Ground Floor Plan	
REVISIONS	
SCALE	
A2 Sheet @ 1 to 50	
DATE	Nov 2023
DRAWN BY	SH
SURVEYED BY	SH
CHECKED BY	SH
DRAWING No.	
25209-50-03HOUSE	