


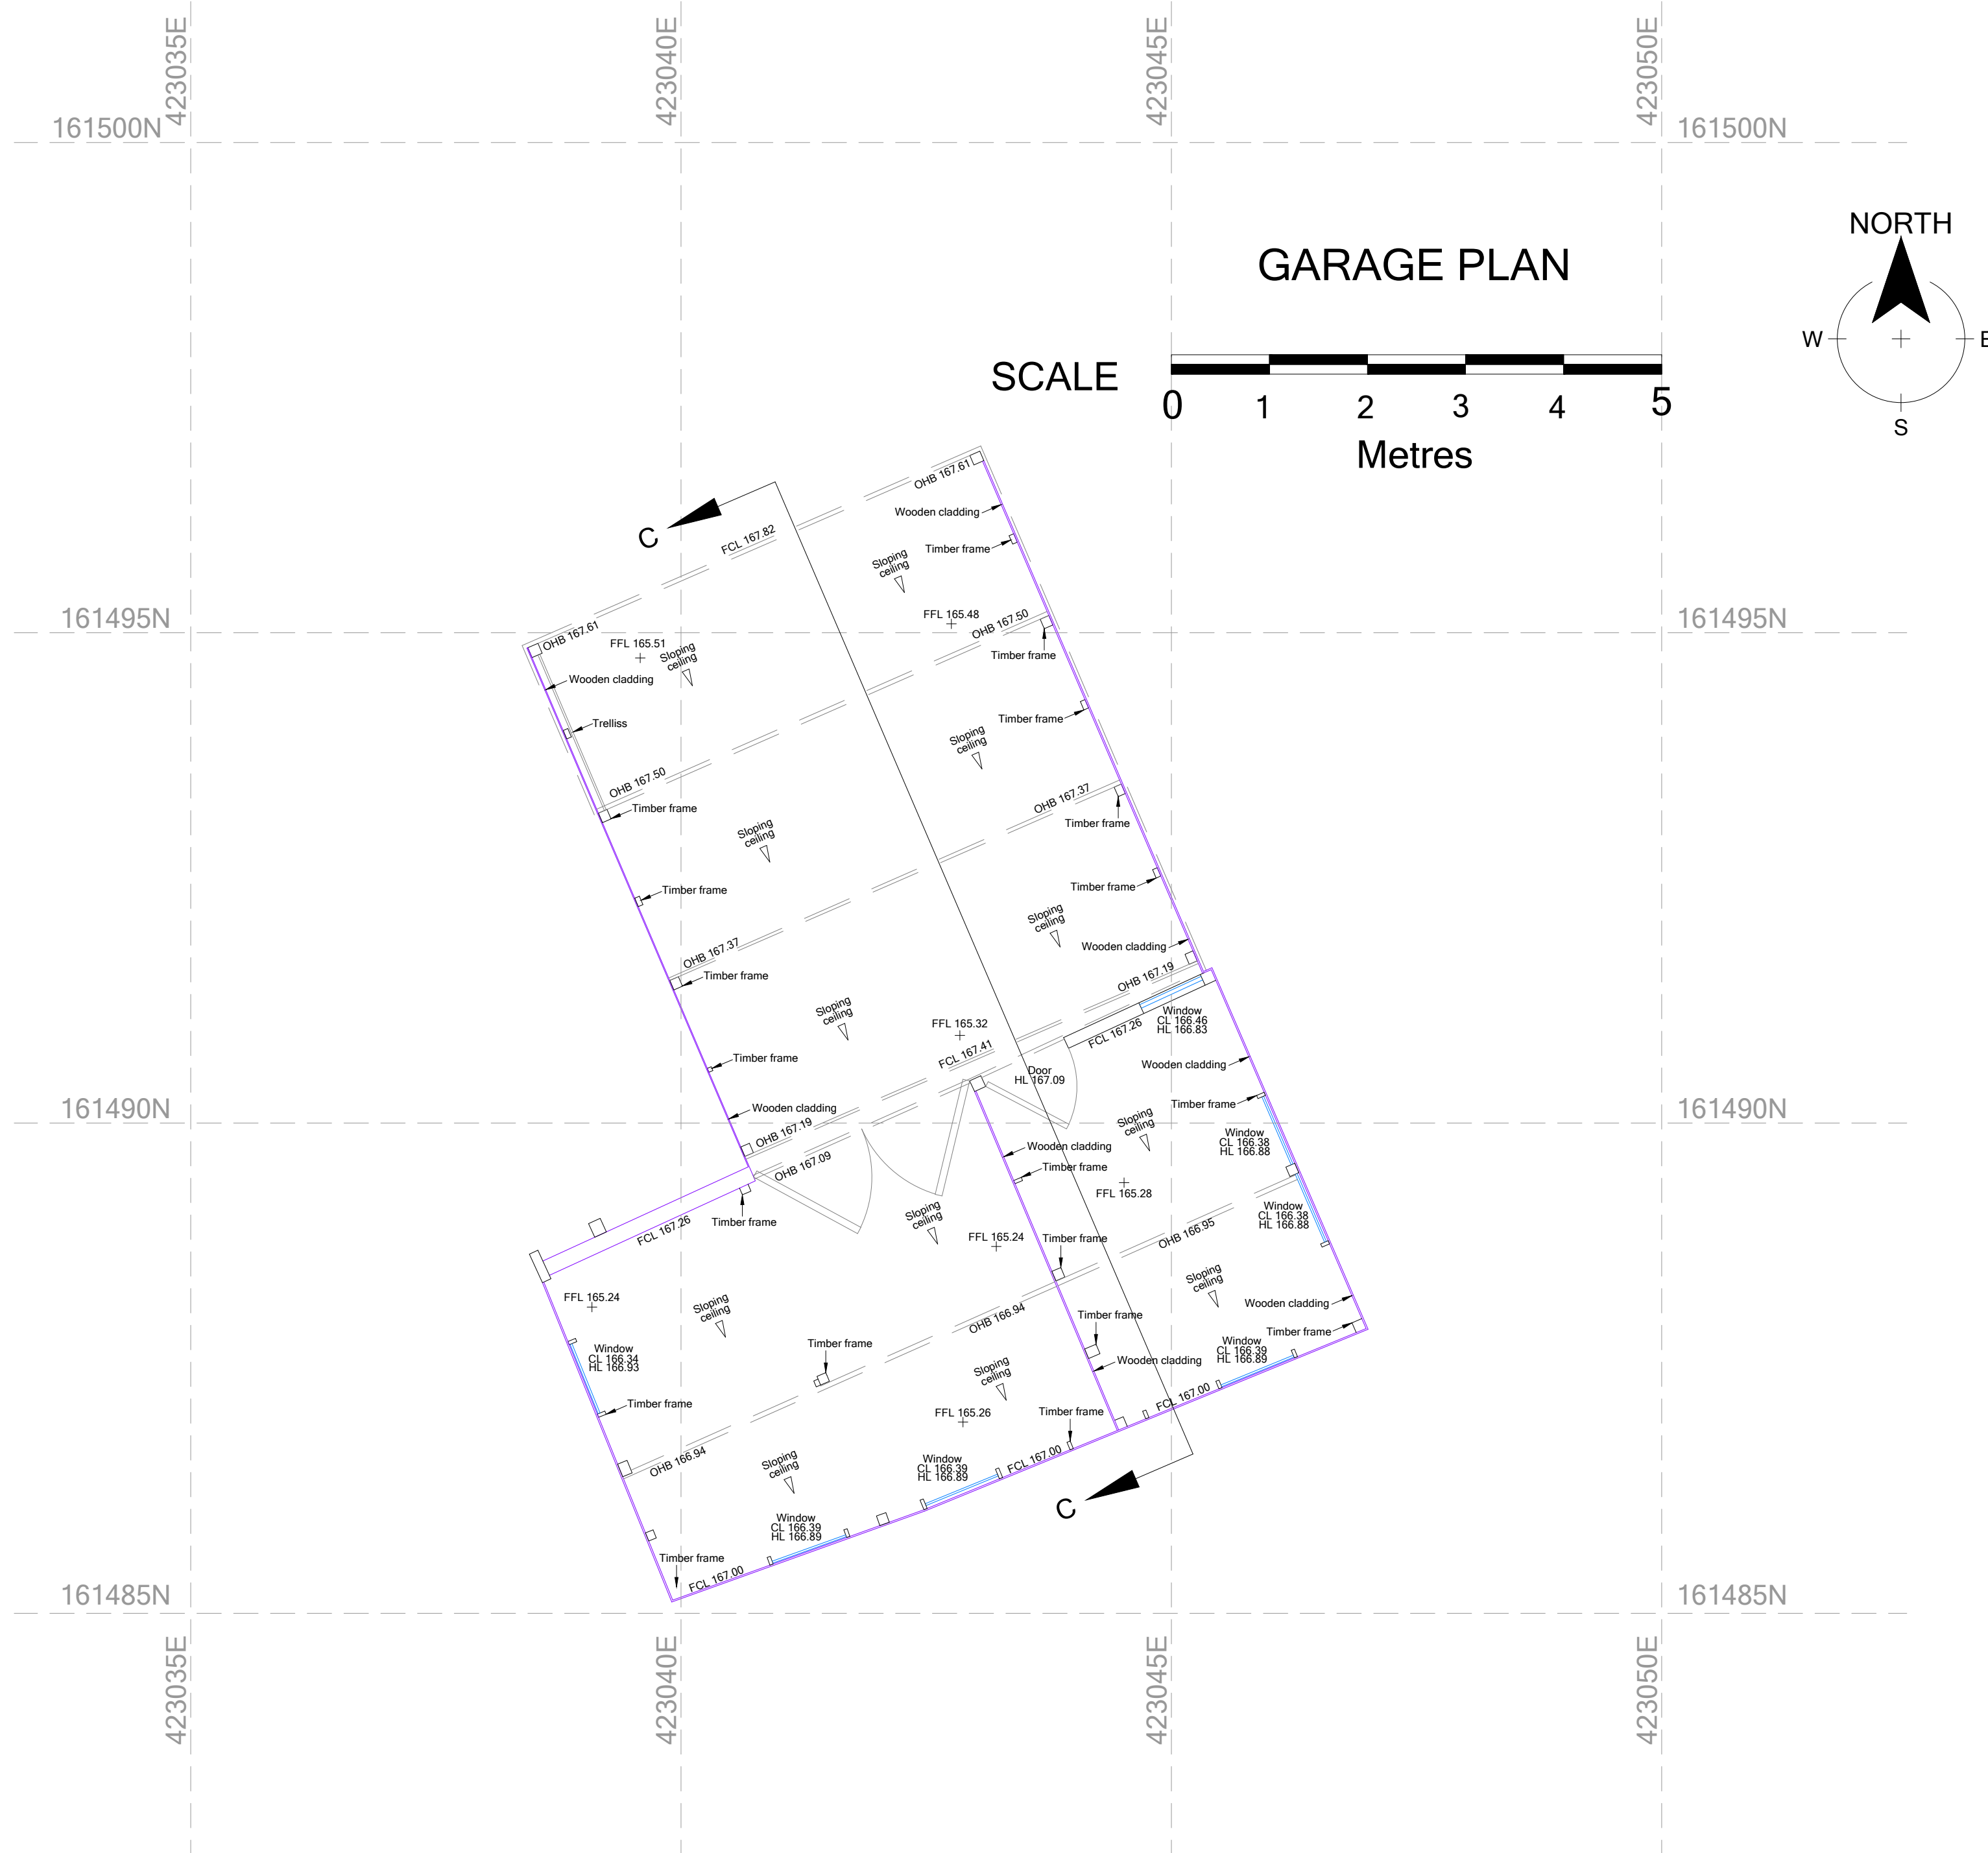

LEGEND		SYMBOLS	
CL	Cill Level		Electricity Meter/ Panel
DP	Down pipe		
FFL	Finished Floor Level		Gas Meter/Panel
FCL	Finished Ceiling Level		
GY	Gully		
HL	Head Level		Water Meter
IC	Inspection Cover		
MH	Manhole		
OHB	Underside Overhead Beam Level		Arched ceiling
SHL	Structural Head Level		
SPL	Spring Point Level		
SVP	Soil Vent Pipe	Low  High	Sloping ceiling
TWL	Top of Wall Level		

NOTES

Level Datum: OS National Grid OSGM15

Grid Orientation: OS National Grid OSTN15

Scale Factor: Scale Factor 1

Scale Factor 1 is based on a true OS National Grid co-ordinate at:
S1 423006.550,161439.133,160.423

The contractor is to check and verify all critical dimensions and levels before work starts.

Every effort is made to identify all visible above ground features. However, it may be possible that certain features are obscured at the time of survey.



Brunel Surveys Ltd
Land, Building and Utility Surveyors

Unit 59, Shrivernham Hundred Business Park
Watchfield, Swindon, Wiltshire, SN6 8TY
EMAIL : admin@brunelsurveys.com
WEB : www.brunelsurveys.com
TEL : 01793 784700

CLIENT

A L Associates Ltd.

JOB TITLE

113 High Street
Burbage
SN8 3AA

Garage Floor Plan

REVISIONS

SCALE

A2 Sheet @ 1 to 50

DATE	Nov 2023	SURVEYED BY	SH
DRAWN BY	SH	CHECKED BY	SH

DRAWING No.

25209-50-04GARAGE