



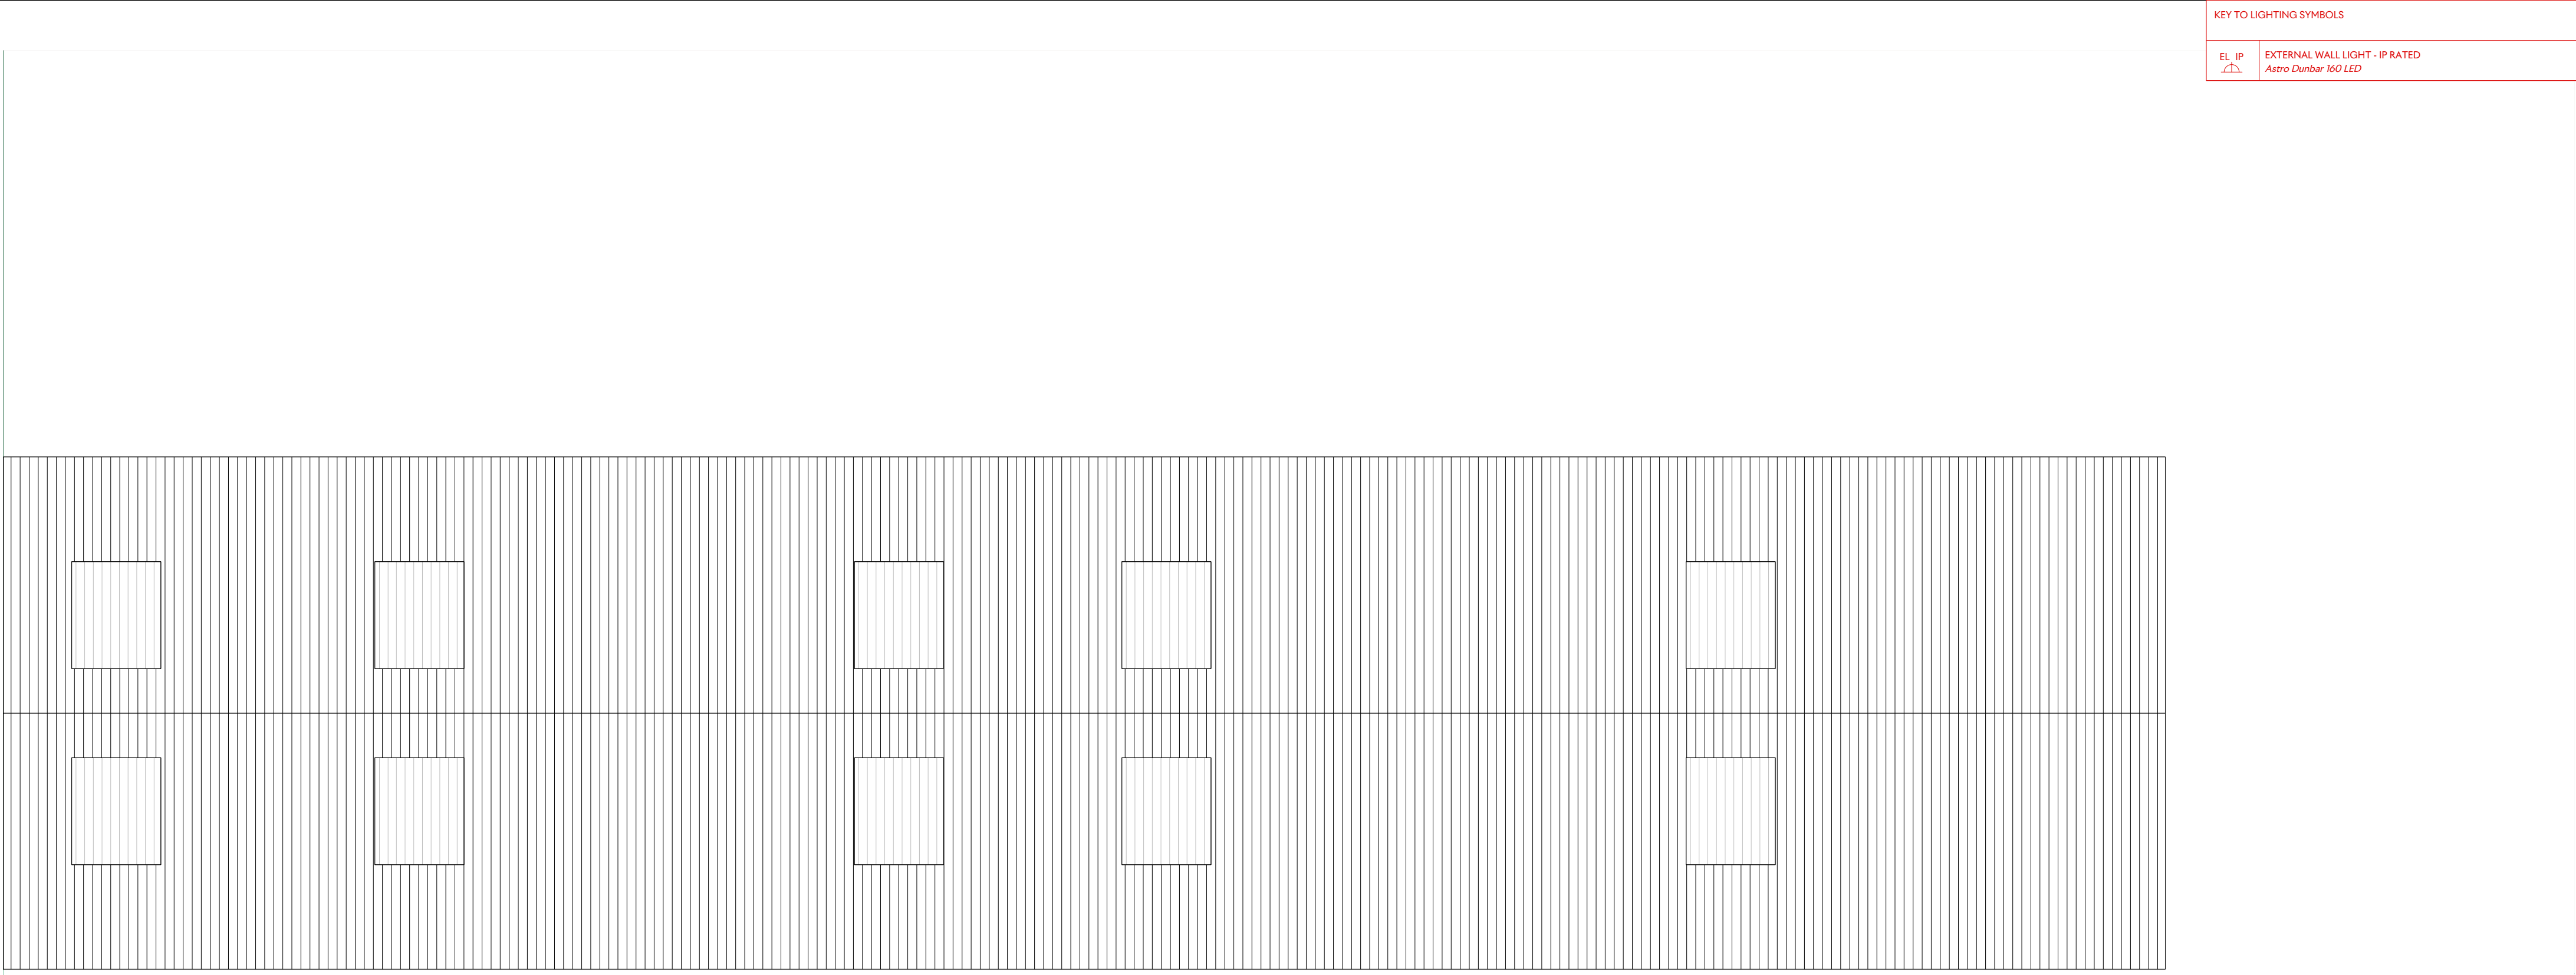


KEY TO LIGHTING SYMBOLS	
EL IP [Symbol]	EXTERNAL WALL LIGHT - IP RATED <i>Astro Dumbor 160 LED</i>

Workshop Roof Plan
Scale: 1:50

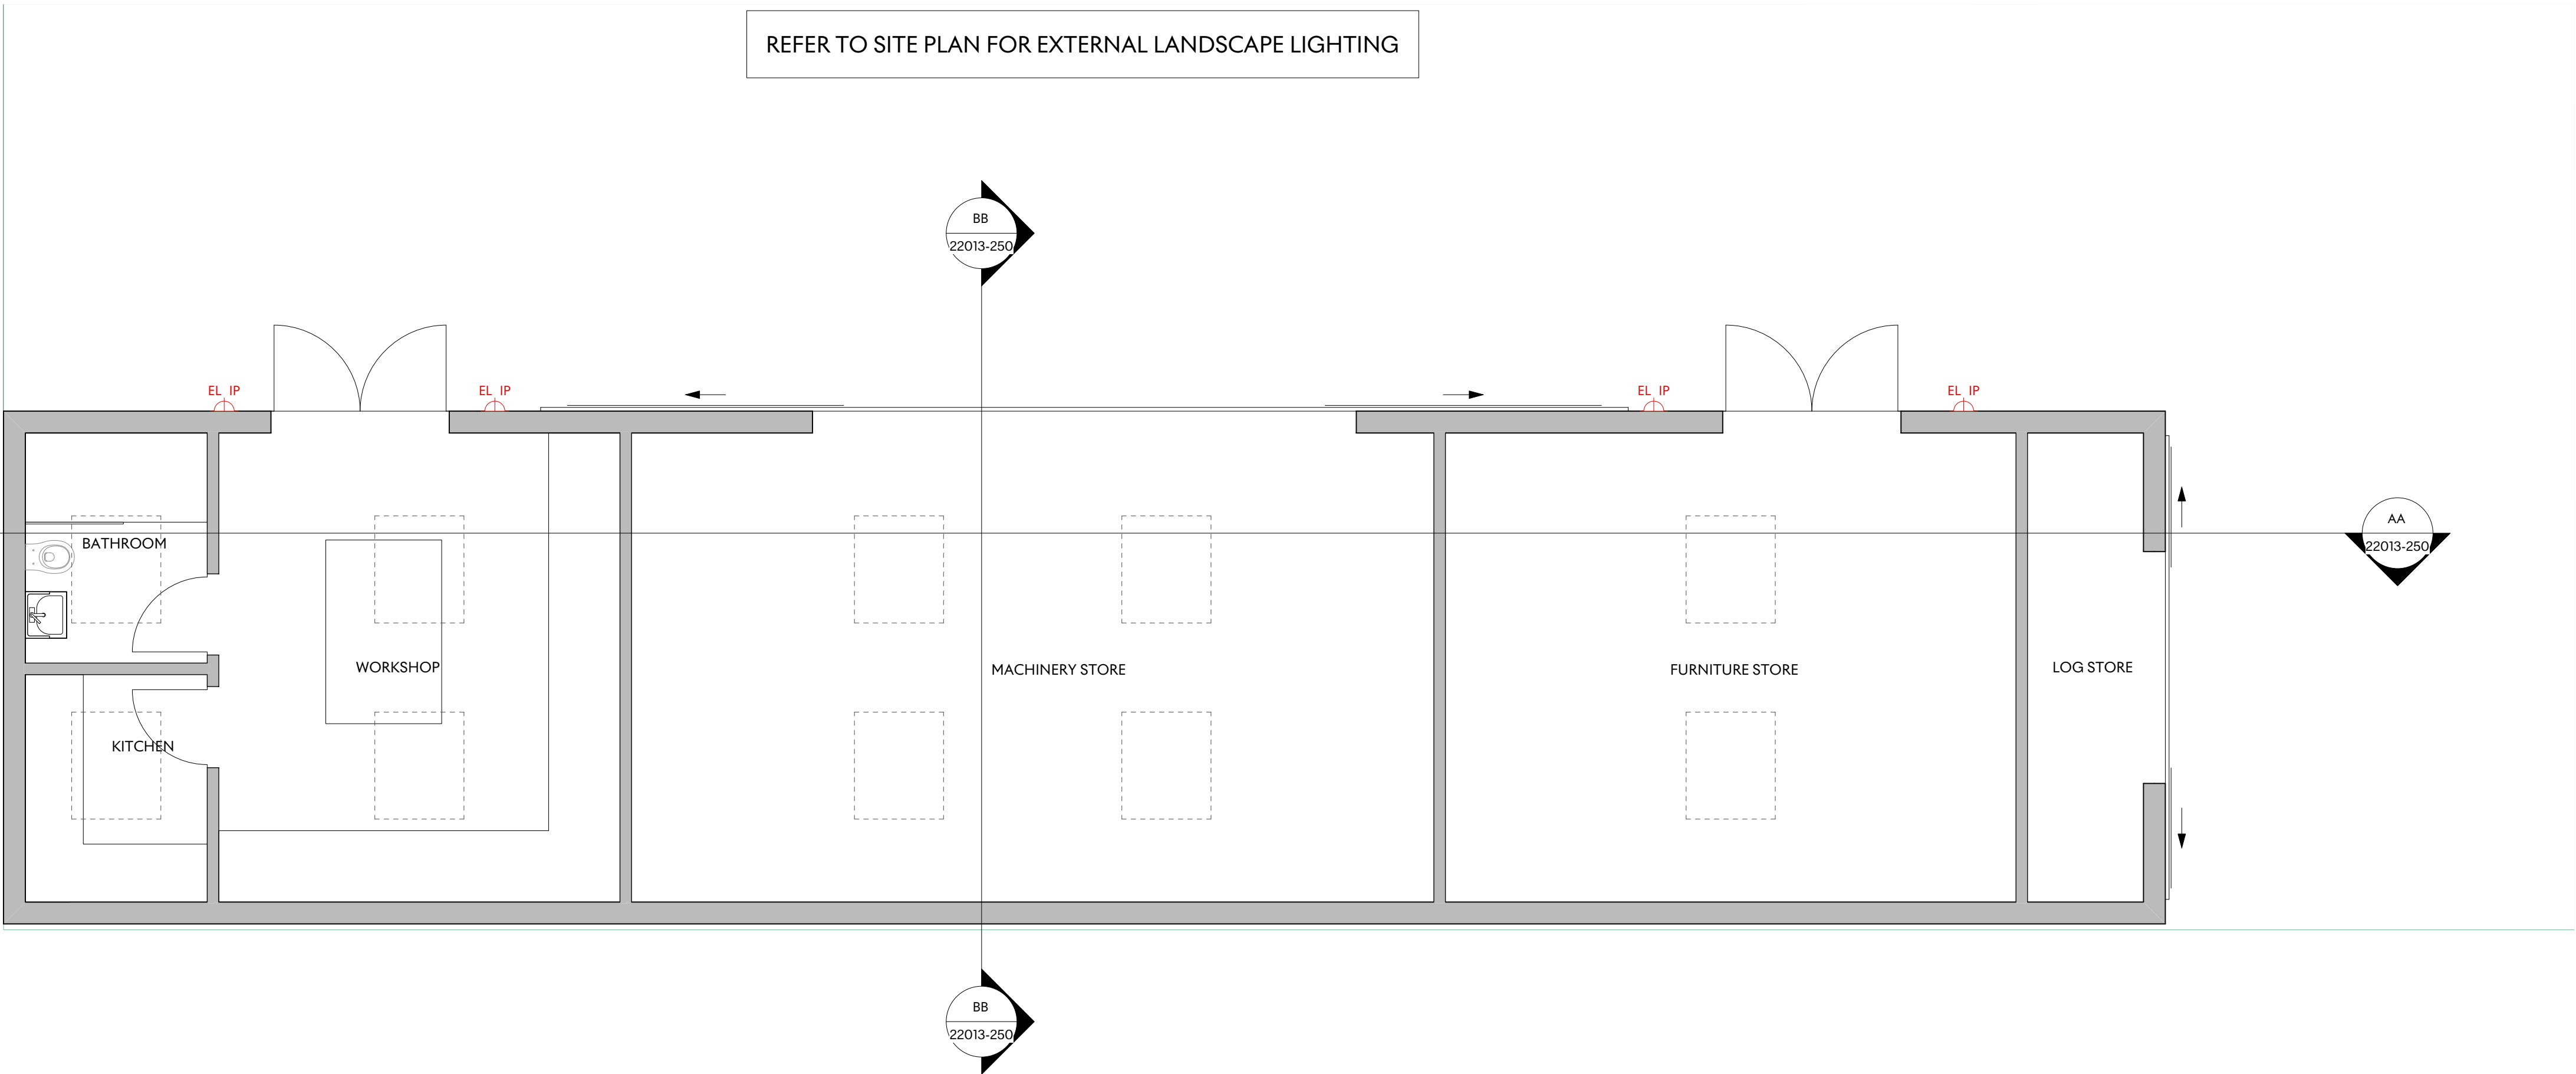

Workshop Ground Floor Plan
Scale: 1:50

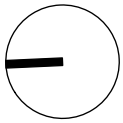

Notes

PLANNING

P 2 06/02/2026 ISSUED FOR PLANNING

P 1 14/07/23 ISSUED FOR PLANNING

Project

Standen House

Client

Adrian and Charlotte Mackenzie

Drawing Title

**Workshop
Proposed External Lighting Plan**

Scale Date Created

1:50 A1

Drawing Number
22013-151

Revision Date Revised
P2 06/02/2026

Drawn By Checked By
CB SD

Do not scale from drawing, all dimensions to be checked on site. Report omissions and discrepancies to the architect immediately.

**MICHAELIS
BOYD .**

Michaelis Boyd Associates
108 Palace Gardens Terrace
London W8 4RT

+44 (0)20 7221 1237
hello@michaelisboyd.com
michaelisboyd.com