


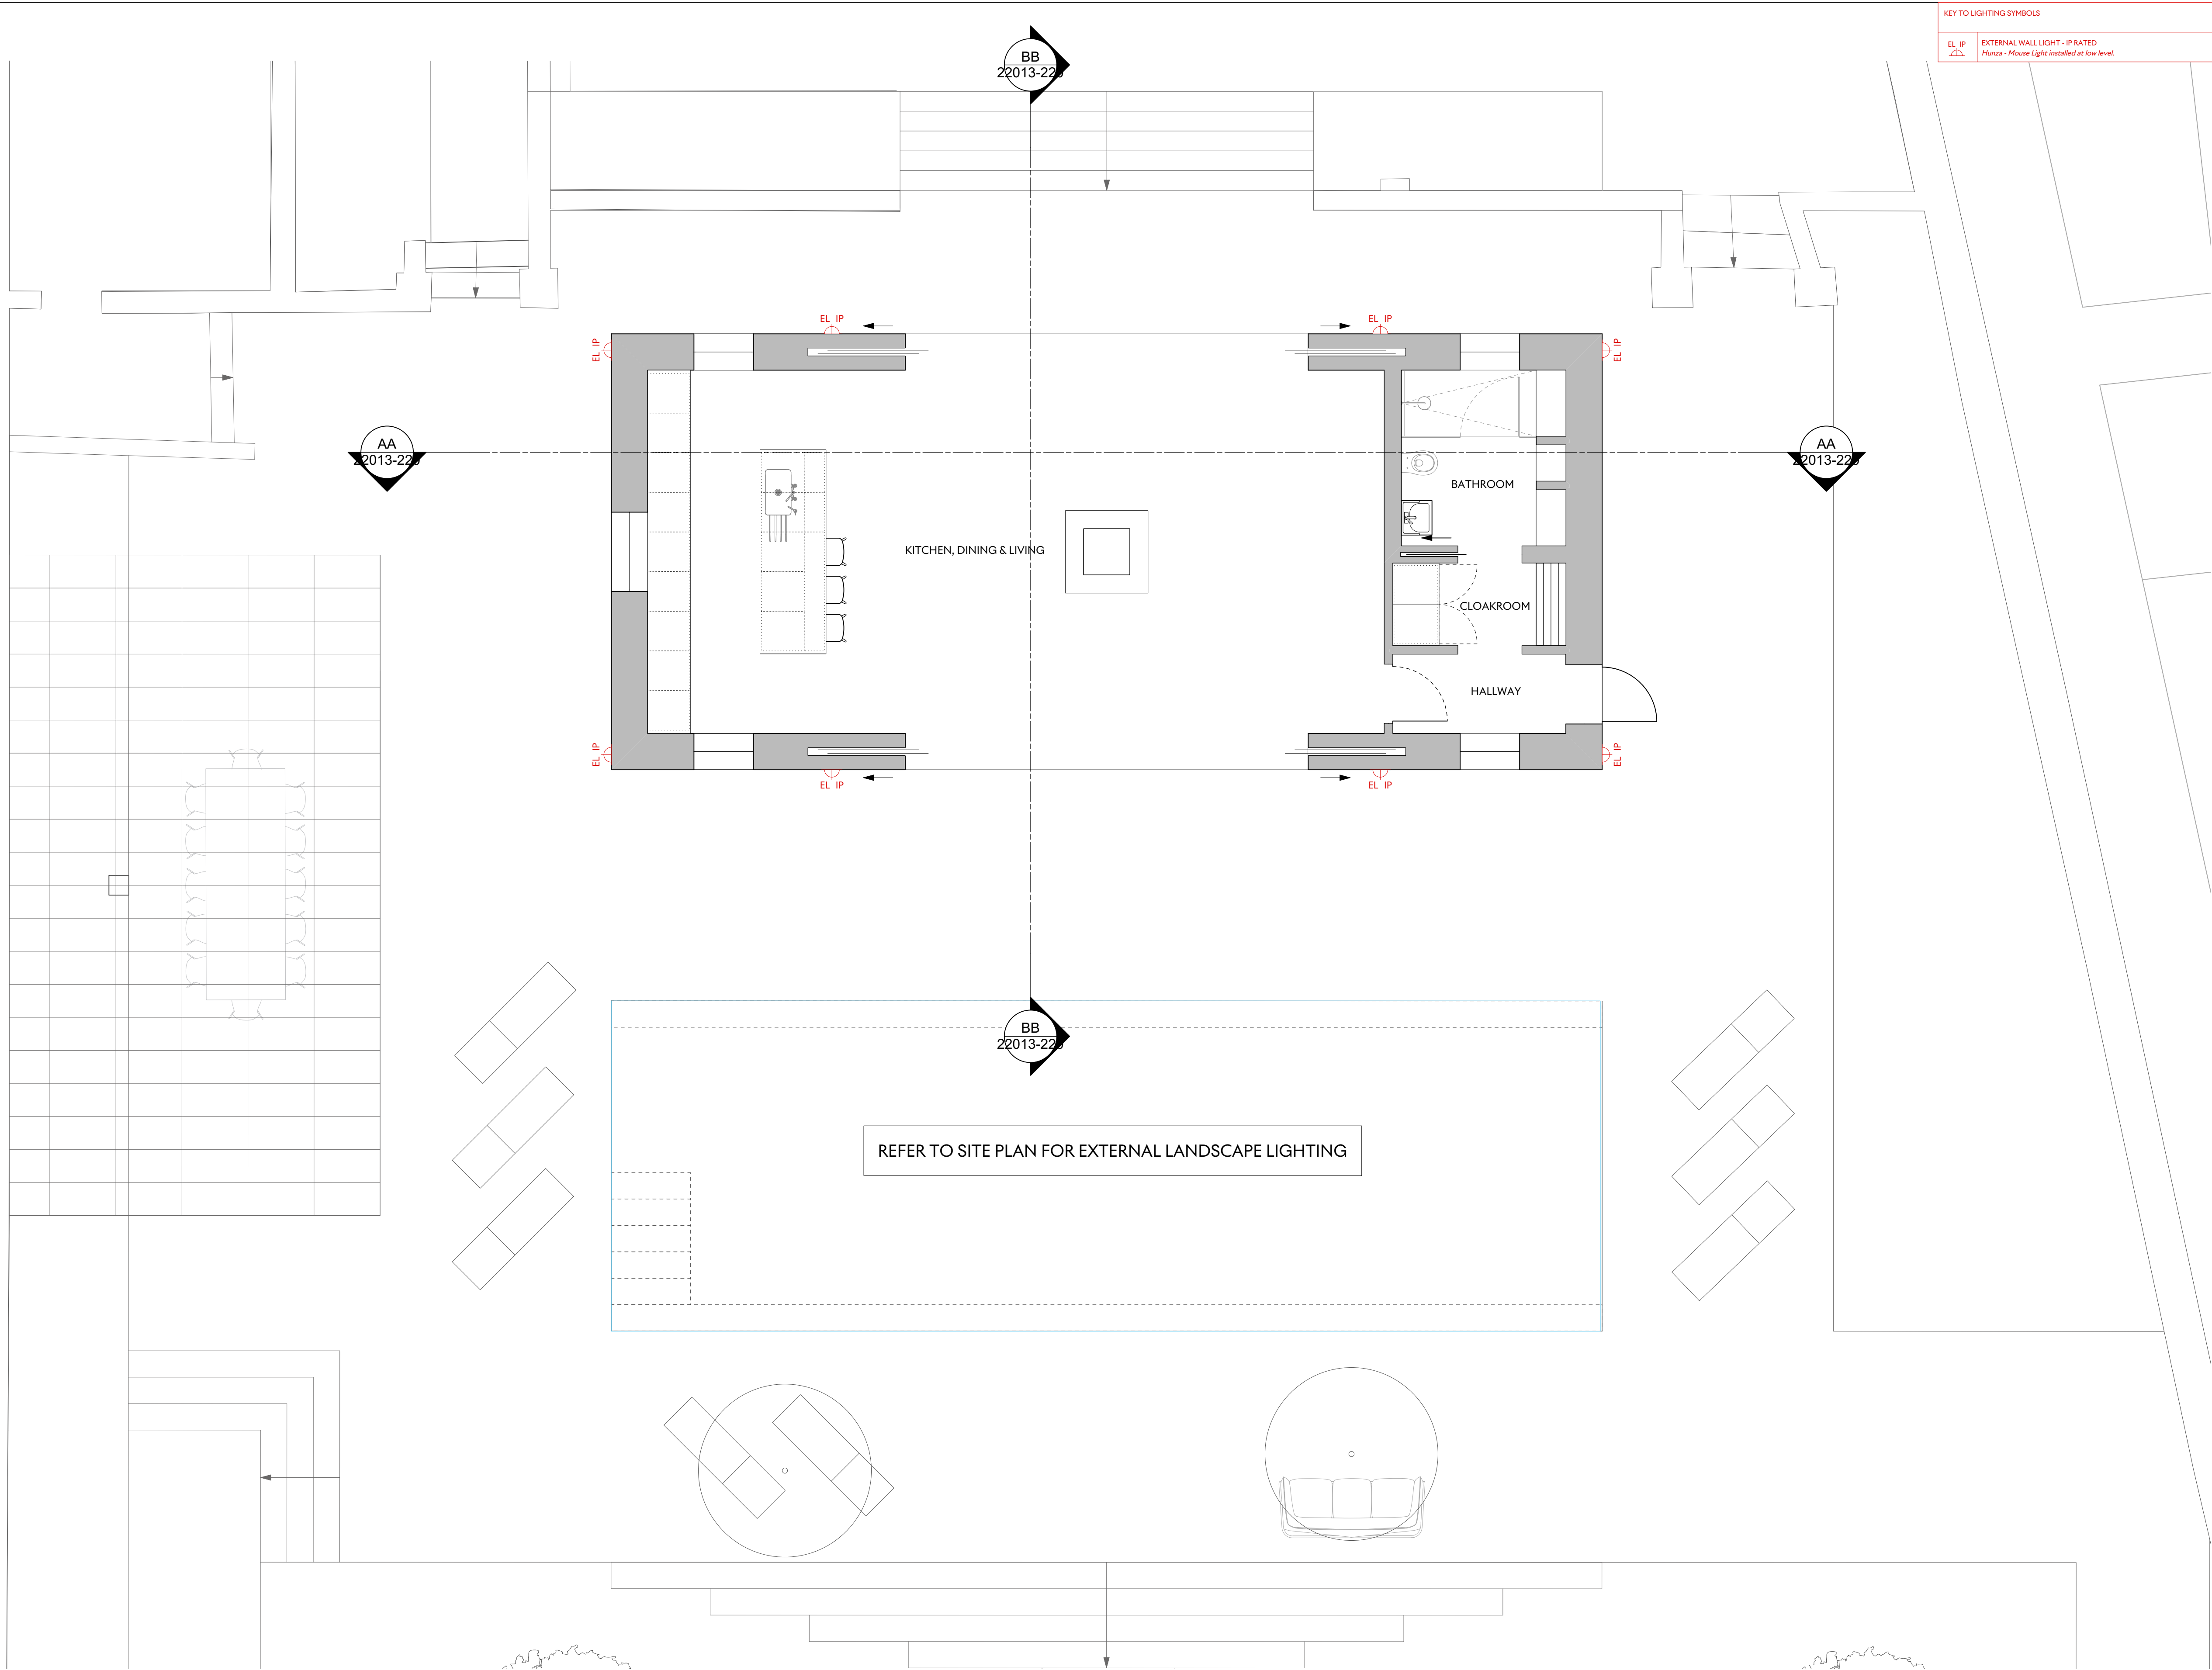

KEY TO LIGHTING SYMBOLS	
EL IP △	EXTERNAL WALL LIGHT - IP RATED <i>Fluza - Mouse Light installed at low level.</i>

Notes

PLANNING

P 1 06/02/26 ISSUED FOR PLANNING

Project
Standen House
Client
Adrian and Charlotte Mackenzie
Drawing Title
**Poolhouse
Proposed External Lighting Plan**

Scale
1:50
Date Created
A1

Drawing Number
22013-122

Revision
P1
Date Revised
06/02/26

Drawn By
CB
Checked By
SD

Do not scale from drawing, all dimensions to be checked on site. Report omissions and discrepancies to the architect immediately.

**MICHAELIS
BOYD .**

Michaelis Boyd Associates
108 Palace Gardens Terrace
London W8 4RT

+44 (0)20 7221 1237
hello@michaelisboyd.com
michaelisboyd.com

