


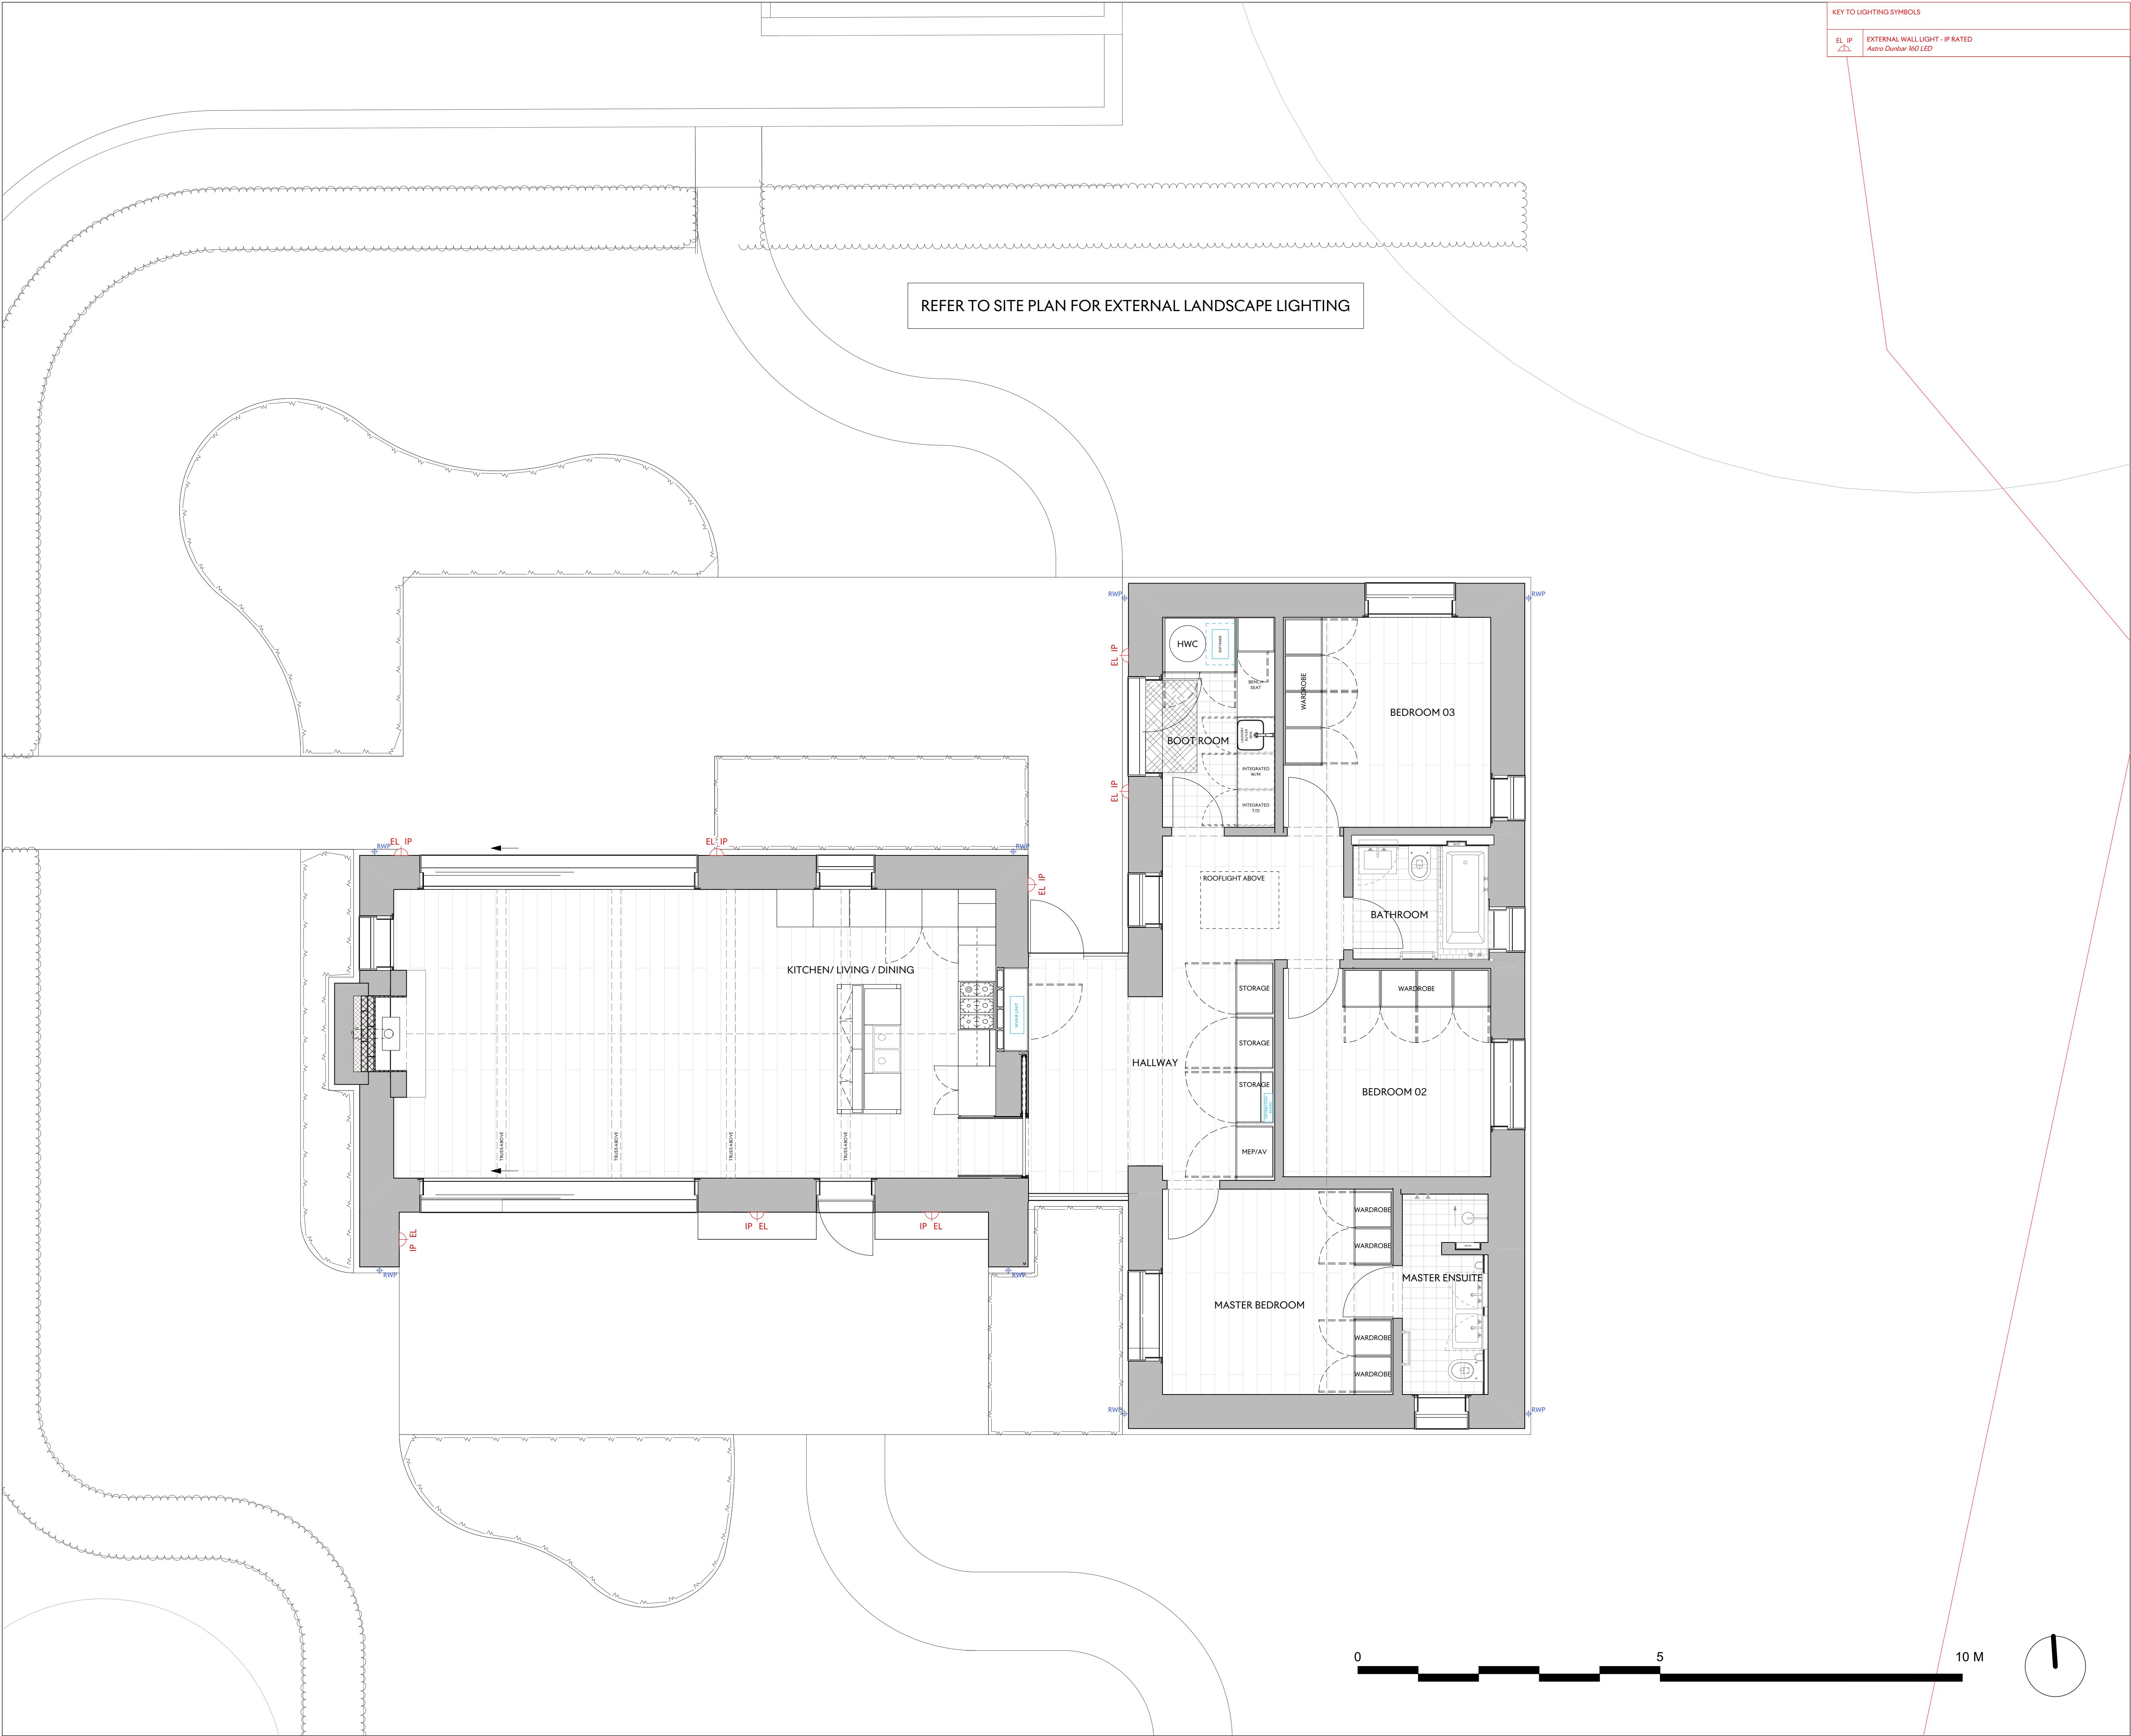

KEY TO LIGHTING SYMBOLS	
EL IP △	EXTERNAL WALL LIGHT - IP RATED <i>Astro Dumb 150 LED</i>

Notes

PLANNING

P 1 06/02/2026 ISSUED FOR PLANNING

Project
Standen House
Client
Adrian and Charlotte Mackenzie
Drawing Title
**Stable Cottage
Proposed External Lighting Plan**

Scale	Date Created
1:50	A1

Drawing Number
22013-SC-147

Revision	Date Revised
P1	06/02/2026

Drawn By	Checked By
CM	SD

Do not scale from drawing, all dimensions to be checked on site. Report omissions and discrepancies to the architect immediately.

**MICHAELIS
BOYD .**

Michaelis Boyd Associates
108 Palace Gardens Terrace
London W8 4RT

+44 (0)20 7221 1237
hello@michaelisboyd.com
michaelisboyd.com

