


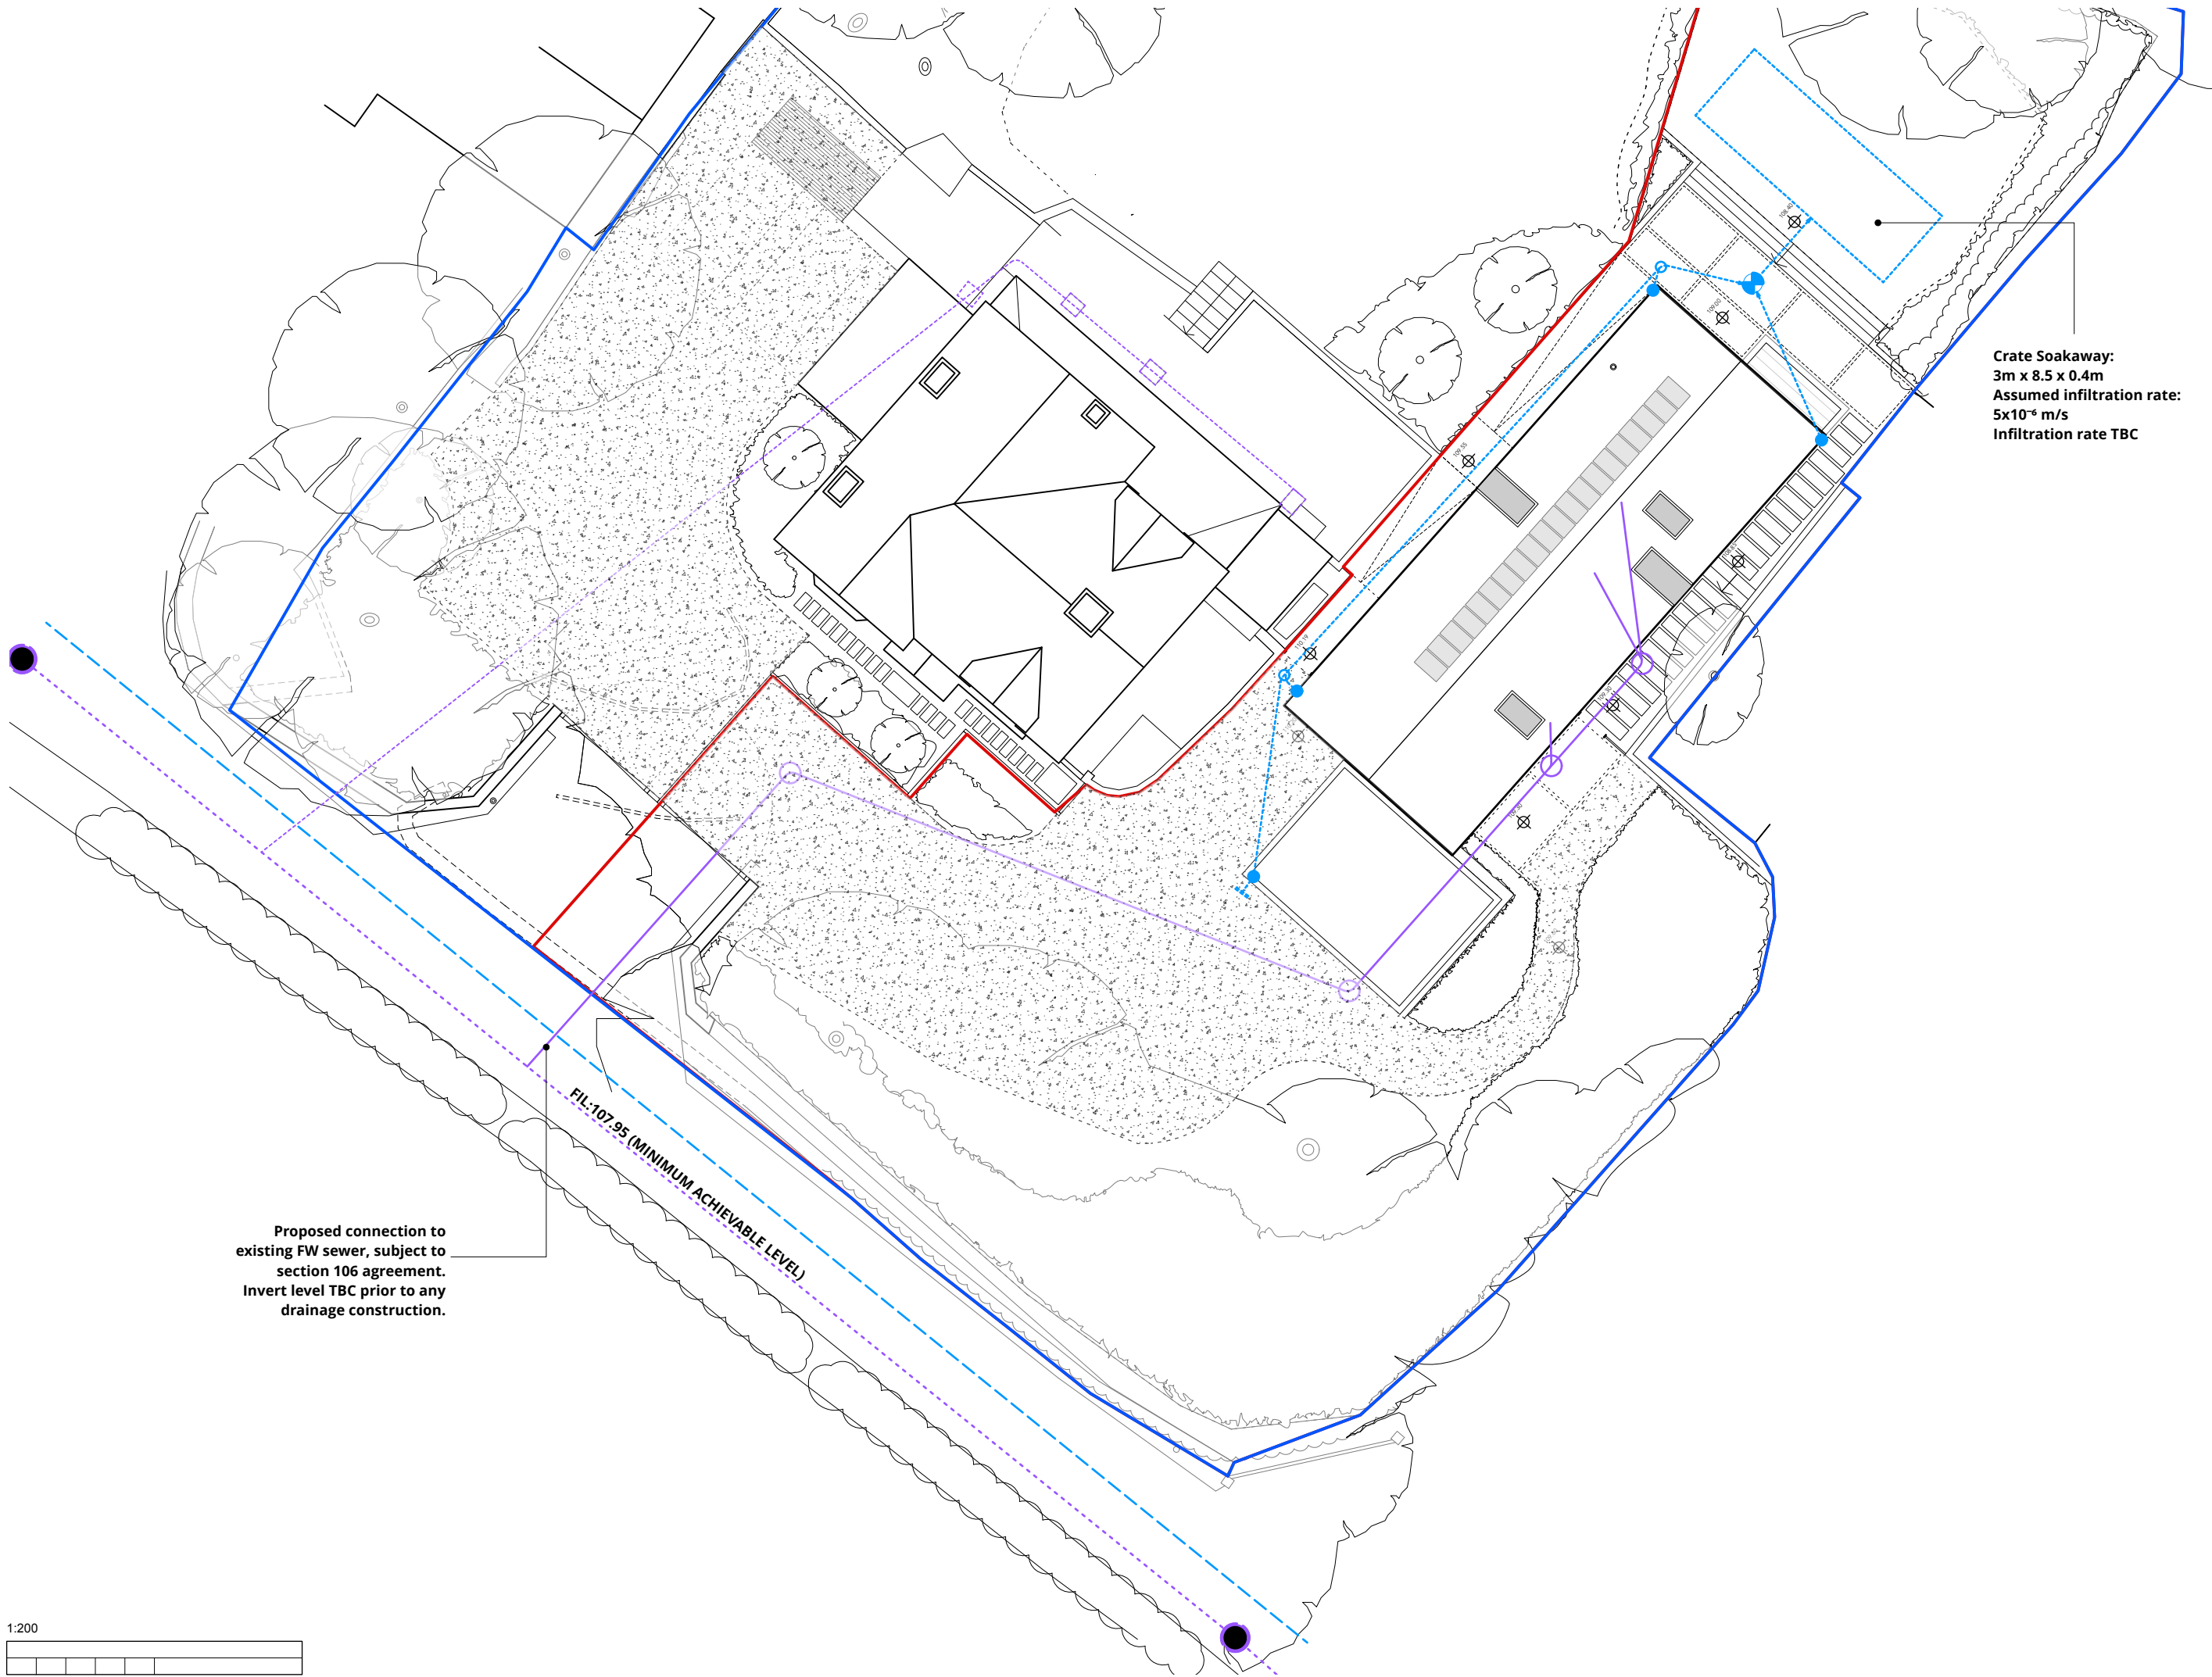

NOTES:

FOUL WATER:

- Existing Public Foul Water Sewer and Manhole
- Proposed 100mm FW drain and inspection chamber
- Existing 100mm FW drain and inspection chamber to be retained.
- SP BG

SURFACE WATER:

- Self Draining gravel surface
- SW Catchpit chamber
- 100mm SW drain and inspection chamber
- SW rodding eye
- RWP BG

NOTE: ALL INVERT LEVELS TO BE CONFIRMED ON SITE

P1 Issued for Planning	JH	02/02/2026	
#	DESCRIPTION	BY	DATE

PROPOSED Site Drainage Plan

JOB NO - DRAWING NO.	REV.
----------------------	------

2507 - 3 701	P1
---------------------	-----------

COPPICE DELL	
--------------	--

SCALE @ A3:	1:200
-------------	-------

LAST PLOT DATE:	02/02/2026
-----------------	------------

DRAWN BY:	JH
CHECKED BY:	XX

PLANNING



EN SPACE ARCHITECTS

