
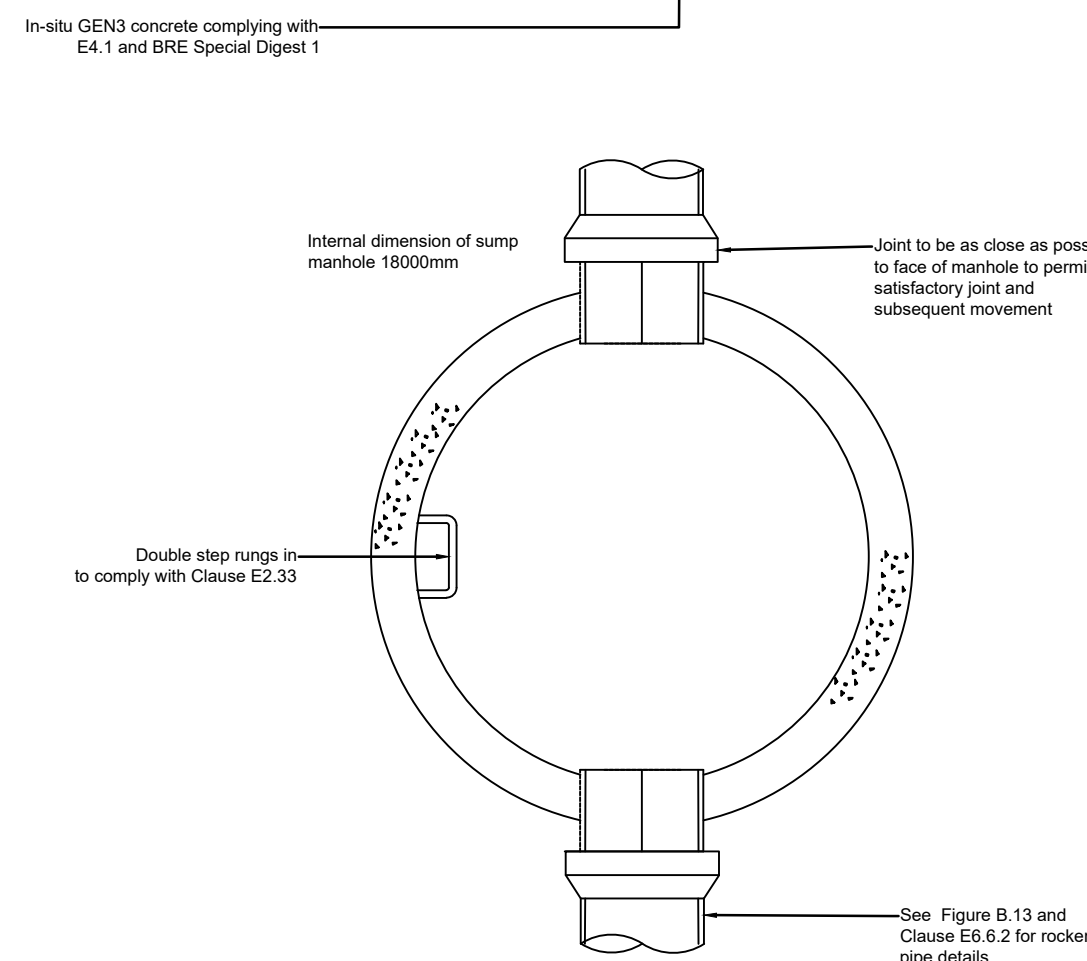
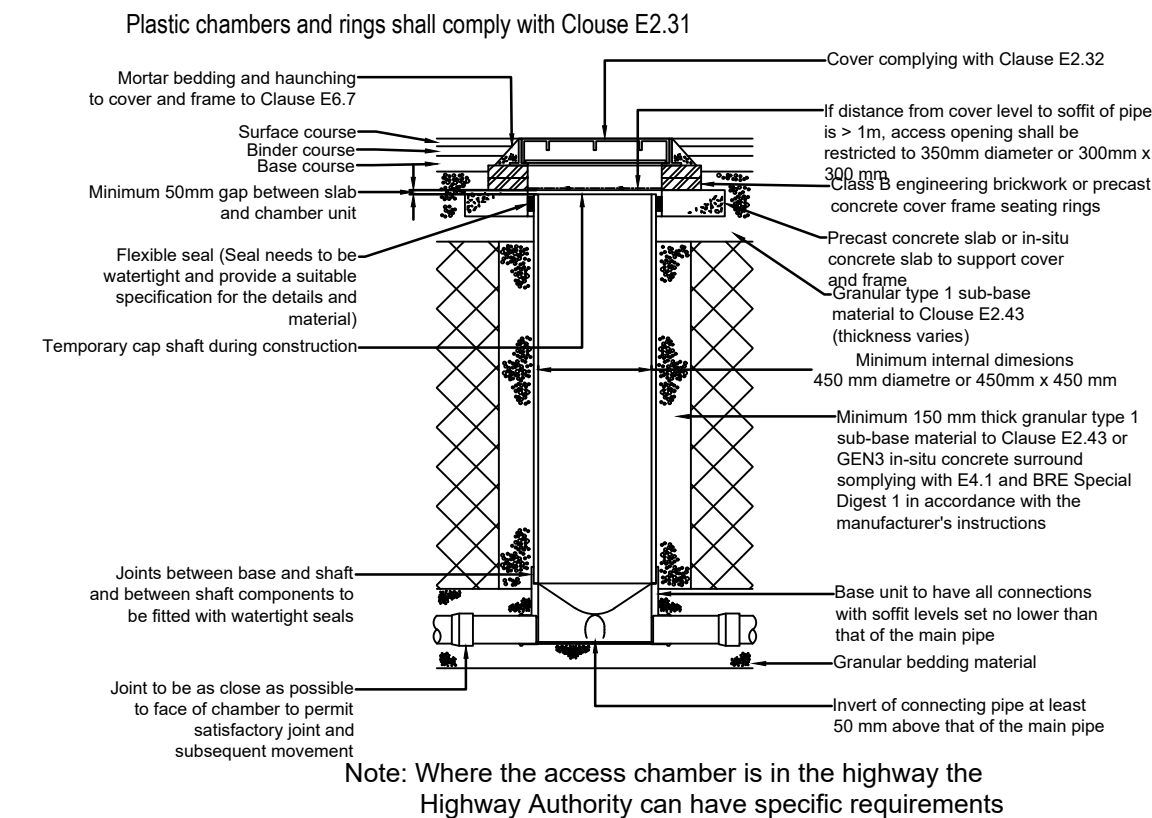
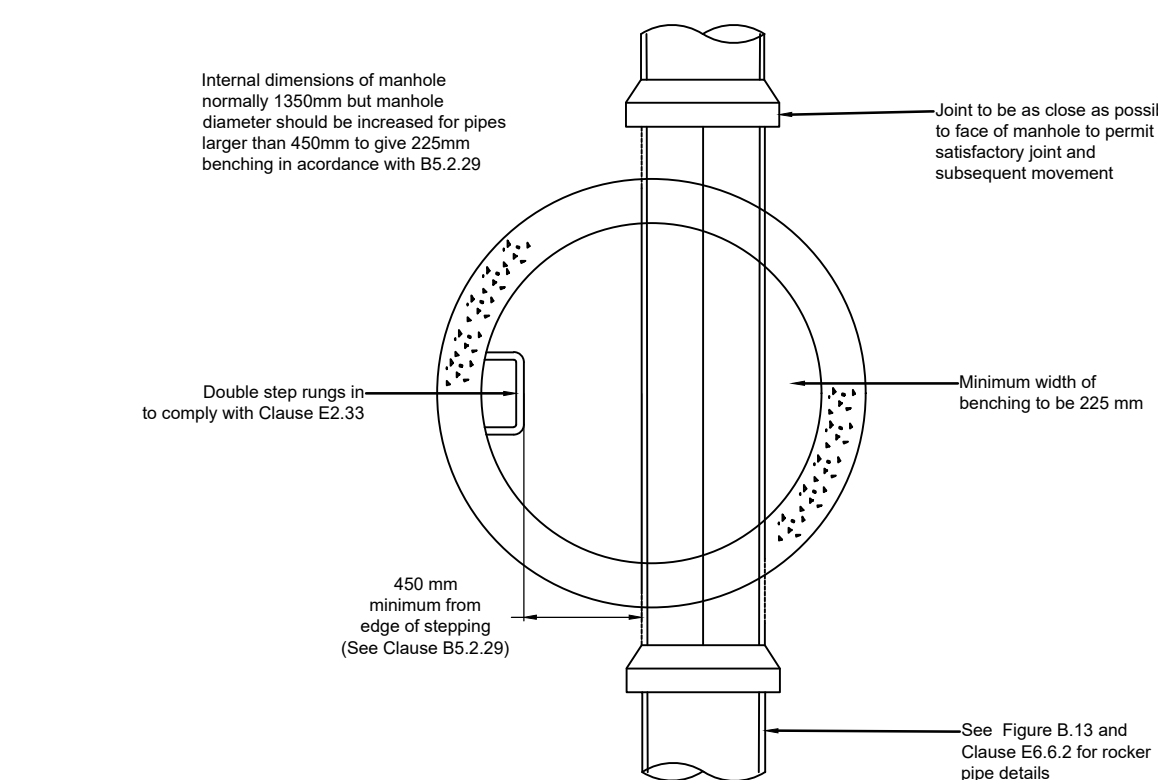
 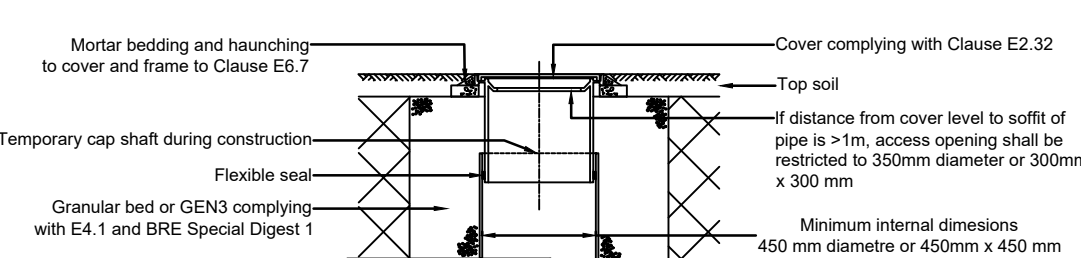

 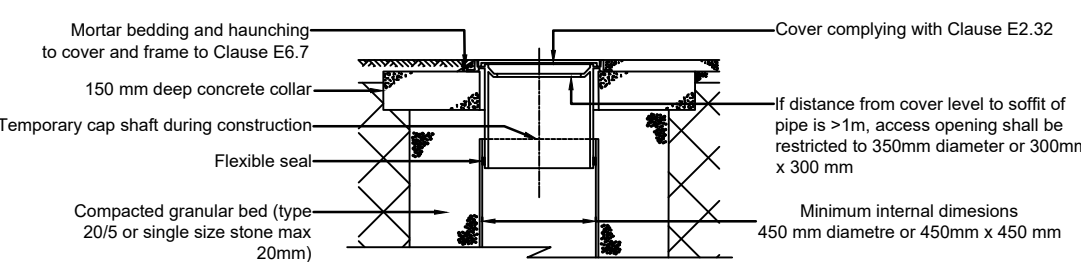

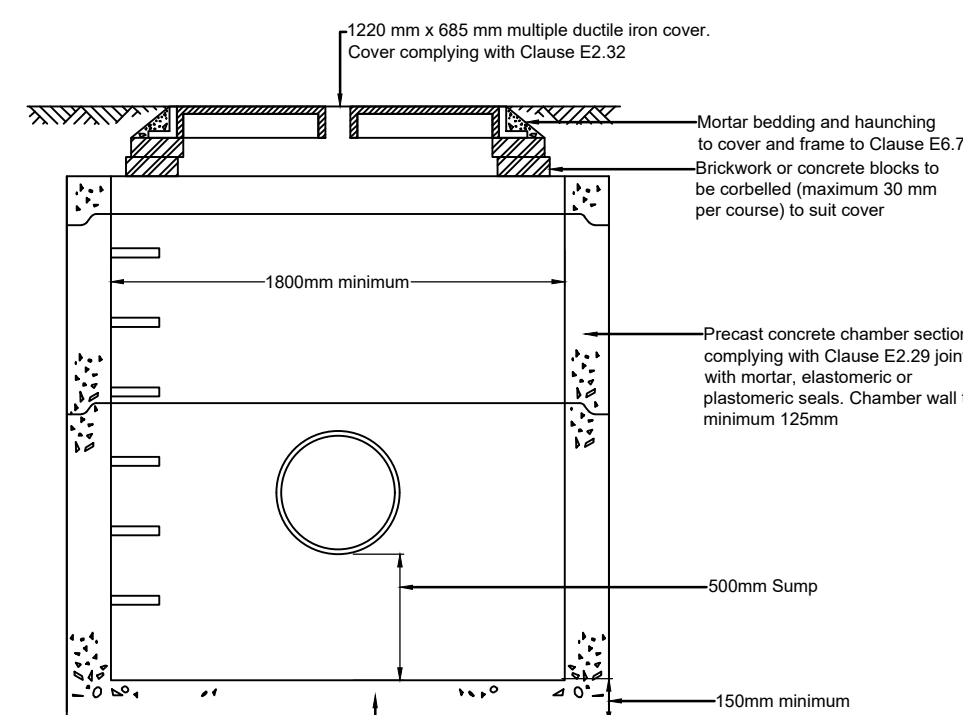
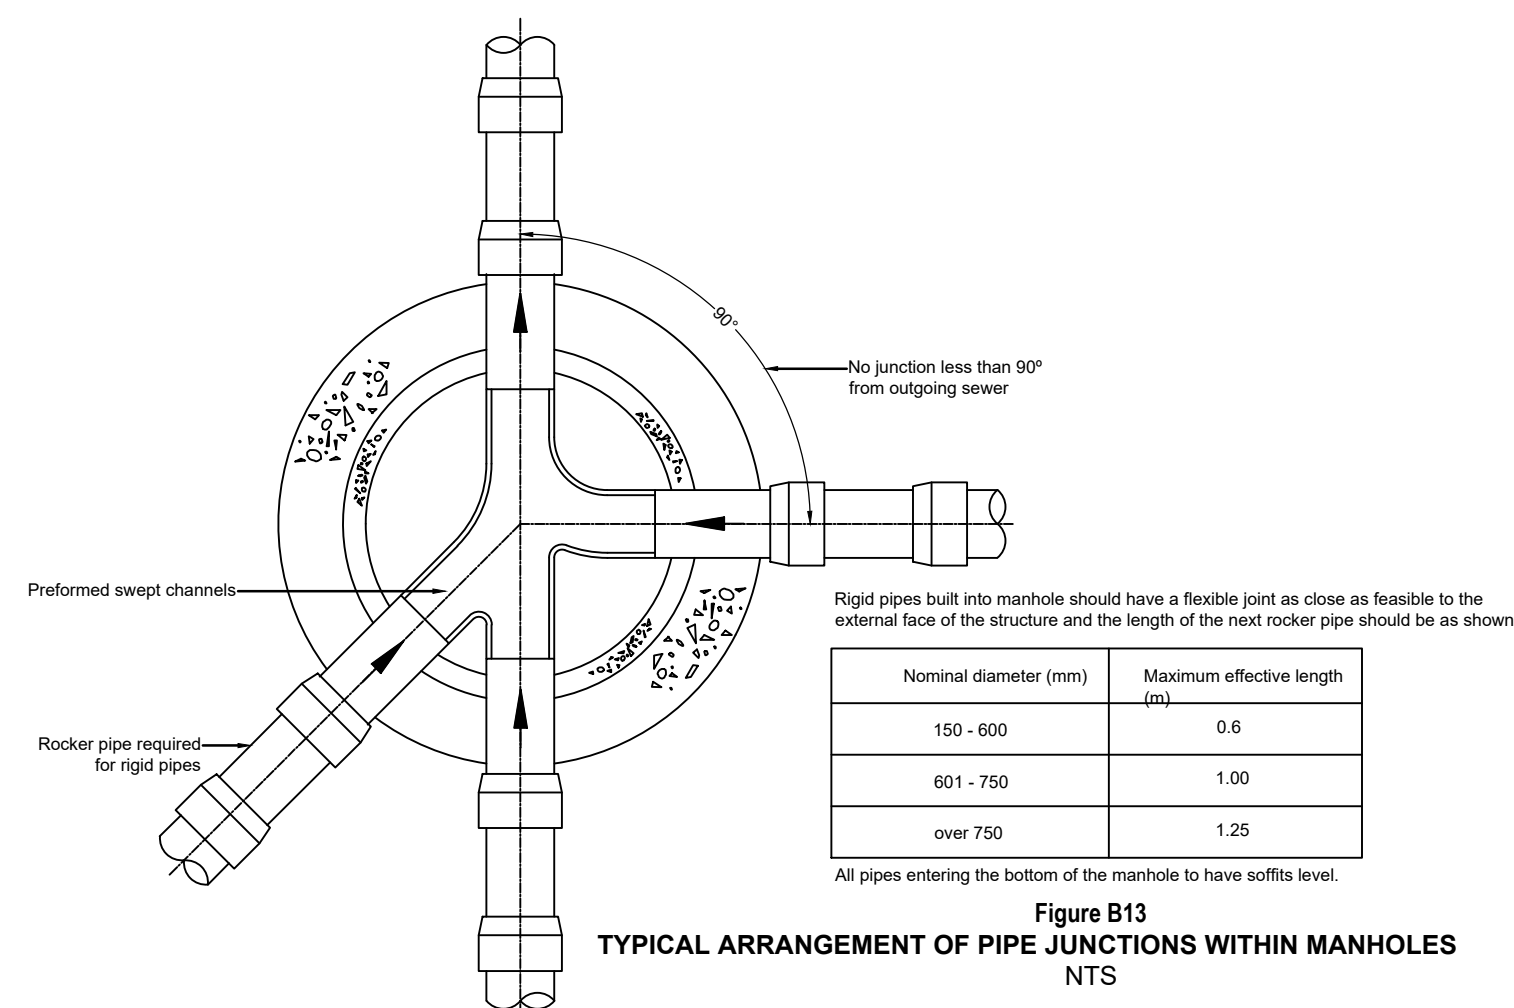
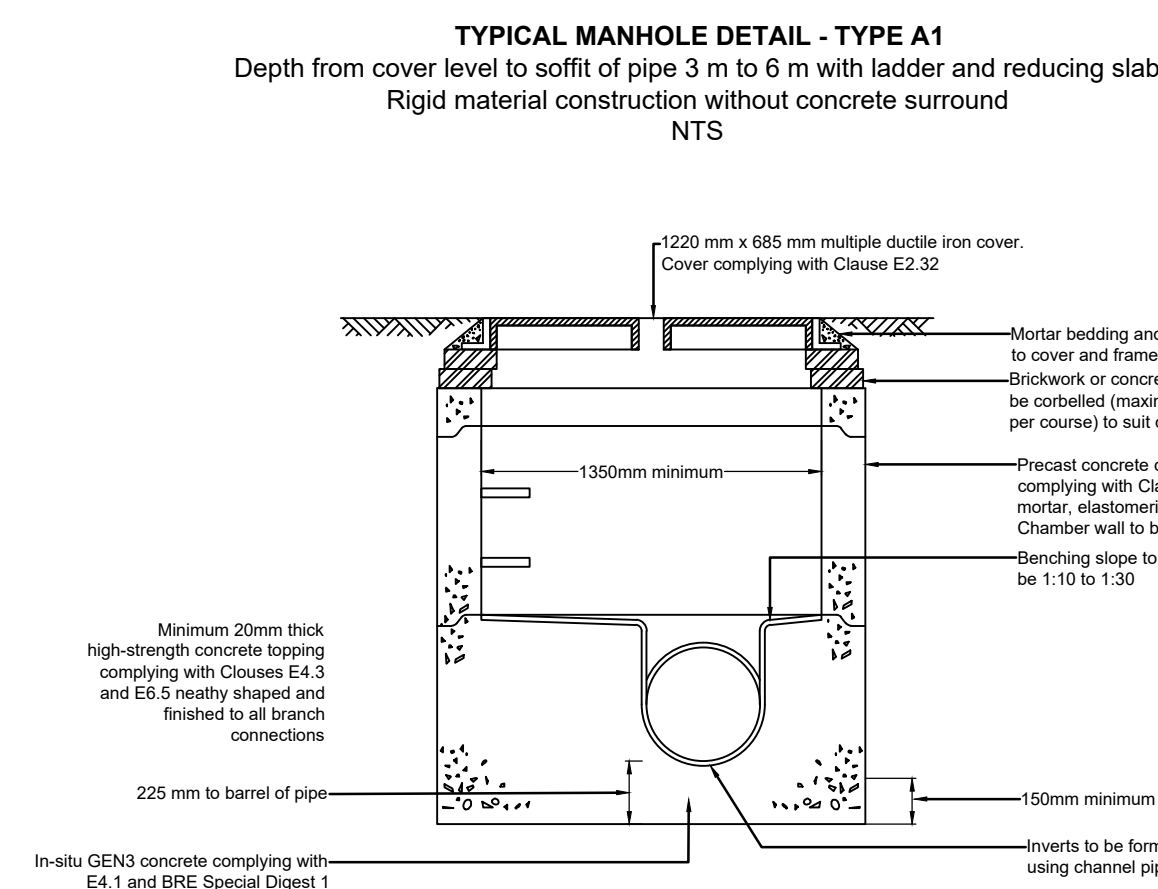
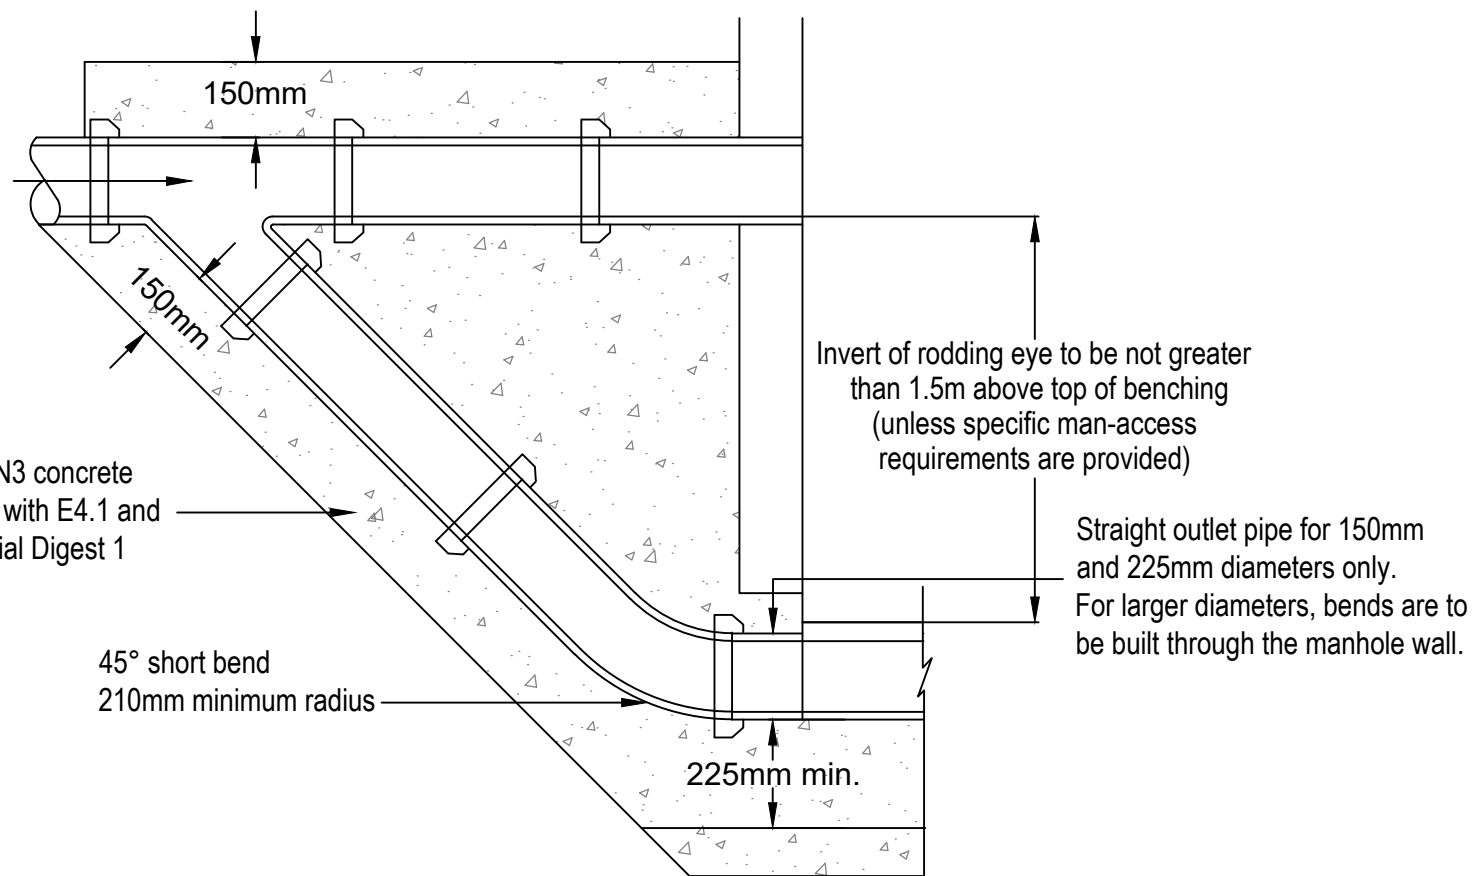
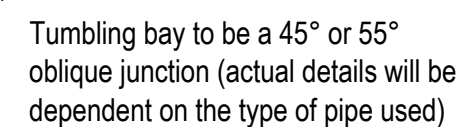
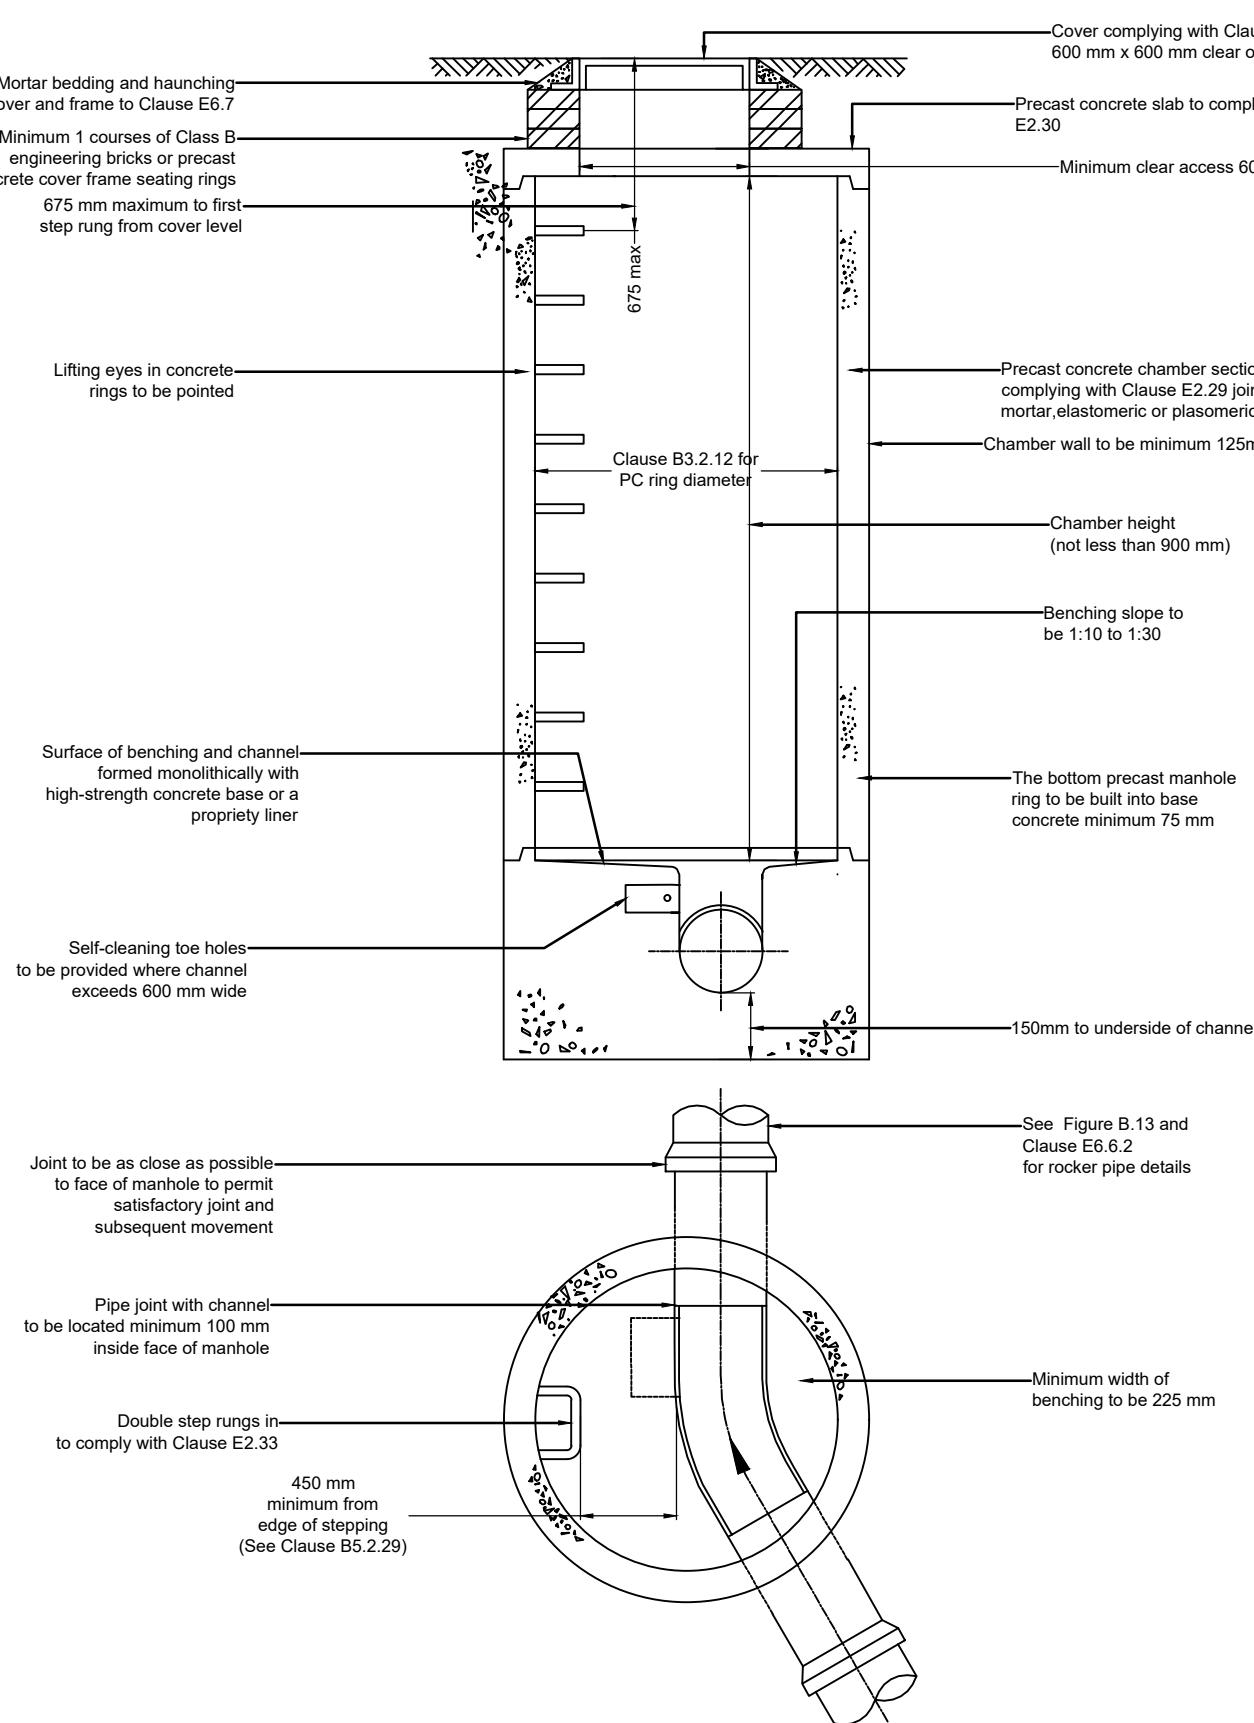
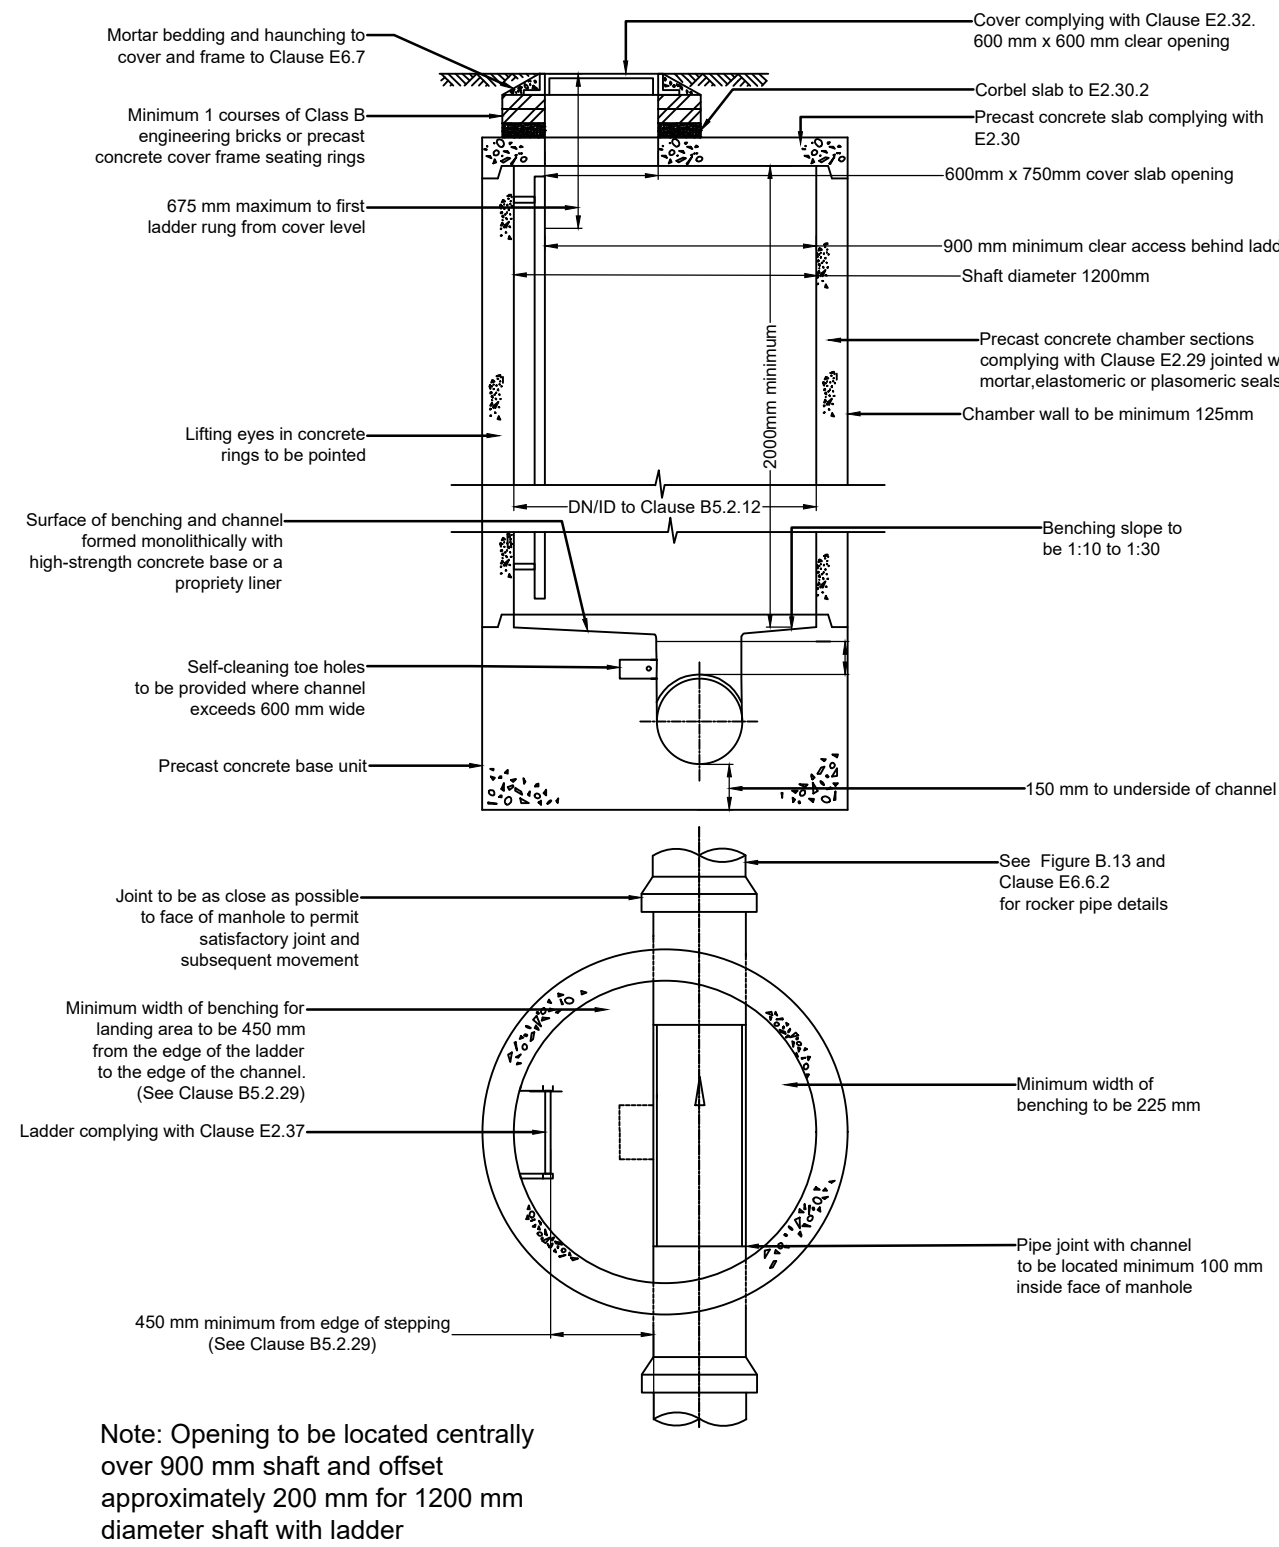


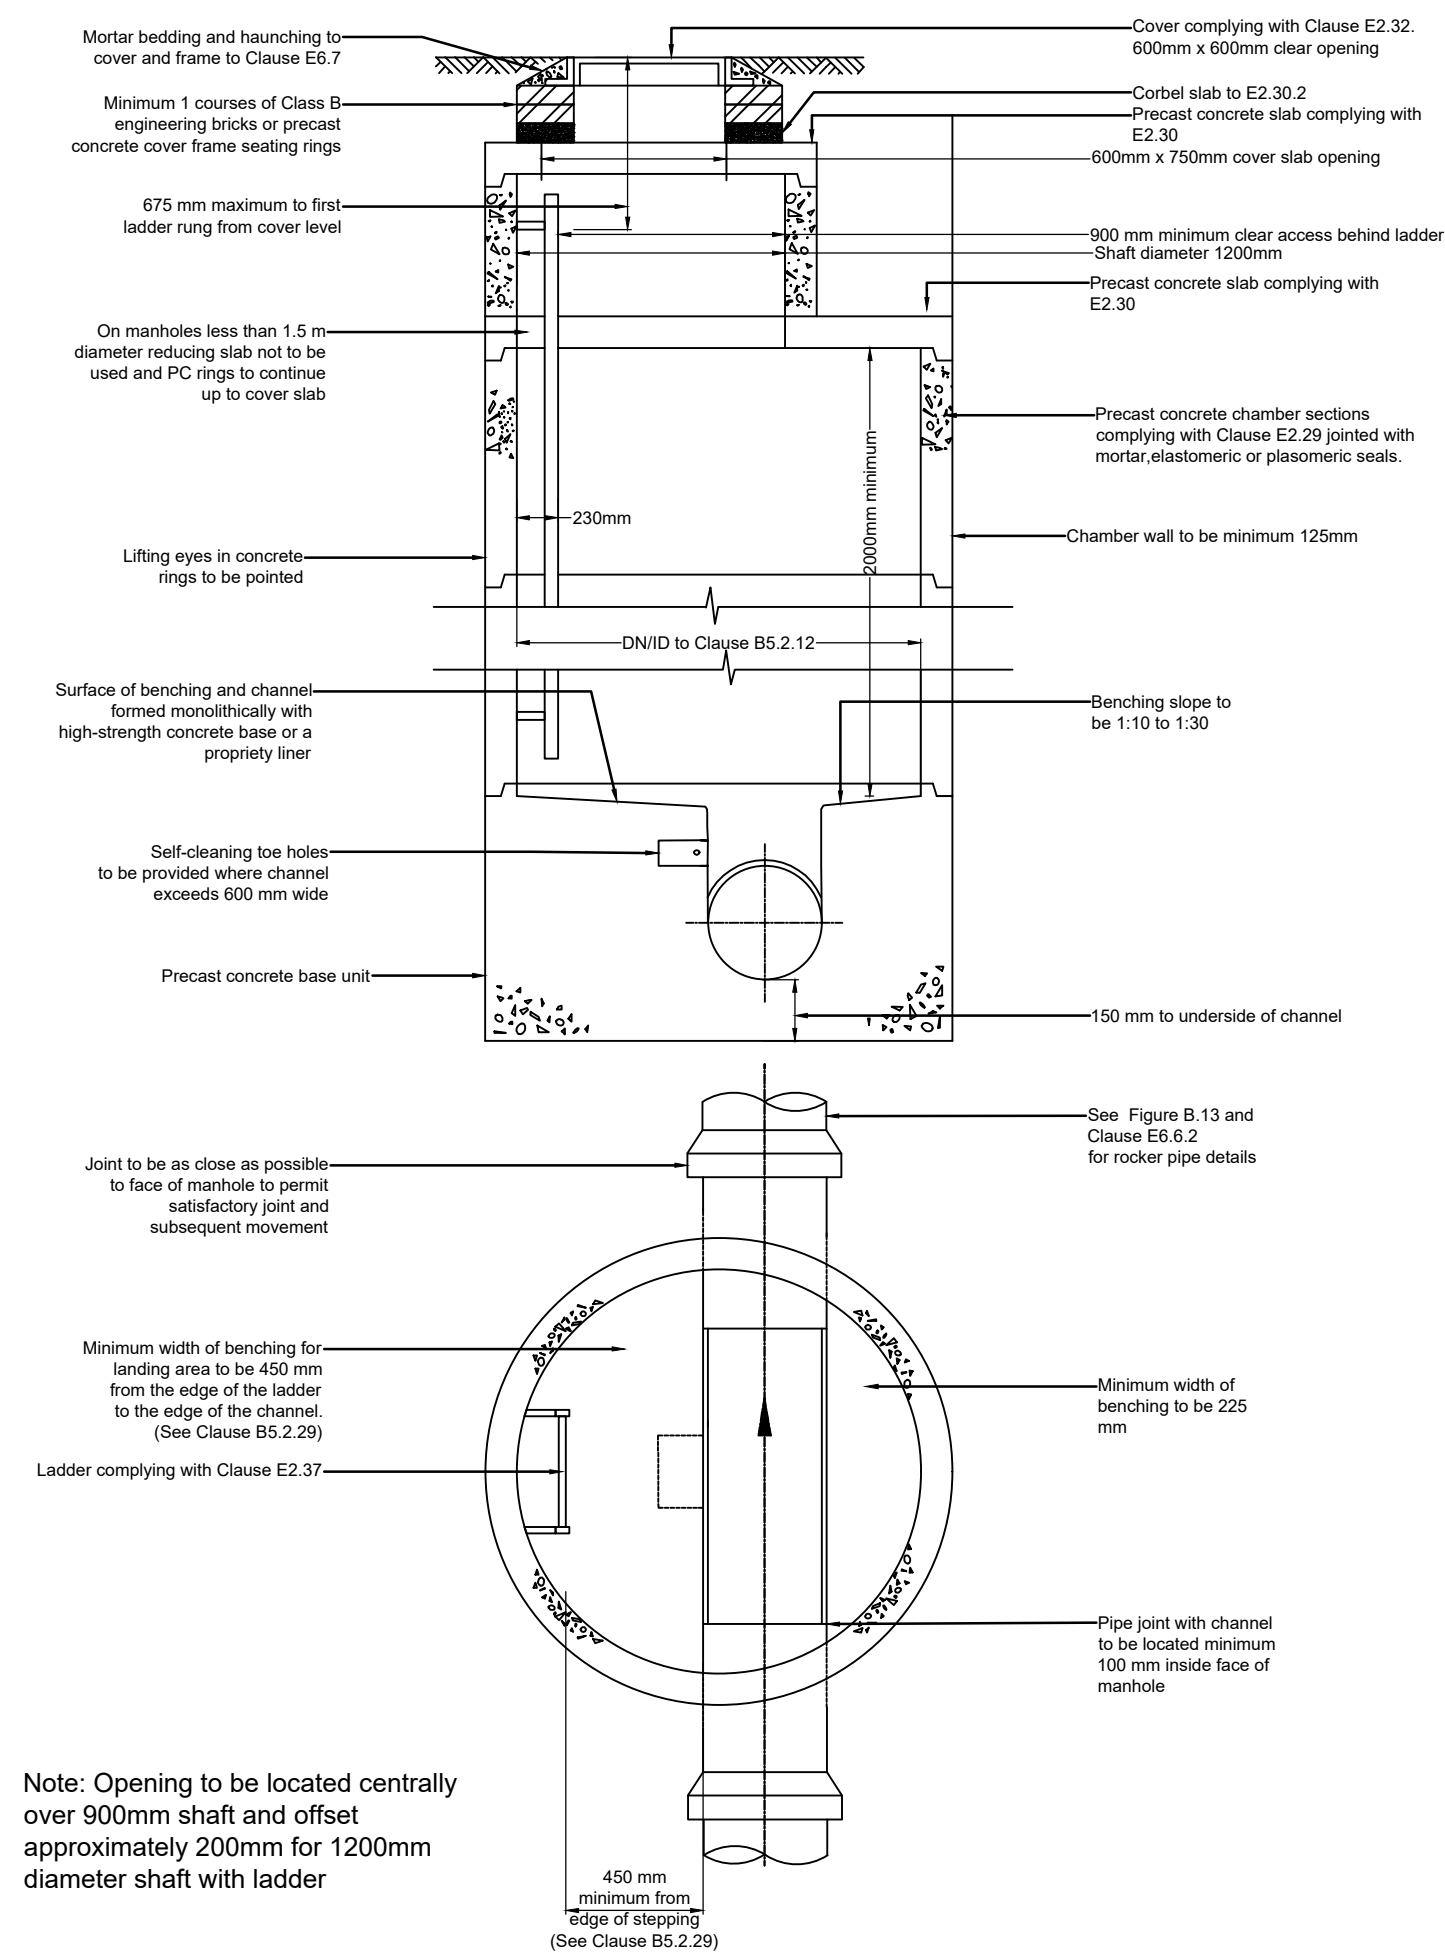

- ## Notes
1. Drainage to be constructed in accordance with the Code for Adoption Design and Construction Guidance Sewerage Sector Guidance Appendix C, Building Regulations 2010 Approved Document Part H and BS EN 752: 2017.
 2. To be read in conjunction with Jubb Consulting Engineers Drainage layout drawings.
 3. Manholes to be Type A, Type B or Type C manholes, Inspection Chambers to be Type D or Type E in accordance with the standard detail requirements and manhole schedules. Inspection chambers to be 450mmØ or 600mm diameter as required by inlet arrangement.
 4. Covers to be Class D400 in carriageways, hard shoulders and parking areas including driveways, B125 in footways and landscaped areas where no vehicular access is possible in accordance with BS EN 124, BS 7903 and HA 104/09.
 5. Pipework to be PVCU Class SN8 to WIS 4-35-01, Vitrified Clay Class FN28 to BS EN 295-1 or Concrete Class 160 to BS EN 1916 and BS 5911-1 for pipework 100mmØ and over 300mmØ.
 6. All drainage for pipe sizes from 150mmØ upto and including 300mmØ to be laid using Wavin UltraRib BS EN 13476-3.
 7. Typical Type C manhole to be used for HydroBrake Flow Control manholes FC1-FC4 refer to manhole schedules.
 2. Any drainage constructed prior to S104 technical approval by Wessex Water is not at risk and is subject to alterations.

P4	13.02.26	Typical details A1, A2 and B updated to be Rigid Material Construction. Ramped backdrop detail added to suit locsa requirements.	EPH	WH
P3	11.11.25	Sump Manhole detail added for manholes SMH1, 50A, 50B, 100, 149 & SMH 150 to suit locsa requirements.	SH	EPH
P2	23.10.25	Note added to confirm Type C manhole for flow control chambers FC1-FC4.	S.H	EPH
P1	12.06.25	Preliminary Issue.	S.H	K.M

Rev	Date	Description	By	Apvd
-----	------	-------------	----	------

PROJECT:
VICTORIA ROAD
WARMINSTER

TITLE:
DRAINAGE CONSTRUCTION DETAILS
SHEET 1

CLIENT:
KEEPMOAT HOMES LTD

SCALE@A1:
NTS

PROJECT REF:
24233

DRAWING No:
24233-JUB-ZZ-XX-DR-C-510

REV:
P4

Revision Referencing
P = Preliminary A = Approval T = Tender C = Construction