


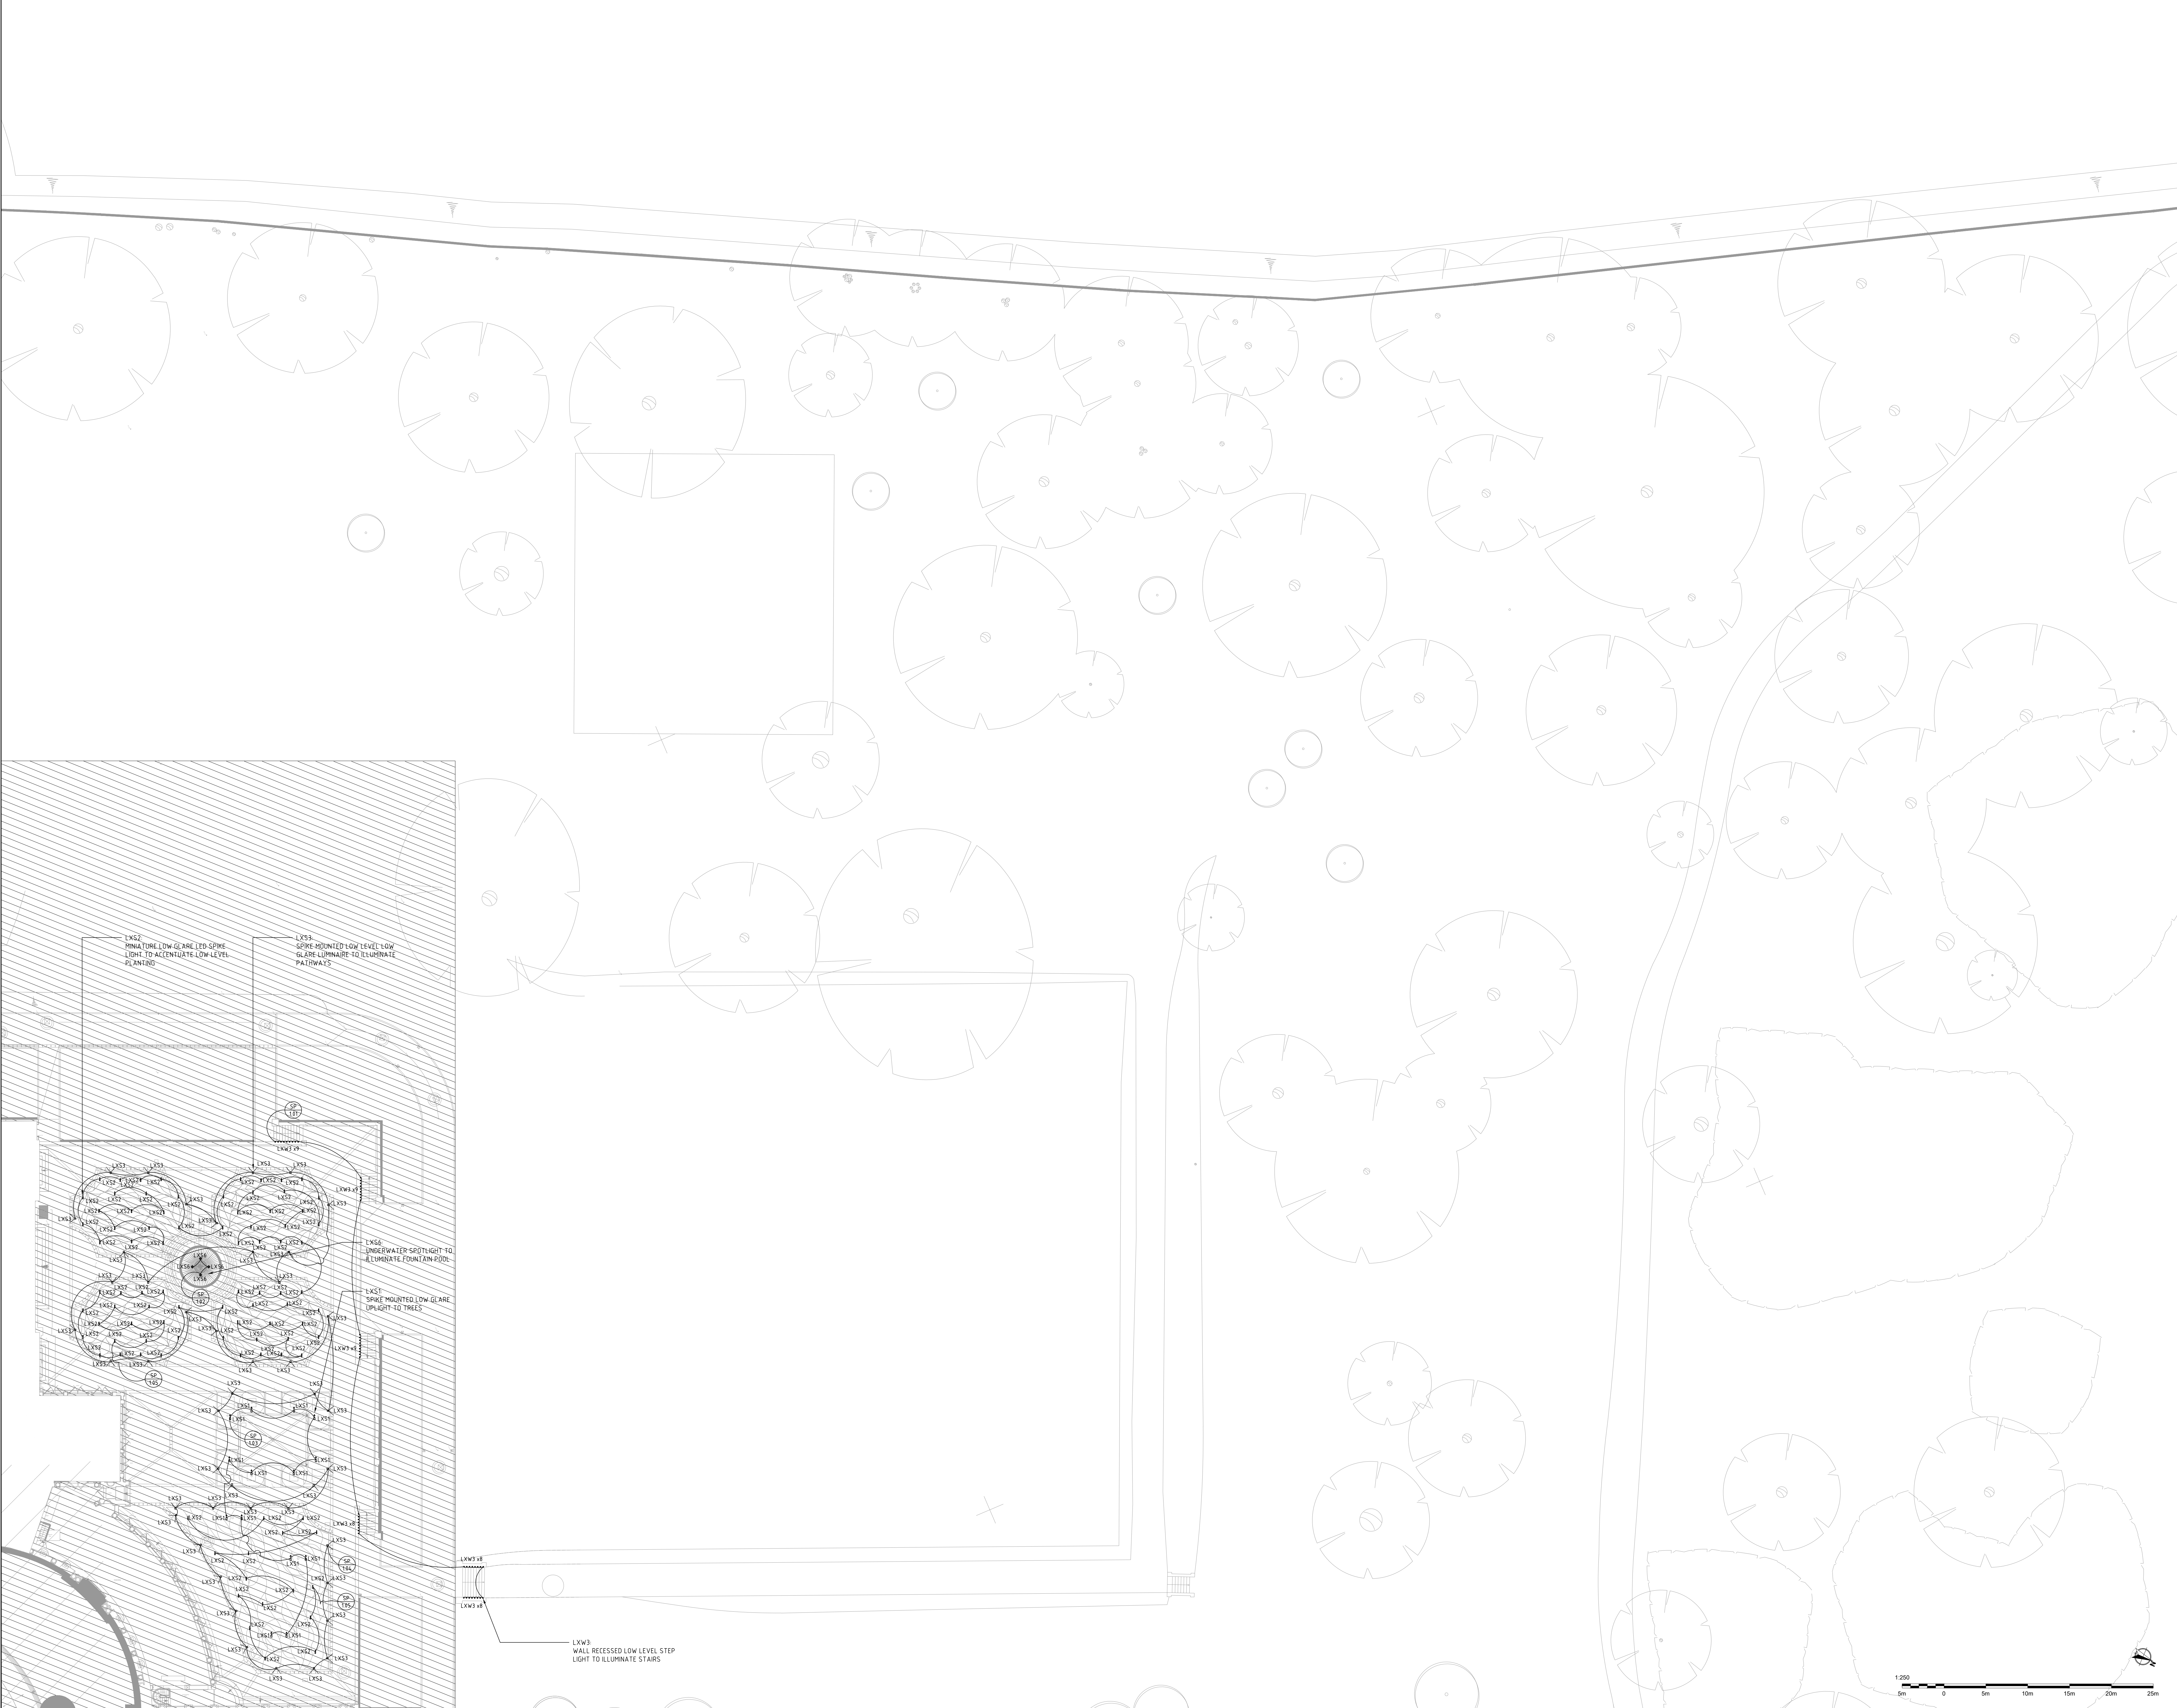

LIGHTING NOTES:

R

D1

Indicates lighting control area

D1

Indicates lighting control channel

D1

Indicates luminaire type

1.

Refer to appropriate dpa luminaire and lighting control schedules for further details.

2.

Scaled dimensions should not be taken from this drawing. All dimensions to be checked on-site.

3.

Where appropriate refer to associated lighting detail drawings for the exact location of luminaires.

4.

All equipment supplied by the installing contractor shall comply with the relevant EN, BS, CE & IEC regulations, and be capable of installation in accordance with the current edition of the IEE wiring regulations. All equipment shall comply with all other statutory and local authority requirements.

5.

Installing Contractor to ensure that all transformers and control gear are compatible with the lighting control system dimmers.

6.

Final locations of lighting control plates, manual sliders and dimmer racks to be co-ordinated with Architect and M&E consultant. Exact locations to be agreed on-site and approved by client.

7.

Emergency lighting system and signage by others.

KEY PLAN:

LUMINAIRE SYMBOLS:

	Linear LED luminaire
	Spike mounted linear LED luminaire
	Spike mounted spotlight
	Spike mounted spotlight
	Spike mounted spotlight
	Tree mounted projector luminaire
	Spike mounted spotlight
	Under water spotlight
	In-ground uplight
	Under water uplight
	Wall mounted luminaire
	Wall recessed floor washer
	Under water wall recessed floor washer

LUMINAIRE REFERENCES:

LXL1	Concealed linear lighting for balustrade
XL19	Spike mounted linear to walled garden
LXS1	Spike mounted spotlight to tree canopies
LXS2	Spike mounted spotlight for small planters
LXS3	Spike mounted spotlight for path lighting
LXS4	Spike mounted spotlight to tree canopies
LXS5	Tree mounted projector for moon lighting
LXS6	Under water spotlight for water fountain
LX01	Inground recessed luminaire for boundary wall
LX02	Under water spotlight for water fountain
LXW1	Wall mounted luminaire for general lighting
LXW2	Wall recessed floor washer for step lighting
LXW3	Wall recessed floor washer for step lighting
LXW4	Under water wall recessed floor washer

First Issue: For Planning

AKR

03/03/2026

Revision:

Description:

By:

Date:

dpa

lighting consultants London

Studio 208 Langside

House 11

Margate Road

London, SE1 1EN, UK

Telephone +44 (0) 20 314 4300

Email london@dpalighting.com

Project:

TOTTENHAM HOUSE

Drawing Title:

LANDSCAPE LIGHTING LAYOUT
SHEET 9 OF 9
SUNKEN LAWN

Scale:

1:250@A0

AKR

03/03/2026

110751A_LP_LS_09

00

Copyright and lighting consultants London. To be used for planning purposes only. Any detail or dimensional conflicts should be referred to the lighting consultants London for resolution.