


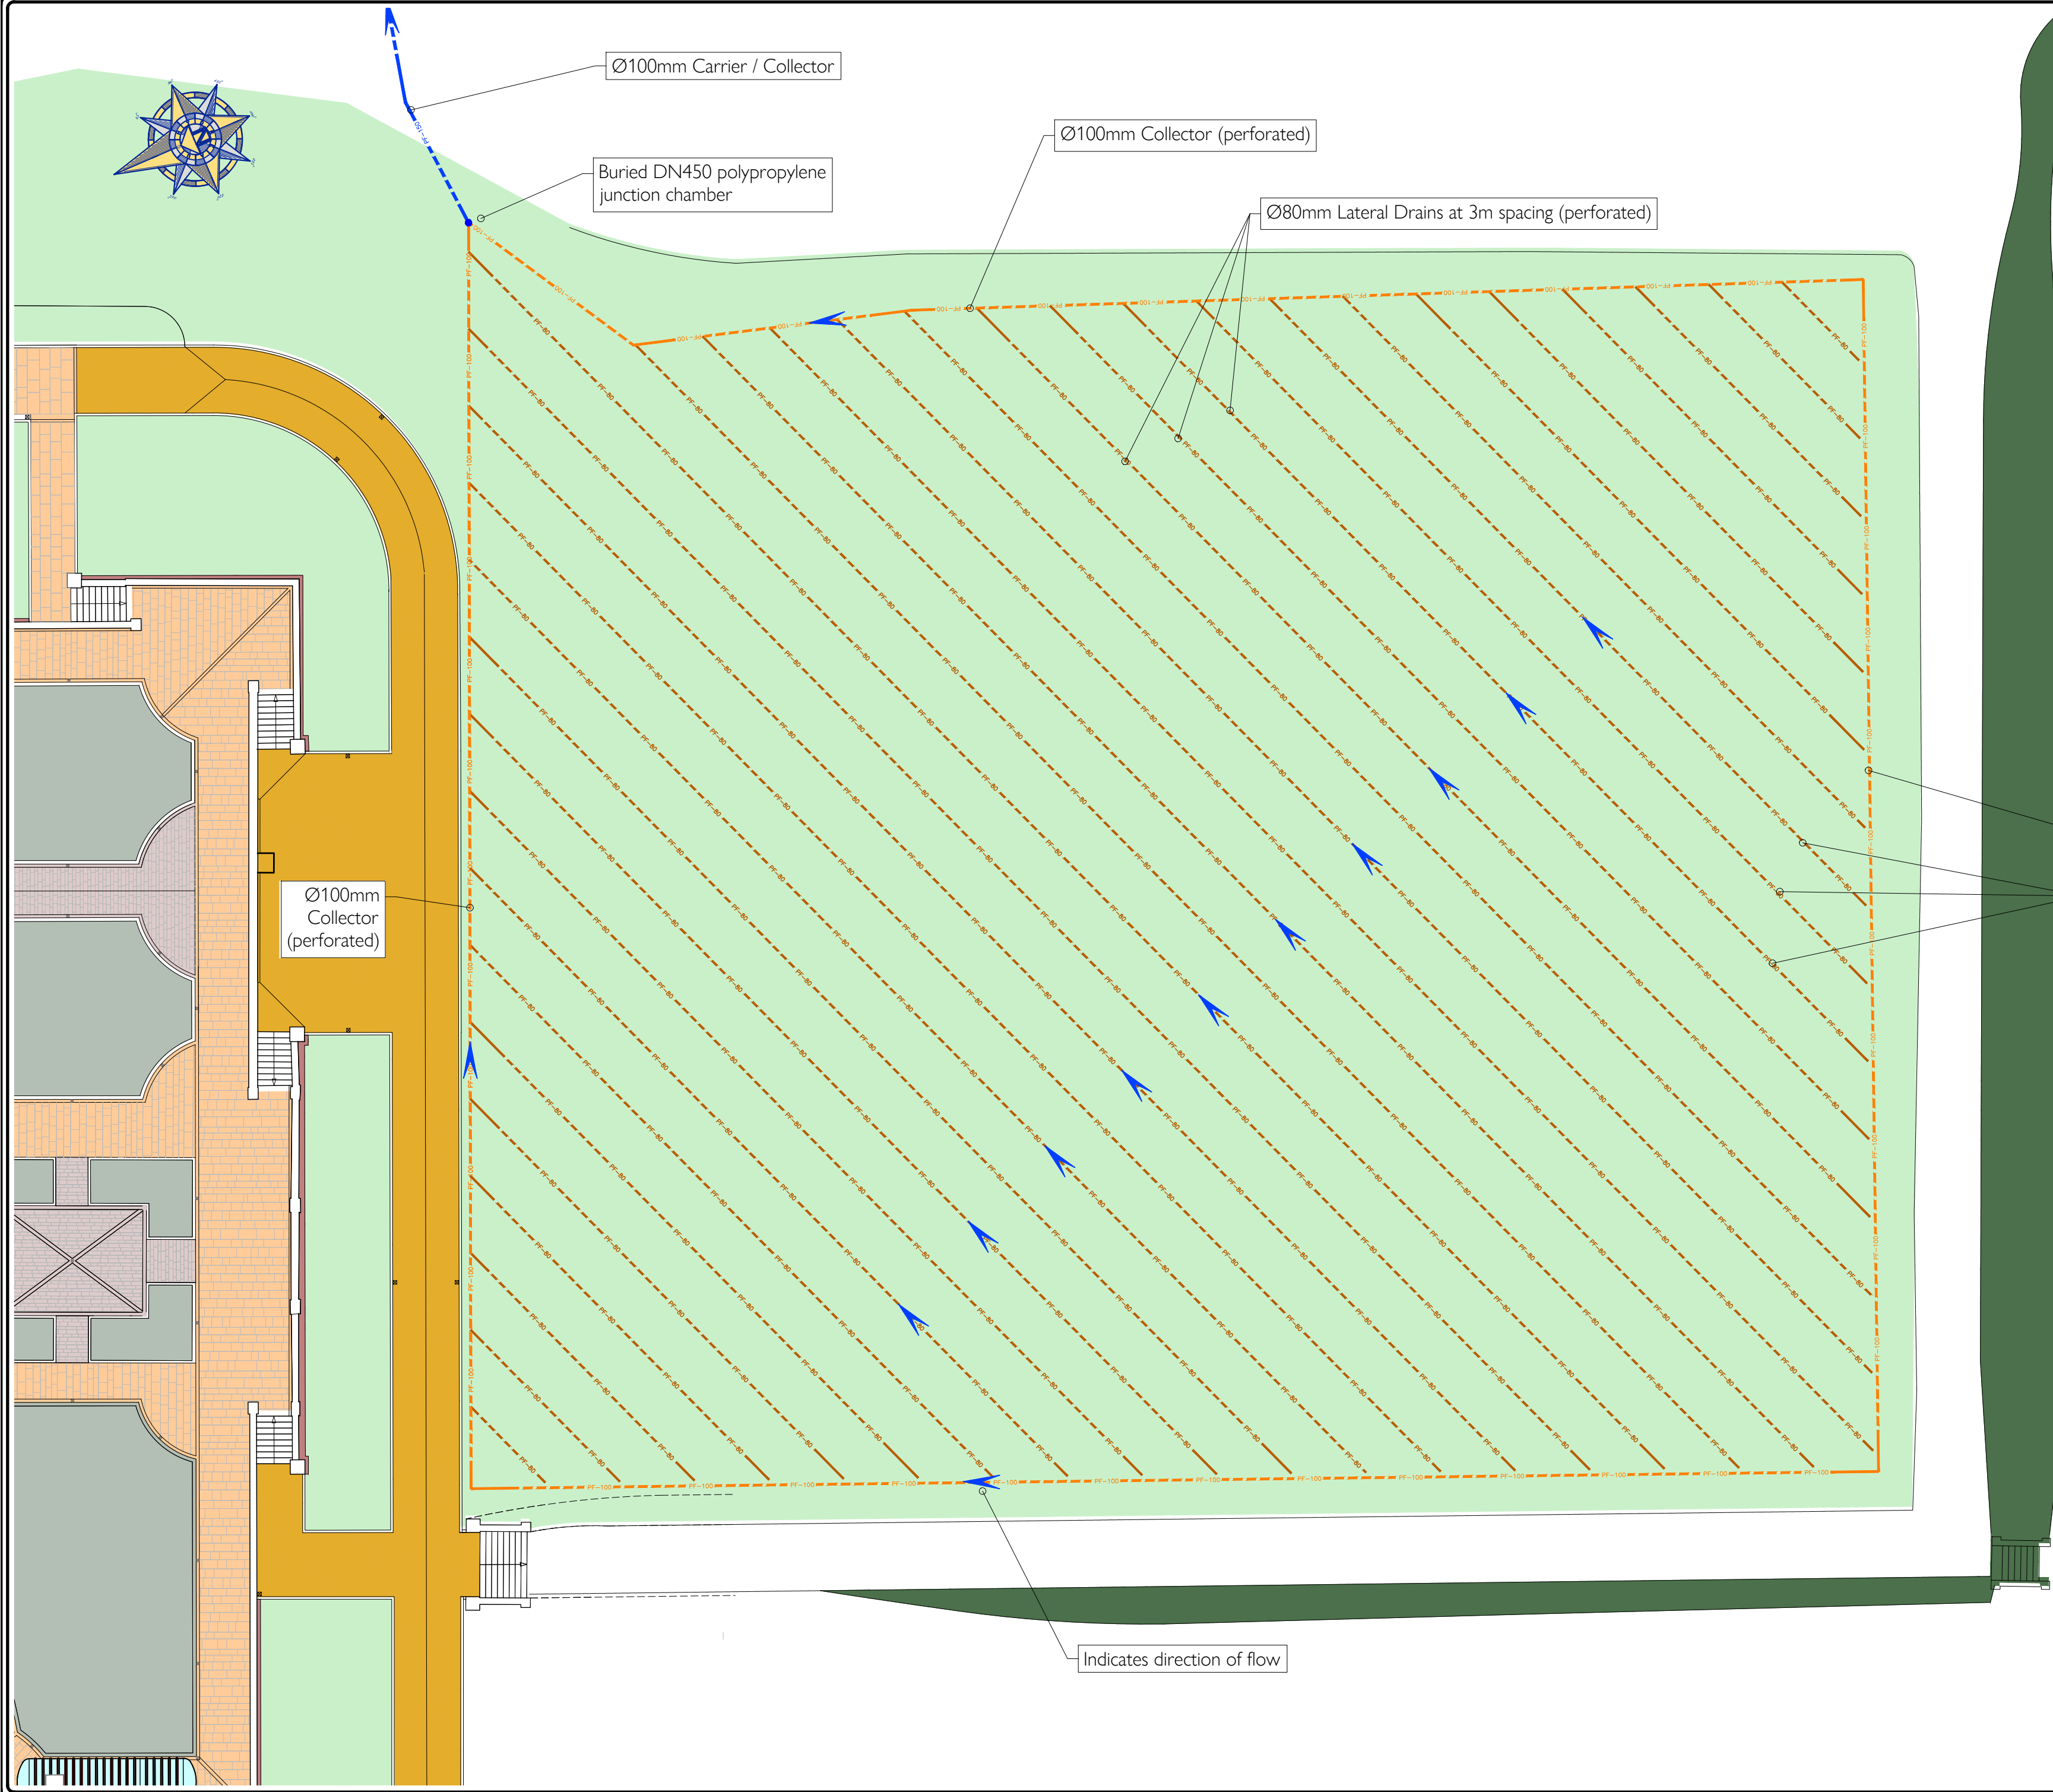

Client:

Tottenham House

Drawing Title:

Sunken Lawn - Drainage Plan

Project:

Lawn Drainage

The information that this drawing carries remains the property of Hydreau Limited. This drawing is protected by copyright and may not be reproduced, copied or used for any purpose without the written consent of Hydreau. Do not scale from pdf's.

Notes:

To be set out on site.

Drawn By:

MW

Date:

23.02.26

Scale:

1:250/ A3

Dwg. No.:

792.0.DR.SL.1

V.

1

HYDREAU

Consulting Engineers

Hydrology

Water Engineering

Drainage

Irrigation

Blackbird Cottage · Main Street · Ewerby · Sleaford · Lincolnshire · NG34 9PH

T: 0333 600 7005 E: marcus@hydreauuk www.hydreauuk

Ø100mm
Collector
(perforated)

Ø100mm Carrier / Collector

Buried DN450 polypropylene
junction chamber

Ø100mm Collector (perforated)

Ø80mm Lateral Drains at 3m spacing (perforated)

Ø100mm Peripheral & Toe Drain (perforated)

Ø80mm Lateral Drains at 3m spacing (perforated)

Indicates direction of flow

