

- KEY
- New tree
 - Existing tree
 - Tree to be removed
 - Root Protection Area
 - New planting
 - Development Area - 0.08 hectare
 - BNG Area - 0.184 hectare
 - Modified grassland
 - Other neutral grassland
 - Low-level bollard lighting, downward facing output
 - Wall-mounted LED downlights



Bollard Light precedent



Wall Light precedent

External Lighting Design


 
The external lighting scheme will be selected and installed to comply with the following guidance:

Be fixed downlights with a 0 degree tilt angle. Floodlights or units which can be tilted are not appropriate.

Have a 0% upward light ratio. Meaning that the only light produced by the unit is directed to the floor. Some units also emit light upwards or sideways, these are not appropriate.

Be fitted with a low wattage LED bulb (maximum 5W) with a warm white colour temperature not exceeding 2700K.

All lighting shall be triggered by a PIR motion sensor to limit disturbance.

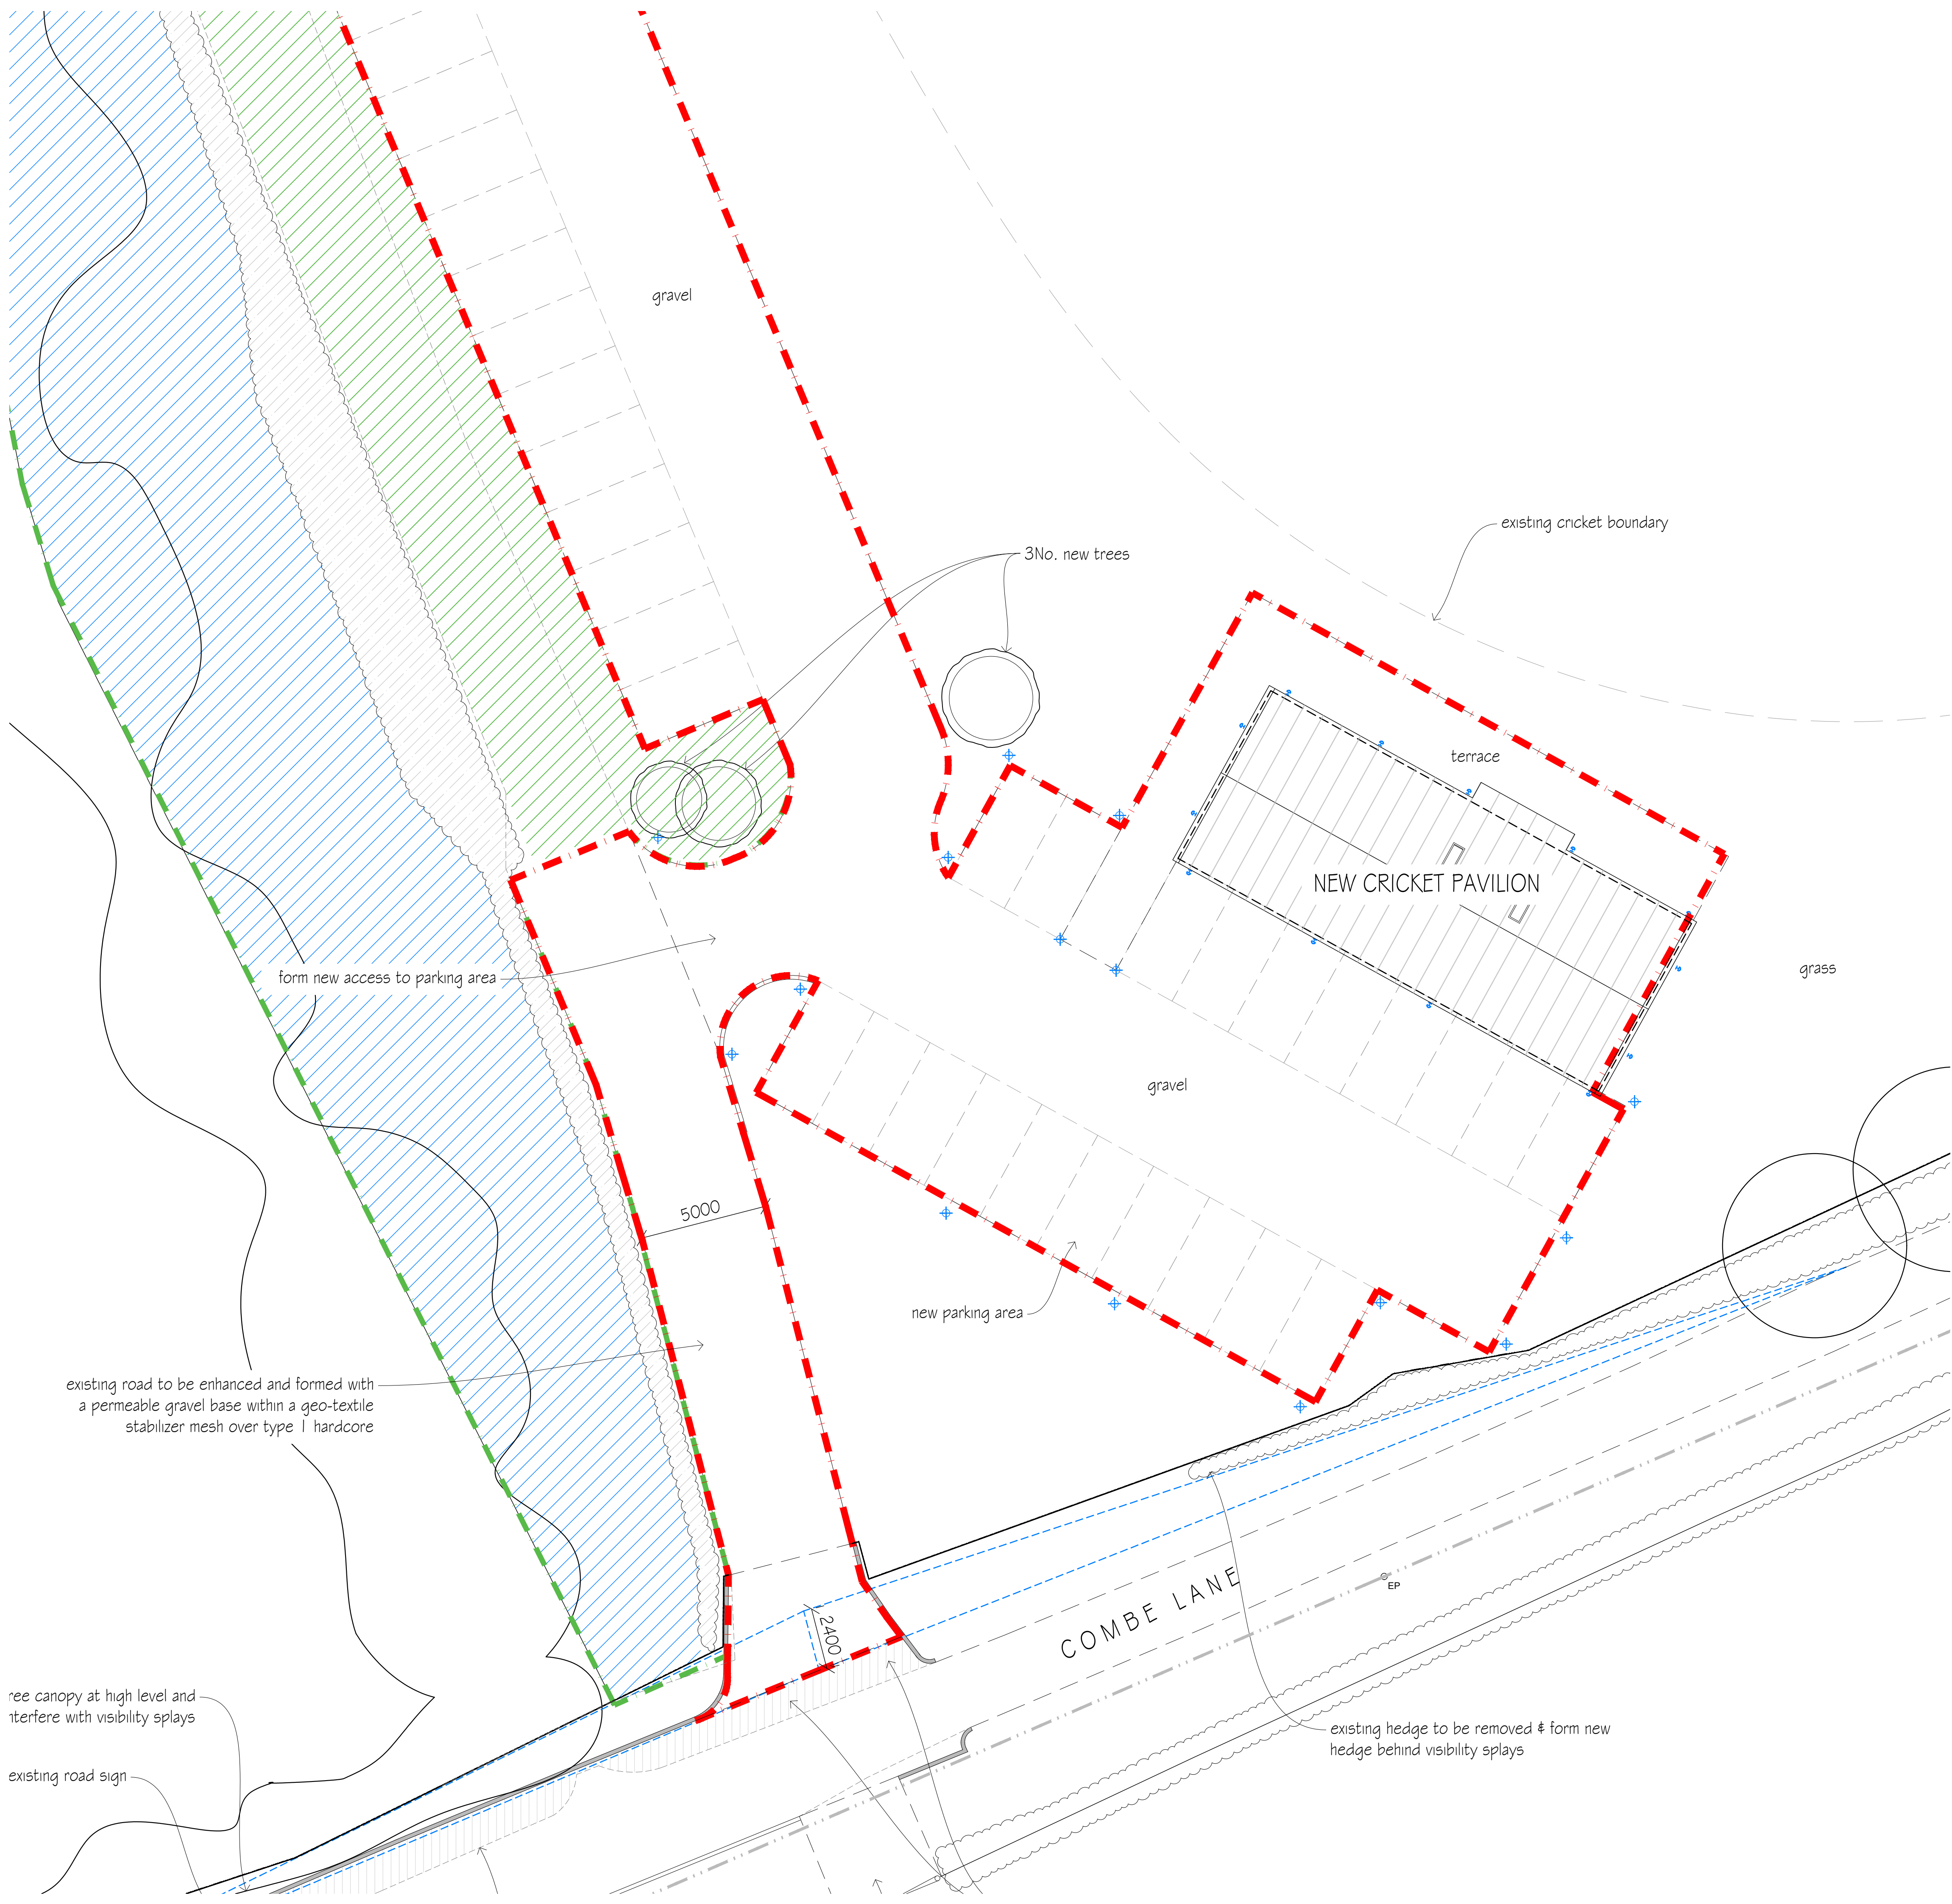

B	Consultation comments addressed	BL	24.02.26
A	CO comments addressed	BL	12.02.26
revisions		initial	date

Contractors, Sub Contractors and Suppliers are to check all relevant dimensions and levels of site and buildings before commencing any shop drawings or building work.

This drawing is copyright and may not be reproduced in any part of form without the written consent of Fowler Architecture and Planning

project
GOATACRE CRICKET CLUB
Goatacre

Site Plan
New Cricket Pavilion

scale
1:200 @A1

drawn by
BL


date
Nov 2025

250522-21

drawing no

B

rev

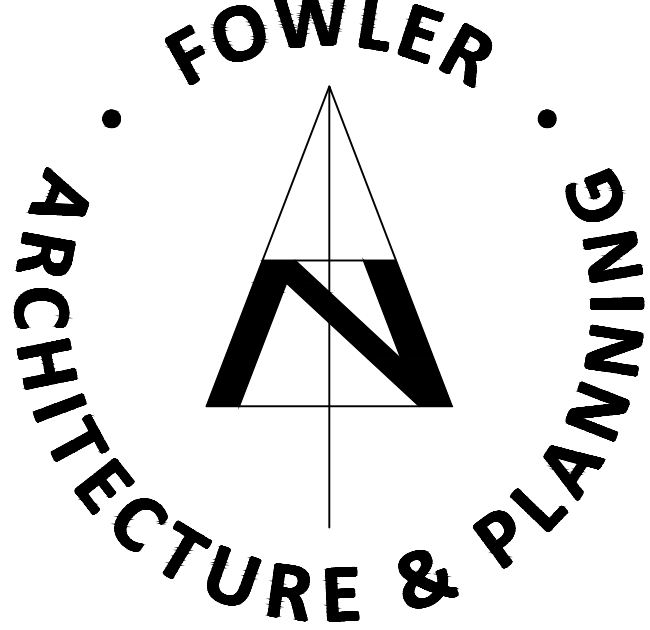

39 High Street
Pewsey
Wiltshire
SN9 5AF
tel (01672) 569444
fax (01672) 569488
enquiries@faap.co.uk