



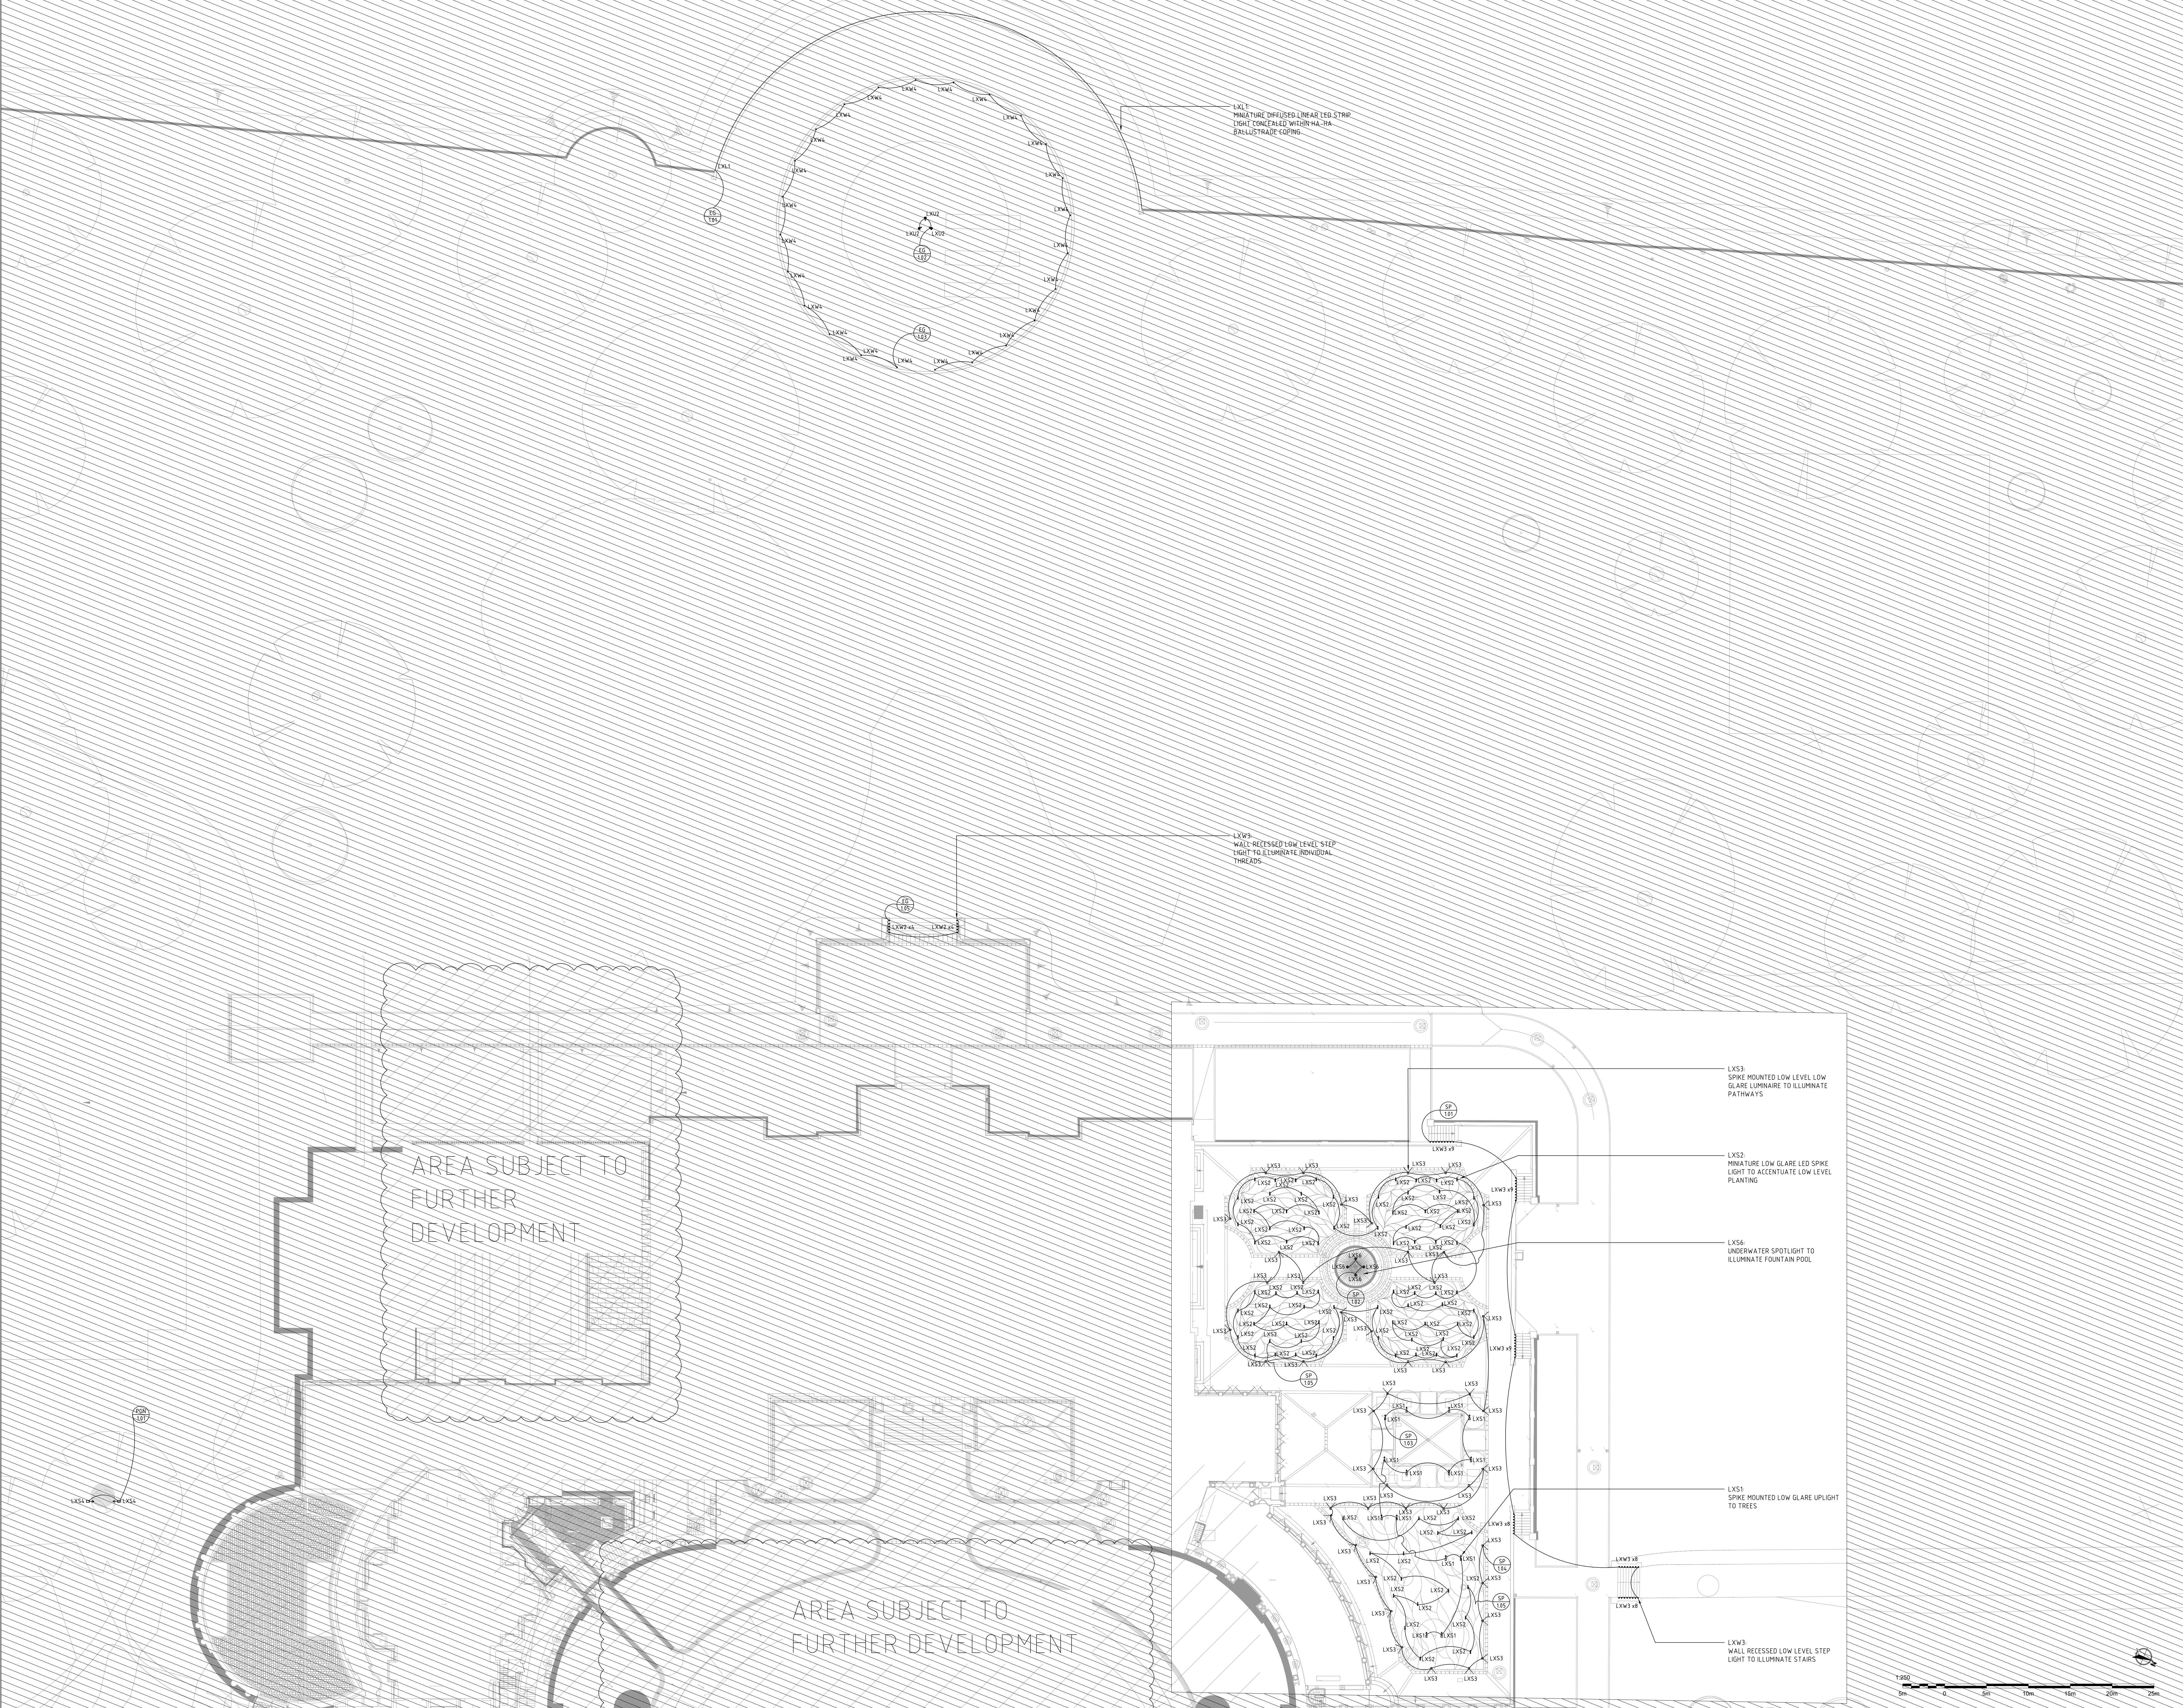

- LIGHTING NOTES:
- 1. Refer to appropriate dpa luminaire and lighting control schedules for further details.
 - 2. Scaled dimensions should not be taken from this drawing. All dimensions to be checked on-site.
 - 3. Where appropriate refer to associated lighting detail drawings for the exact location of luminaires.
 - 4. All equipment supplied by the installing contractor shall comply with the relevant EN, BS, CE & IEC regulations, and be capable of installation in accordance with the current edition of the IEE wiring regulations. All equipment shall comply with all other statutory and local authority requirements.
 - 5. Installing Contractor to ensure that all transformers and control gear are compatible with the lighting control system dimmers.
 - 6. Final locations of lighting control plates, manual sliders and dimmer racks to be co-ordinated with Architect and M&E consultant. Exact locations to be agreed on-site and approved by client.
 - 7. Emergency lighting system and signage by others.

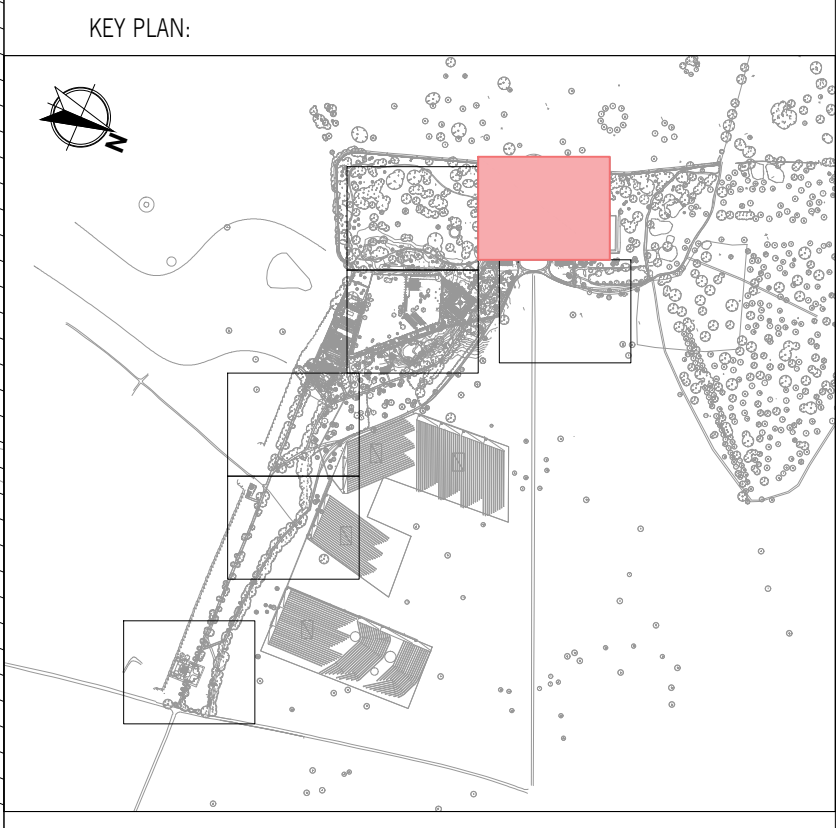

LUMINAIRE SYMBOLS:

	Linear LED luminaire
	Spike mounted linear LED luminaire
	Spike mounted spotlight
	Spike mounted spotlight
	Spike mounted spotlight
	Tree mounted projector luminaire
	Spike mounted spotlight
	Under water spotlight
	In-ground uplight
	Under water uplight
	Wall mounted luminaire
	Wall recessed floor washer
	Under water wall recessed floor washer

LUMINAIRE REFERENCES:

LXL1	Concealed linear lighting for balustrade
XL10	Spike mounted linear to walled garden
LXS1	Spike mounted spotlight to tree canopies
LXS2	Spike mounted spotlight for small planters
LXS3	Spike mounted spotlight for path lighting
LXS4	Spike mounted spotlight to tree canopies
LXS5	Tree mounted projector for moon lighting
LXS6	Under water spotlight for water fountain
LXU1	In-ground recessed luminaire for boundary wall
LXU2	Under water spotlight for water fountain
LXW1	Wall mounted luminaire for general lighting
LXW2	Wall recessed floor washer for step lighting
LXW3	Wall recessed floor washer for step lighting
LXW4	Under water wall recessed floor washer

08	For Tender	IK	20/02/2026
07	For Planning	RAD	06/02/2026
06	For Coordination	IK	29/01/2026
05	For Planning	AKR	10/12/2025
04	For Planning	AKR	09/12/2025
03	For Planning	AKR	05/12/2025
02	For Information	RAD	21/11/2025
01	For Information	RAD	10/11/2025
First Issue	For Information	AKR	15/10/2025
Revision:	Description:	By:	Date:

dpa lighting consultants London
Studio 208 Langside House Telephone +44 (0) 20 3447 0000
11 Montpelier Road Email london@dpalighting.com
London, SE1 1EN, UK

Project:
TOTTENHAM HOUSE

Drawing Title:
LANDSCAPE LIGHTING LAYOUT
SHEET 7 OF 8
EAST GARDENS, NORTH & SOUTH TERRACE

Scale: 1:250@A0
Drawn By: RAD
Date: 05/02/2025
Drawing No: L10751A_LP_LS_07
Revision: 08

Copyright Lighting Consultants London. To be used only for the project for which it was prepared. Any other use without the written consent of Lighting Consultants London is prohibited.