


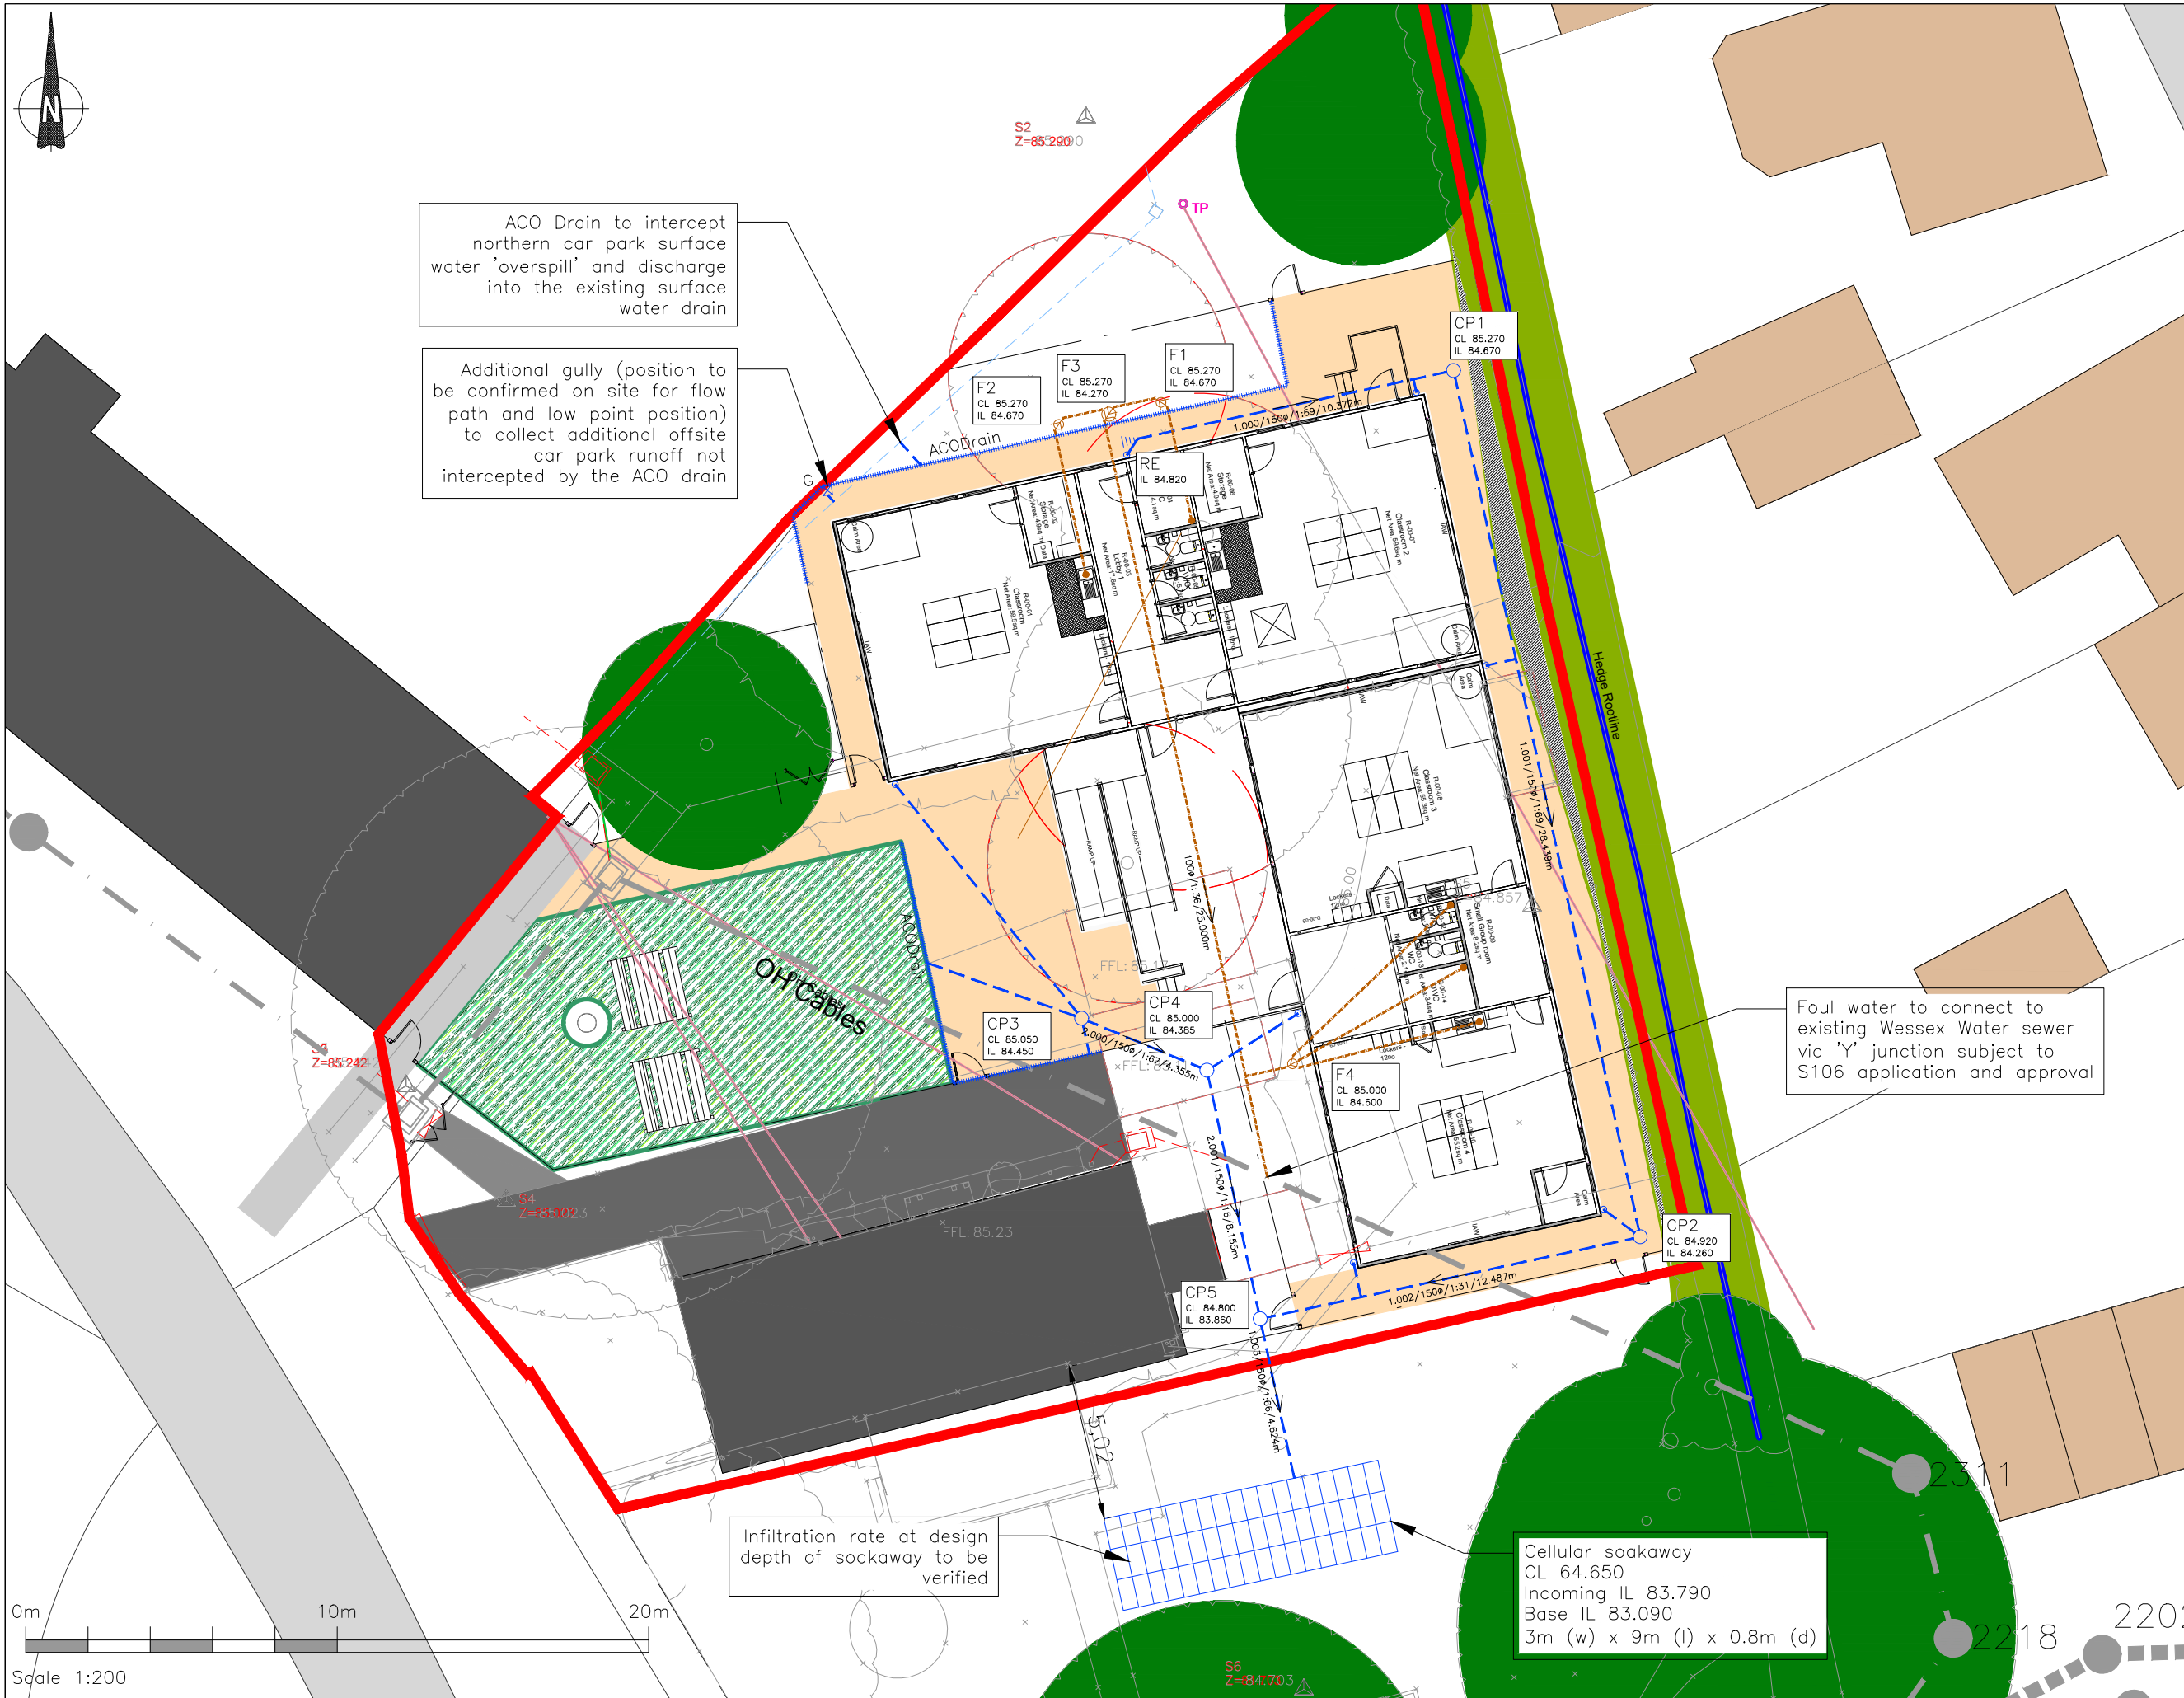

NOTES:

1. All dimensions, levels and survey grid co-ordinates are to be checked on site and the engineer notified immediately of any discrepancies prior to commencement of the works.
2. The works shown on this drawing could affect Statutory Undertakers apparatus and the Contractor is required to verify the location and depth of all apparatus prior to commencement of works and take relevant precautions when working in the vicinity of such apparatus.
3. Sewers and drains of different diameters should be laid soffit to soffit unless specified otherwise.
4. The invert levels of any existing manholes and pipes constructed by others are to be verified on site prior to commencement of drainage work.
5. All dimensions shown in millimeters (mm) unless otherwise stated, and all levels relate to Ordnance Datum.
6. The backfilling of drainage trenches which are in close proximity to foundations must be in accordance with any special requirements set out by the Structural Engineer.
7. Pipes built into manholes should have a flexible joint as close as feasible to the external face of the structure and the length of the next rocker pipe should be:

KEY:

- Wessex Water Foul Sewer
- Wessex Water Surface Sewer
- Existing Foul Water Drain
- Existing Surface Water Drain
- Foul Water Drain
- Surface Water Drain
- ACO Drain

A	11/08/25	ACO drain extended to north - gully added	MTD	TL
Rev	Date	Description	Initials	Check

SDS
consulting
civil & structural engineers

E: enquiries@sds-consulting.co.uk W: www.sds-consulting.co.uk

CLIENT:

WILTSHIRE COUNCIL

PROJECT

**SPRINGFIELD SCHOOL
CALNE**

DRAWING

DRAINAGE LAYOUT

Drawing No. **7061-C-100** REV A

Status **Preliminary for Comment**

Not for Construction

Job Number	7061	Date	AUG 2025
Scale	1:200 @ A3		
Drawn By	MTD	Checked By	TL