


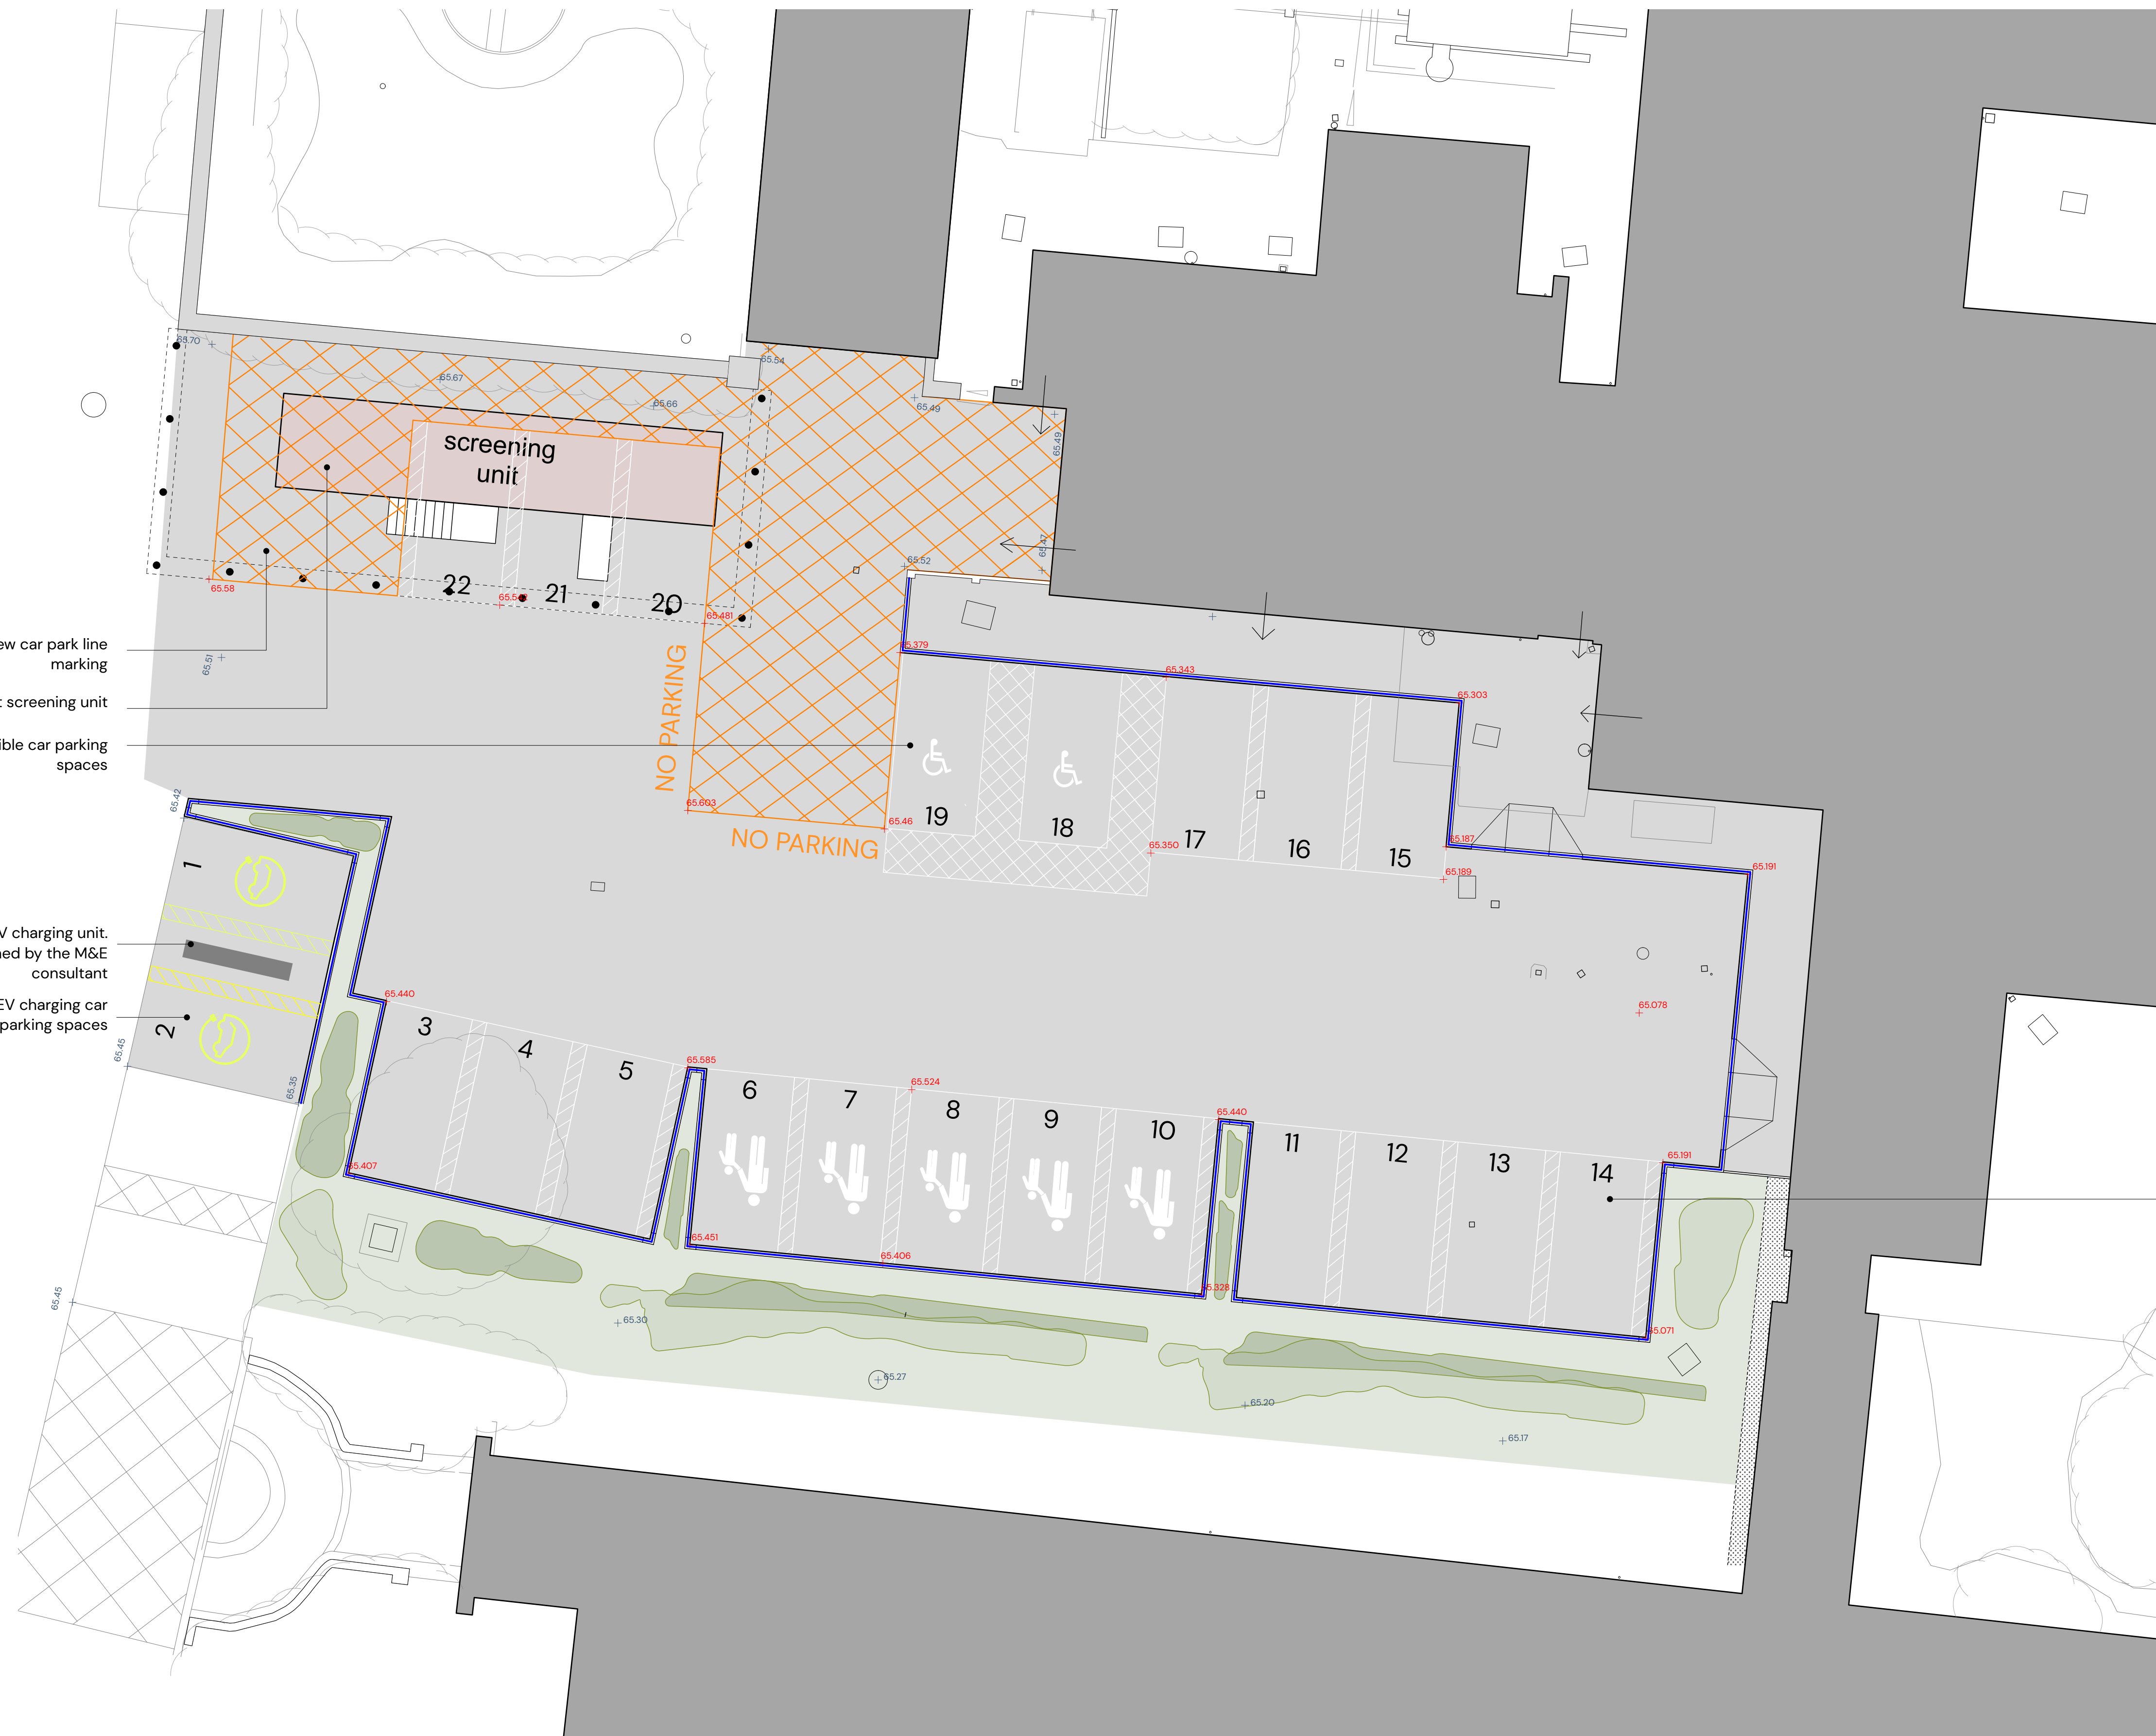

- LEGEND**
- rwp rainwater pipe
 - G gulley
 - IC inspection chamber
 - VP vent pipe
 - FH fire hydrant
 - MH man hole
 - Q50.190 - new manual telescopic posts
 - Q22.110A/ Q10.395A - extent of new tarmac road surfacing with thermoplastic line markings
 - Q10.112A - extent of new concrete road edging kerbs
 - Q22.115A - extent of new tarmac footpath surfacing
 - Q30.311A & Q30.350 - extent of new grassed areas
 - extent of new planting to edge of parking area
 - Q23.150A - extent of gravel edging
 - + 00.000 existing levels
 - + 00.000 proposed levels

extent of new car park line marking

temporary breast screening unit

 
new accessible car parking spaces

location of new EV charging unit.
Size to be confirmed by the M&E consultant

2no. new EV charging car parking spaces

new designated car parking spaces

PROPOSED SITE PLAN
1:100



Kendall Kingscott
Windward House, Fitzroy Road,
Exeter, Devon, EX1 3LJ
+44 (0)1392 266 890
www.kendallkingscott.co.uk

**Chippenham Community Hospital
Generator Works**
Client: **NHSPS**

Date: 29/08/25
Scale: 1:100
Drawn: SCF
Checked: SF
Purpose/Status: CONSTRUCTION
Paper Size: ISO A1

C01 12/01/26 SCFSF Issued for construction
T01 01/10/25 SCFSF Issued for tender
Rev Date By Ap Note

Drawing Title
PROPOSED SITE PLAN

Project Number/Drawing Number
241218-CGW-KK-XX-00-D-A-2002
Check all dimensions and levels on site

Revision
C01
© Copyright

Only to be used on the site for which designed. The electronic transmission of designs/information contained in this drawing is carried out entirely at the User's risk and Kendall Kingscott Ltd. will have no liability for any errors or inaccuracies arising therefrom. The production of amended or updated information from the said designs/information by the User is entirely the responsibility of the User and Kendall Kingscott Ltd. shall have no responsibility in respect thereof whatsoever.