


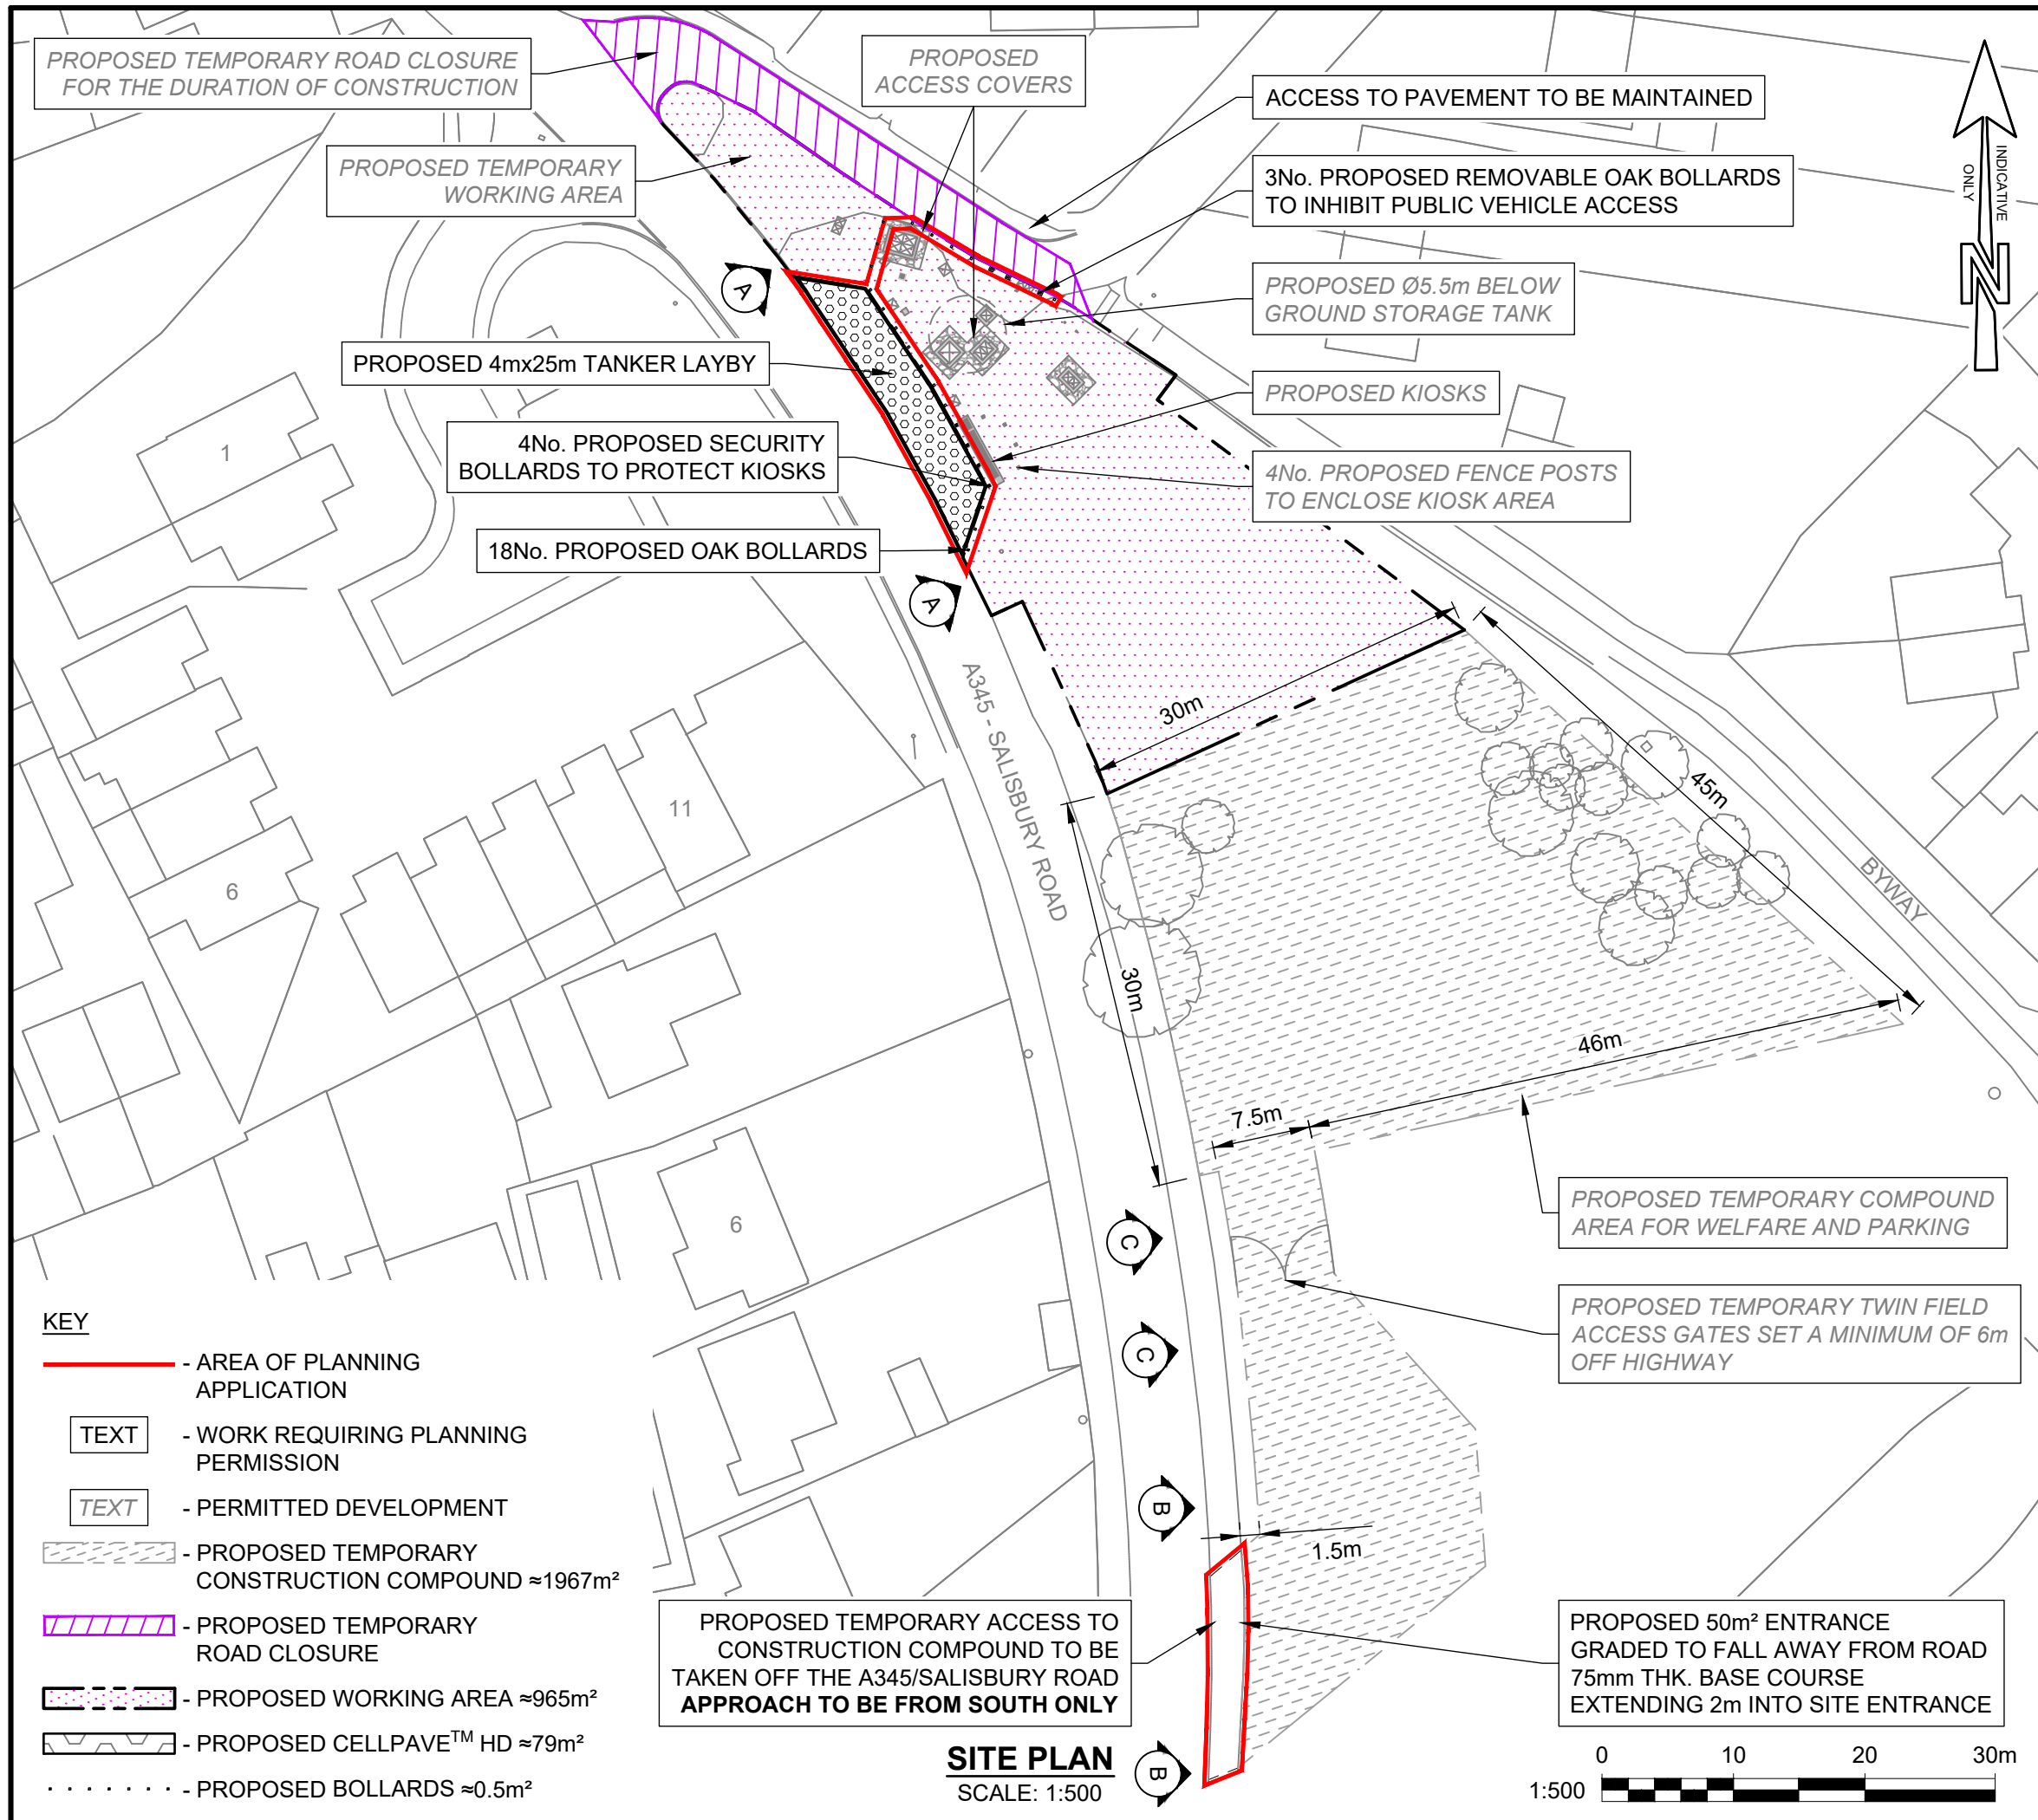

SITE ID	90455				
NGR	415866, 140966				
NOTES	1. ANY MAPS ON THIS DRAWING ARE REPRODUCED FROM THE ORDNANCE SURVEY MAP WITH THE PERMISSION OF HIS MAJESTY'S STATIONERY OFFICE © CROWN COPYRIGHT RESERVED, LICENCE No. 100019539. 2. UNLESS NOTED OTHERWISE, ALL DIMENSIONS ARE IN MILLIMETRES AND ALL LEVELS ARE IN METRES AOD.				
C02	ANNOTATIONS AND BOLLARDS UPDATED	DHI	OJE	JZS	07/04/2026
C01	FIRST ISSUE	DHI	OJE	JZS	15/01/2026
MK	REVISIONS	DRN	CHK	APP	DATE
KINGS GATE AMESBURY					
BELOW GROUND STORM WATER STORAGE TANK					
PLANNING APPLICATION PROPOSED SITE PLAN					
APPROVED FOR ISSUE					
ORIGINAL DRAWING SIZE A3					
INITIALS		DATE		SCALES	REV.
DESIGNED: PR		08/04/2025		1:500	C02
DRAWN BY: DHI		08/04/2025			
DRAWING NUMBER C00520-WWSL-XX-XX-D-T-7202					
Wessex Water YTL GROUP					