

AS BUILT
See Note 9



Stratton Park House, Wanborough Road
Swindon, SN3 4HG

Telephone
01793 828000

Facsimile
01793 835500

Email
admin@pfapl.com

Website
www.pfapl.com

Notes:

- 1) Site layout reference to 'Site Block Plan' Rev B produced by Abbey Manor Developments Limited, dated 27th April 2004.
- 2) All spurs are 150mm super strength VC pipes laid at 1:150.
- 3) All adoptable highway works to be constructed in accordance with the Specification for Highway Works 1998 (SHW) as amended, published by HMSO, and Wiltshire County Council's Design Guide.
- 4) Use of any Working Drawing does not absolve the Client from his responsibilities under Health and Safety: The Construction (Design and Management) Regulations 1994. The Planning Supervisor is required to contact PFA Consulting prior to permitting this drawing to be used in connection with any construction works.
- 5) Traffic signs and road markings shall comply with the Traffic Signs Regulations and General Directions 2002.
- 6) All road markings shall be laid out in accordance with the Traffic Signs Manual Chapter 5.
- 7) All road markings shall be formed in thermoplastic material complying with BS 3262 - Class A.
- 8) All works within the limit of the highway shall be signed in accordance with the Department of Transport's Traffic Signs Manual (1991) Chapter 8 'Traffic Safety Measures and Signing for Roadworks and Temporary Situations'.
- 9) All 'As Built' amendments are not carried out by PFA Consulting - they are added for inclusion in building 100-A's Health and Safety file. PFA Consulting have no record of the as built amendments. No further amendments for Units 1-15.

Q 2401/06 Issued as an 'As Built' drawing for Units 1-15. ADM
P 01/01/06 Issued as an 'As Built' drawing for Units 1-15. ADM

Rev	Date	Description	Initials
O	19/05/05	Manhole F11C repositioned, manhole F11B deleted and drainage to Road 11 added	DRB
N	23/05/05	Relocated foul drainage for building 100-B added	DW
M	25/07/05	Minor Storm drainage amendments	DW
L	18/07/05	Minor Foul drainage amendments	DW
K	10/07/05	Minor Storm drainage amendments	DW
J	09/06/05	Minor Storm and foul drainage amendments around Finstometer	DW
I	31/05/05	Private foul sewer alterations to Unit 1-6 due to new non-disabled shower arrangements	DW
H	26/05/05	Additional surface water drainage information added and minor foul water drainage amendments	DW
G	01/05/05	Minor foul surface water drainage and soakaway amendments	CS

Client

Abbey Manor
Group Limited

Project

Zone A, Solstice Park

Drawing Title

Foul and Surface Water
Drainage Layout

Drawing No. A102/24 Rev Q

Date September 2004


Scale 1:250 @ A1

Drawn By DW

Checked By GE

E-Mail geves@pfapl.com

File Ref. A102/PFA Drawings/A102_24q.bwg

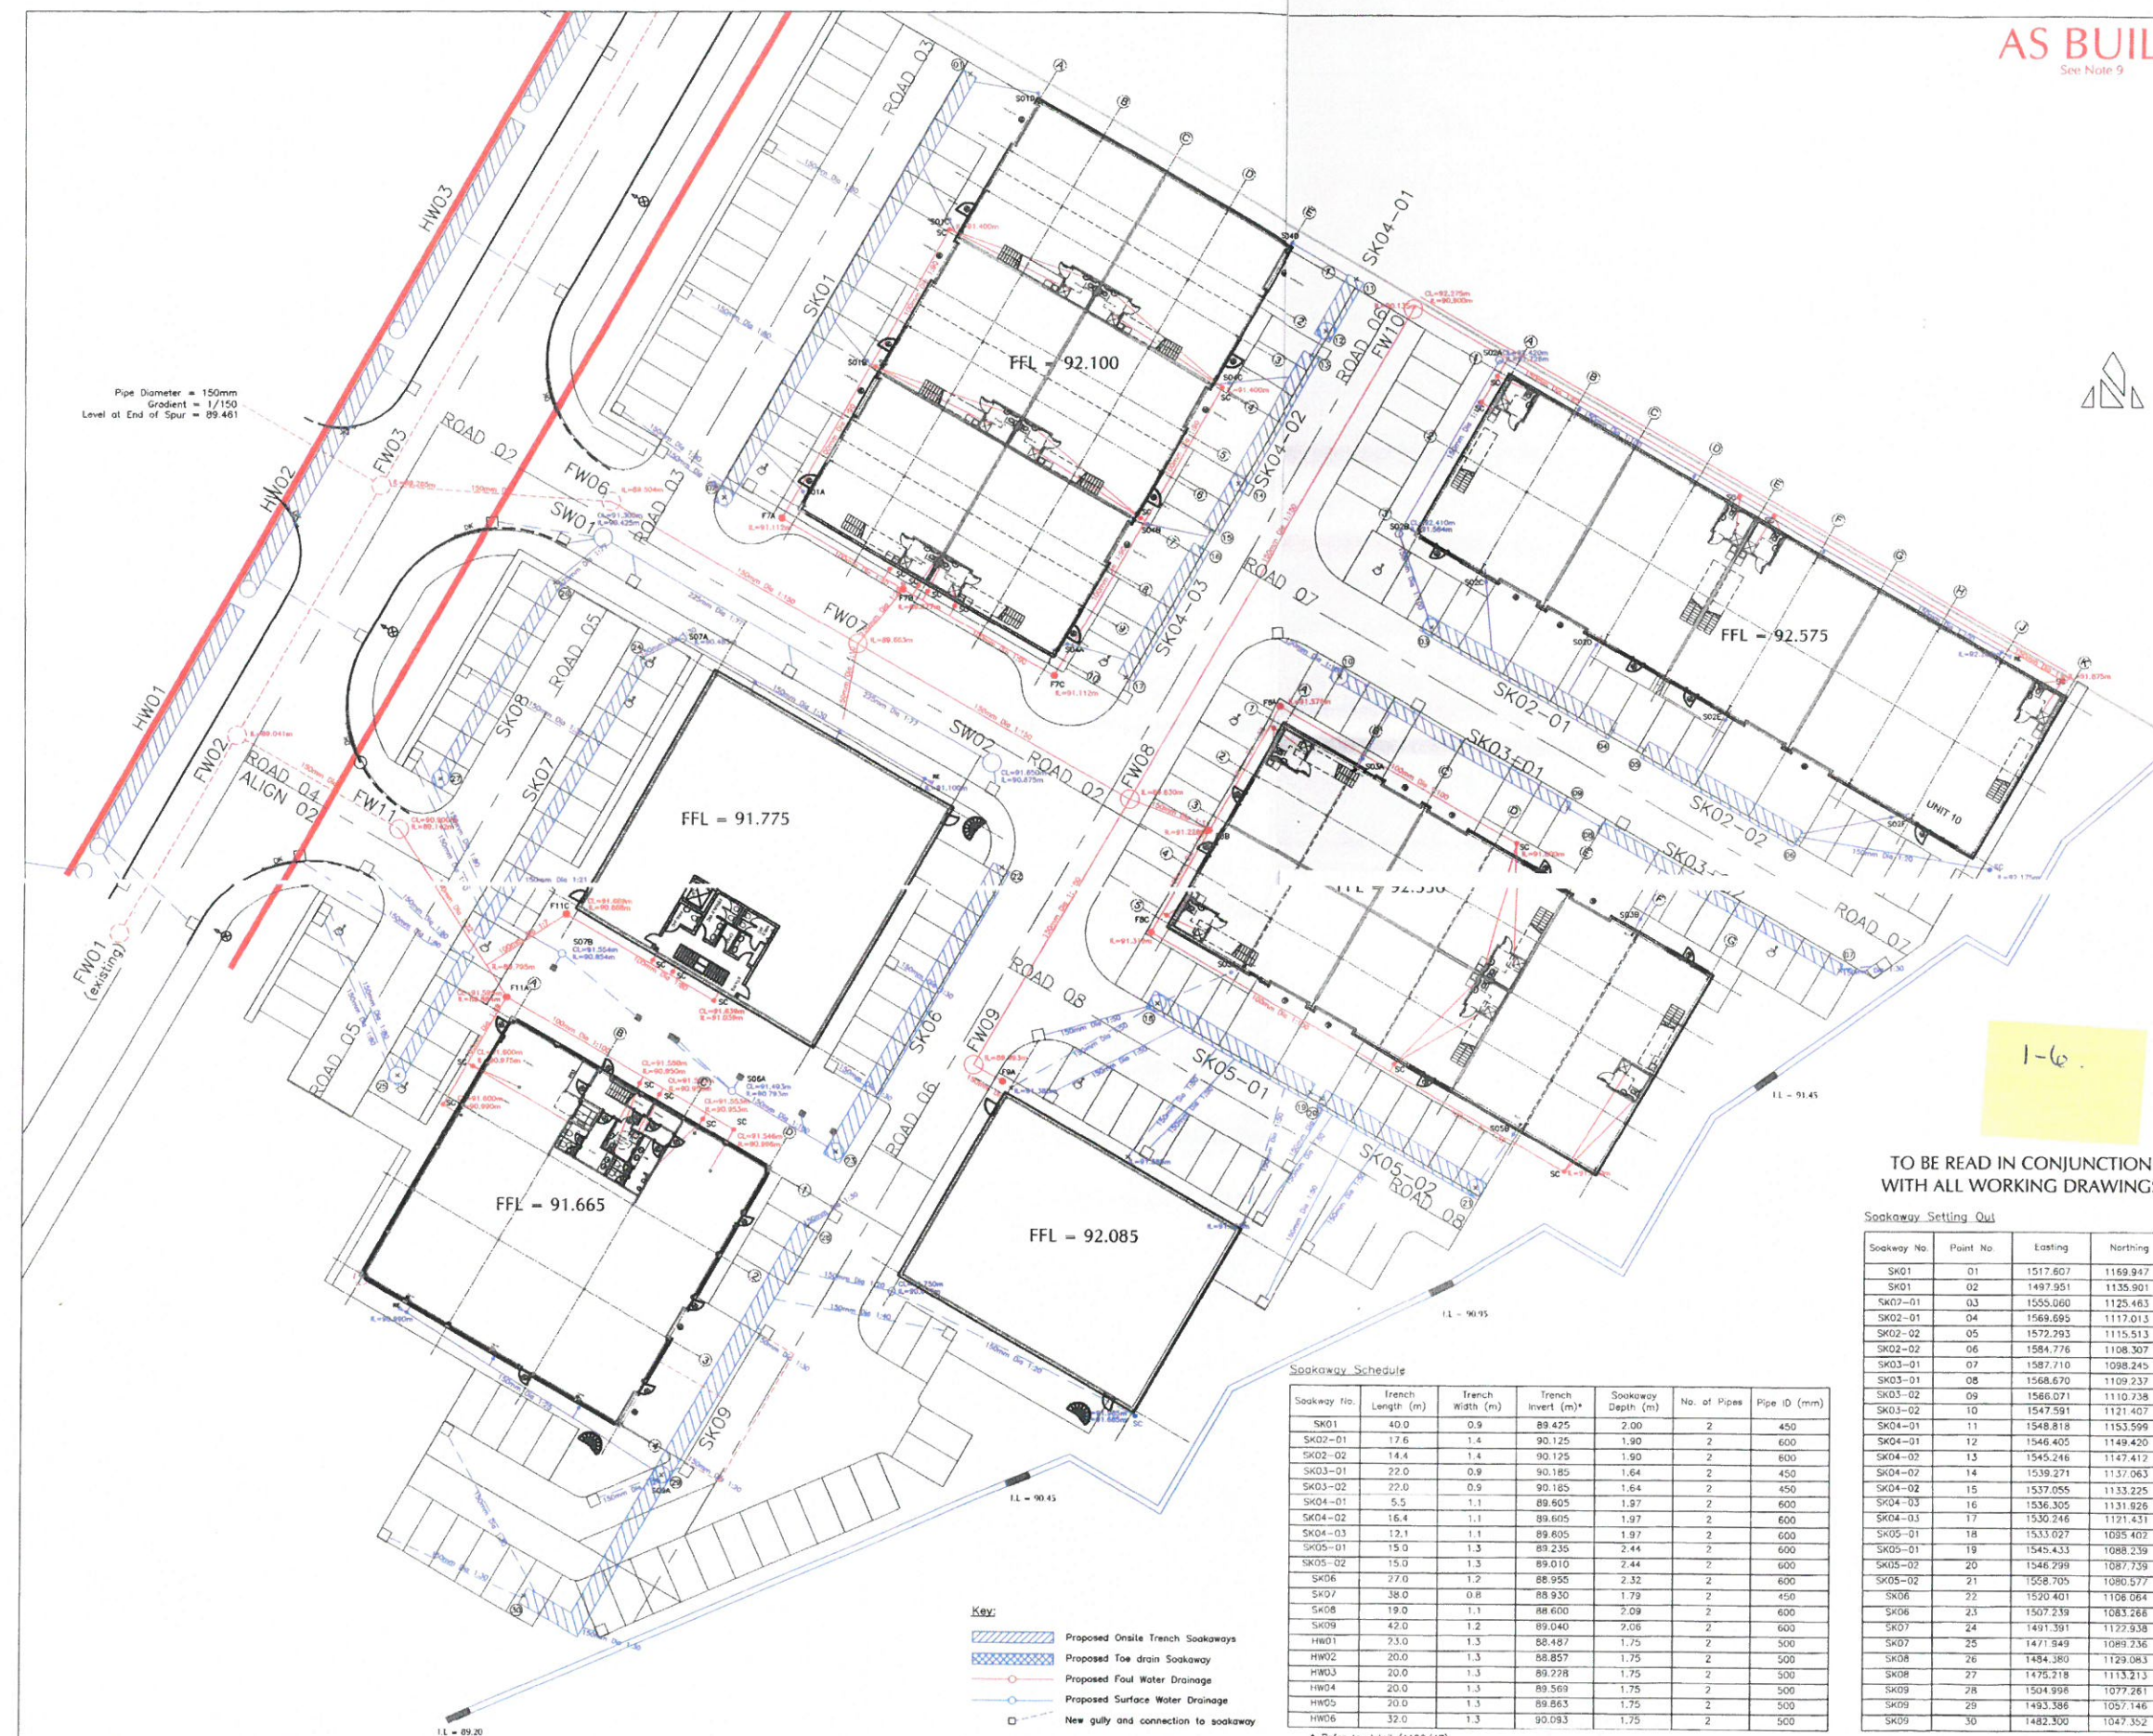

Soakway No.	Trench Length (m)	Trench Width (m)	Trench Invert (m)*	Soakway Depth (m)	No. of Pipes	Pipe ID (mm)
SK01	40.0	0.9	89.425	2.00	2	450
SK02-01	17.6	1.4	90.125	1.90	2	600
SK02-02	14.4	1.4	90.125	1.90	2	800
SK03-01	22.0	0.9	90.185	1.64	2	450
SK03-02	22.0	0.9	90.185	1.64	2	600
SK04-01	5.5	1.1	89.605	1.97	2	600
SK04-02	16.4	1.1	89.605	1.97	2	600
SK04-03	12.1	1.1	89.605	1.97	2	600
SK05-01	15.0	1.3	89.235	2.44	2	600
SK05-02	15.0	1.3	89.010	2.44	2	600
SK06	27.0	1.2	88.955	2.32	2	600
SK07	38.0	0.8	88.930	1.79	2	450
SK08	19.0	1.1	88.600	2.09	2	600
SK09	42.0	1.2	89.040	2.08	2	600
HW01	23.0	1.3	88.487	1.75	2	500
HW02	20.0	1.3	88.857	1.75	2	500
HW03	20.0	1.3	89.278	1.75	2	500
HW04	20.0	1.3	89.568	1.75	2	500
HW05	20.0	1.3	89.863	1.75	2	500
HW06	32.0	1.3	90.093	1.75	2	500

* Refer to detail (A102/47)