


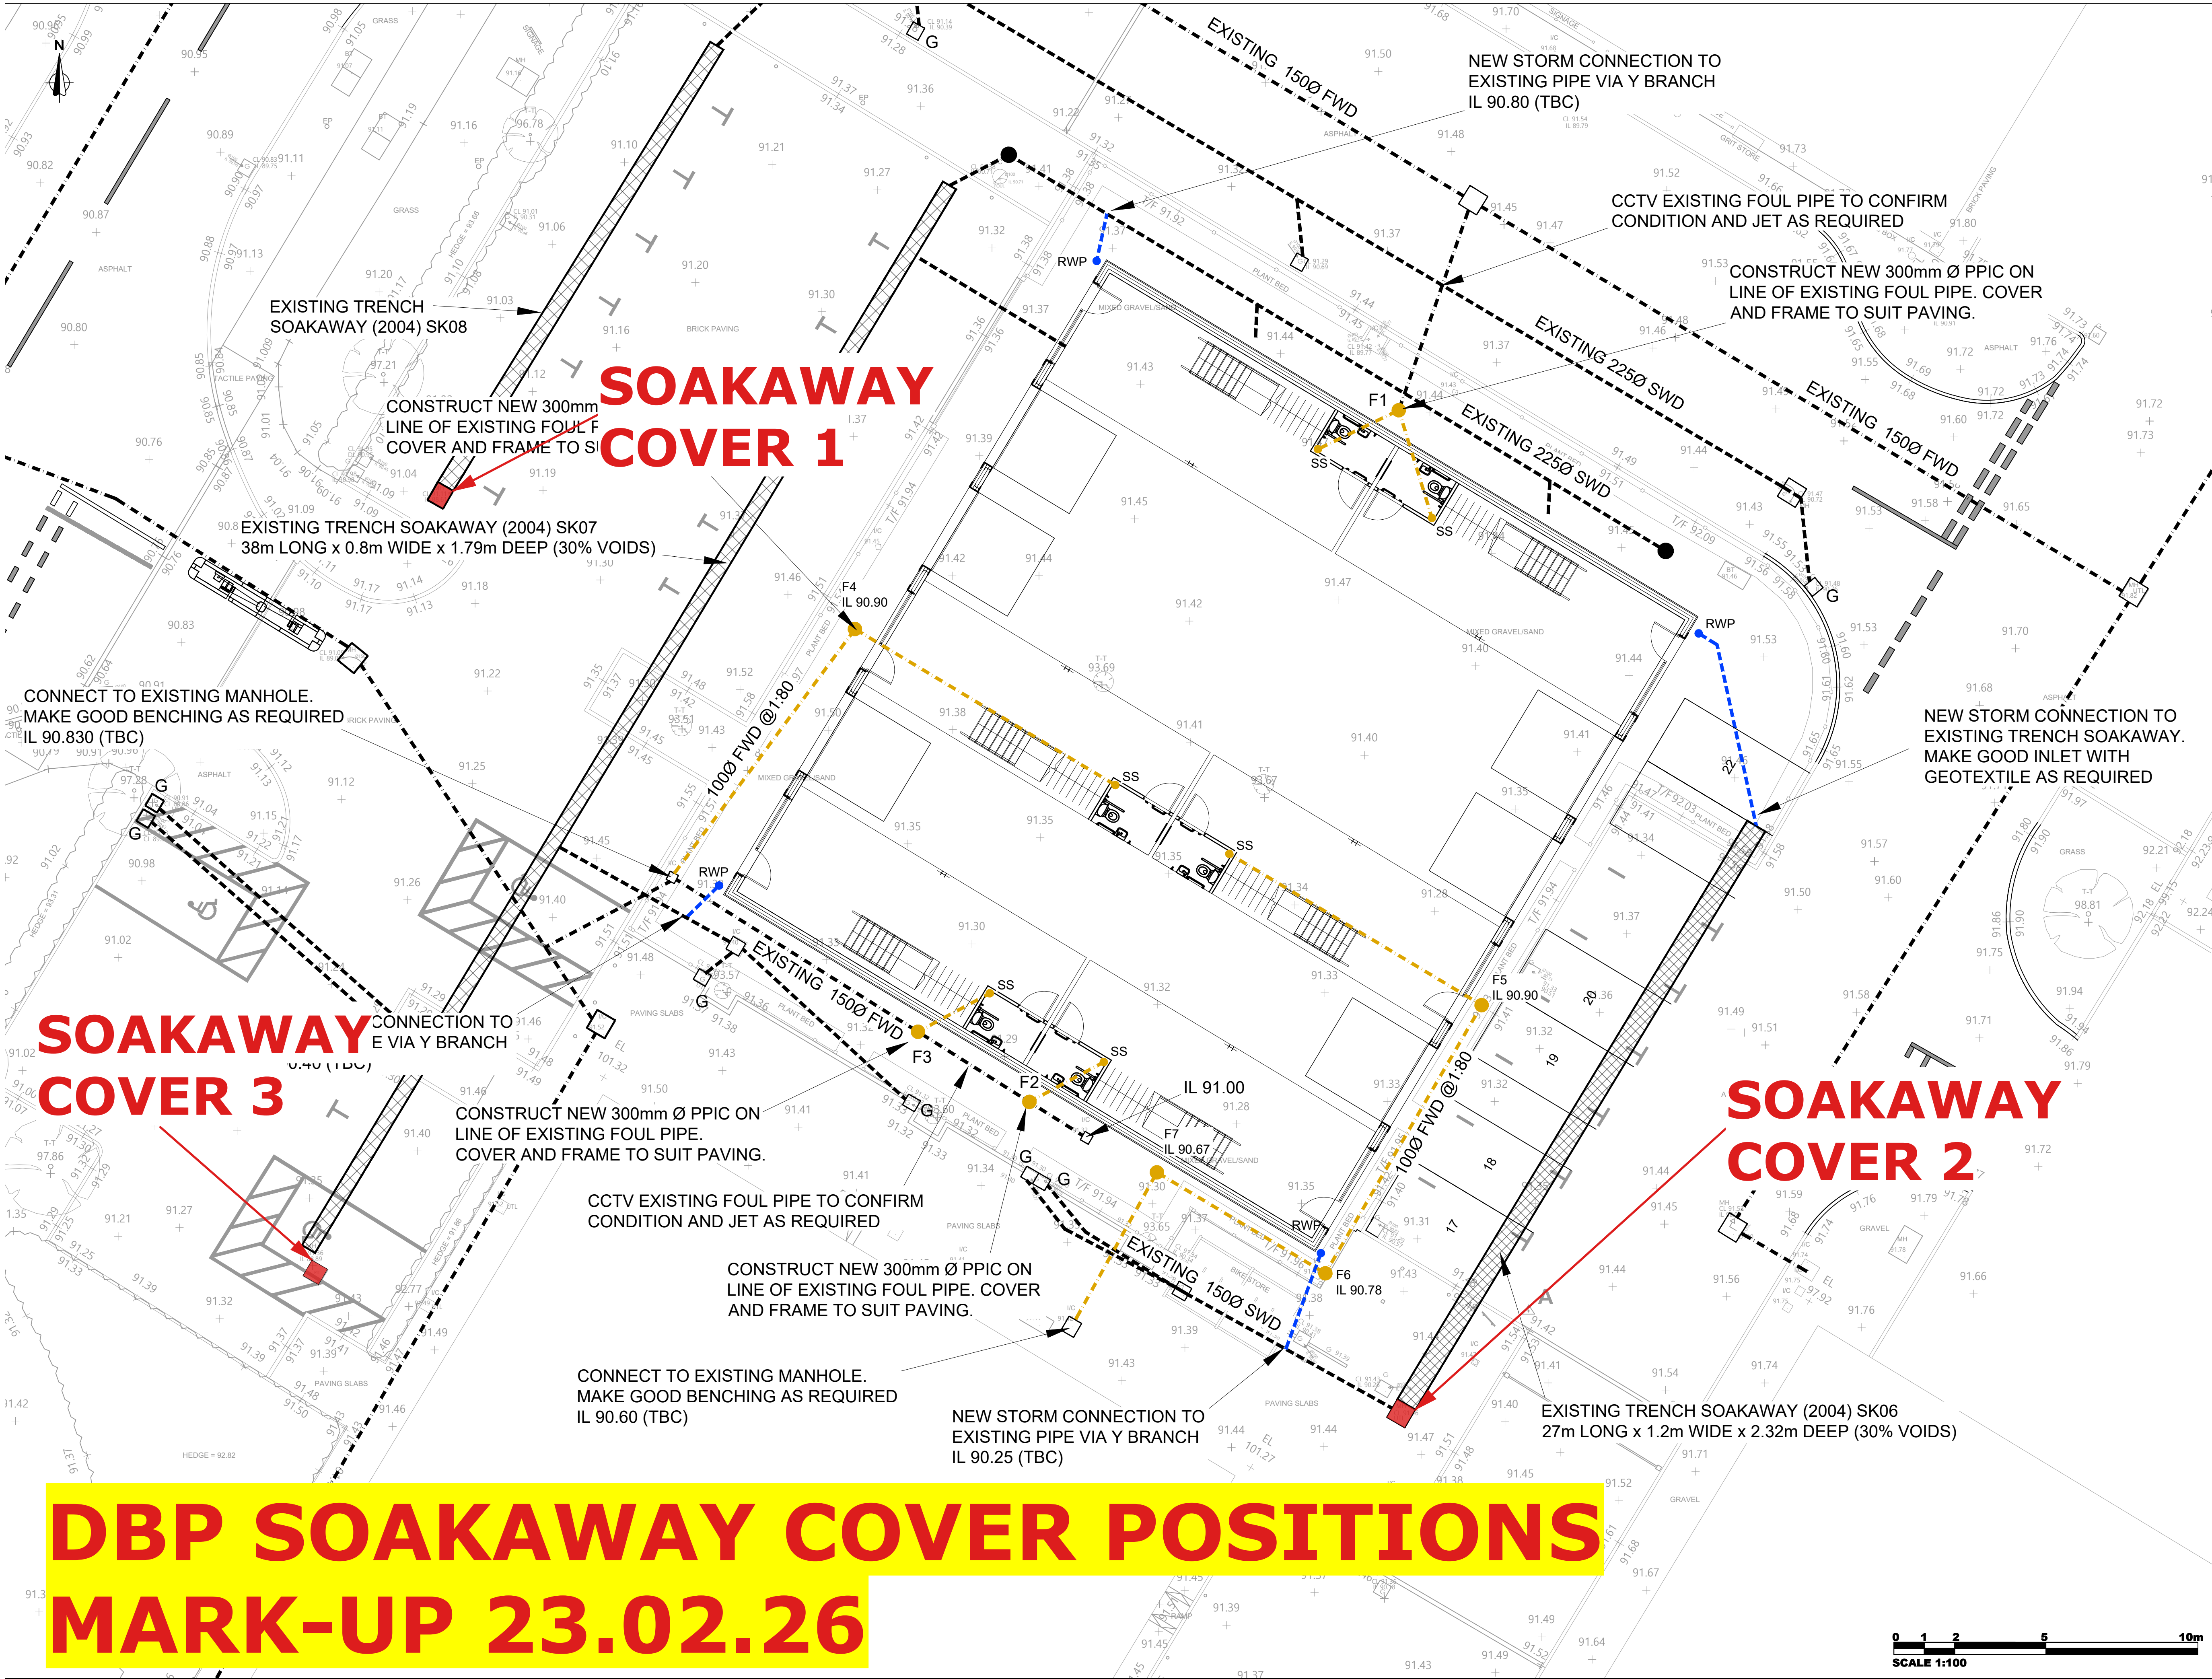

- Notes:**
1. Do not scale from this drawing. All dimensions are in metres unless noted otherwise.
 2. Drawing to be read in conjunction with all other consultants drawings. Any discrepancies are to be reported to the engineer immediately.
 3. Position of existing services/statutory undertakers apparatus are to be checked by the contractor prior to starting work.

KEY

- EXISTING FOUL DRAINAGE
- EXISTING STORM DRAINAGE
- - - PROPOSED FOUL DRAINAGE
- - - PROPOSED STORM DRAINAGE
- G EXISTING GULLY
- RWP RAINWATER PIPE
- SS SOIL STACK

REFER TO M&E PLAN FOR ABOVE GROUND DRAINAGE AND VENTING PLAN

ALL PROPOSED DRAINAGE TO BE 1000 Ø UNO

C

B

Rev

21.01.26

30.07.25

Date

SCALE BAR ADDED. CONSTRUCTION ISSUE

FOUL DRAINAGE REVISED

Details

KT

JT

Drawn

CLIENT:
BRUNEL DESIGN PARTNERSHIP LTD

PROJECT:
SOLSTICE PARK, SOLAR WAY, AMESBURY

TITLE:
PROPOSED BELOW GROUND DRAINAGE LAYOUT

SCALE @ A1:

DATE:

DRAWN:

STATUS:

1:100

29.05.25

KT

CONSTRUCTION

JOB NO:

DRAWING NO:

REVISION:

25-3107

C002

C

**DBP SOAKAWAY COVER POSITIONS
MARK-UP 23.02.26**

