


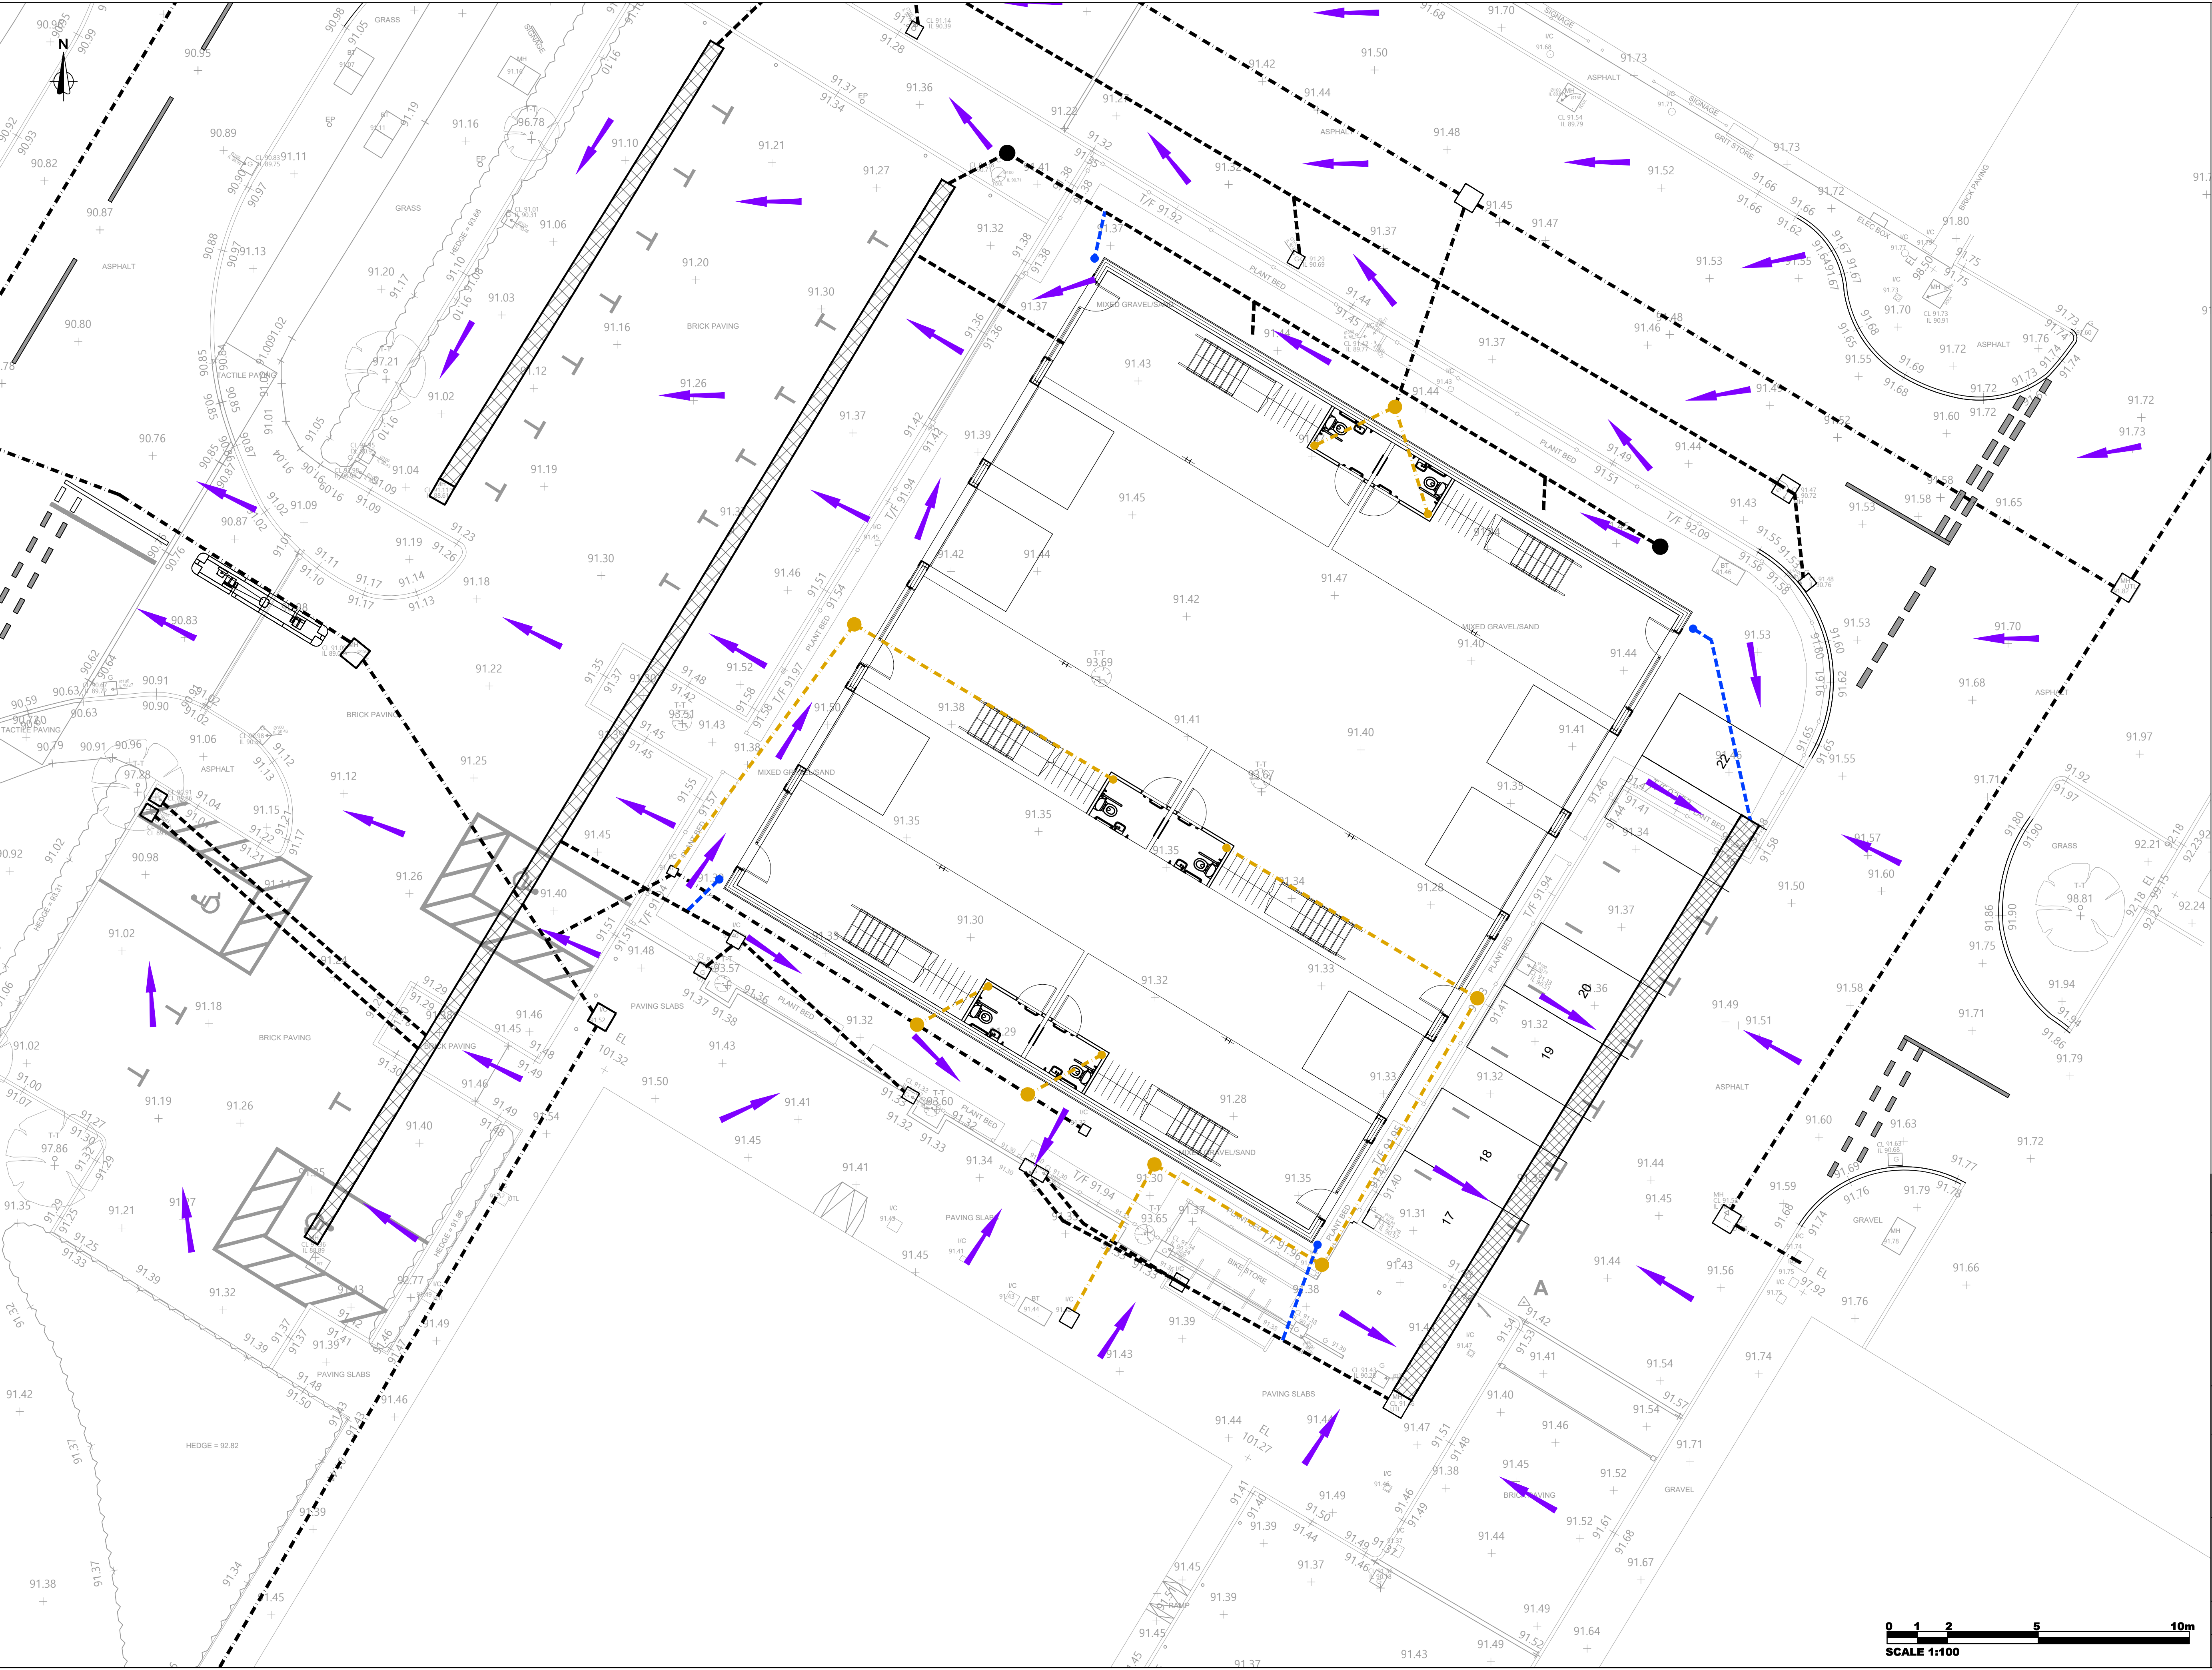

- Notes:**
- 1. Do not scale from this drawing. All dimensions are in metres unless noted otherwise.
 - 2. Drawing to be read in conjunction with all other consultants drawings. Any discrepancies are to be reported to the engineer immediately.
 - 3. Position of existing services/statutory undertakers apparatus are to be checked by the contractor prior to starting work.

KEY

- BUILDING FOOTPRINT
- EXCEEDANCE FLOW ROUTE

REFER TO M&E PLAN FOR ABOVE GROUND DRAINAGE AND VENTING PLAN

REFER TO DRAINAGE PLAN FOR DRAINAGE DETAILS

A	02.03.26	FIRST ISSUE	SJC
Rev	Date	Details	Drawn



CLIENT:
BRUNEL DESIGN PARTNERSHIP LTD

PROJECT:
SOLSTICE PARK, SOLAR WAY, AMESBURY

TITLE:
EXCEEDANCE FLOW ROUTE PLAN

SCALE @ A1:	DATE:	DRAWN:	STATUS:
1:100	29.05.25	KT	CONSTRUCTION
JOB NO:	DRAWING NO:	REVISION:	
25-3107	C002	A	

