


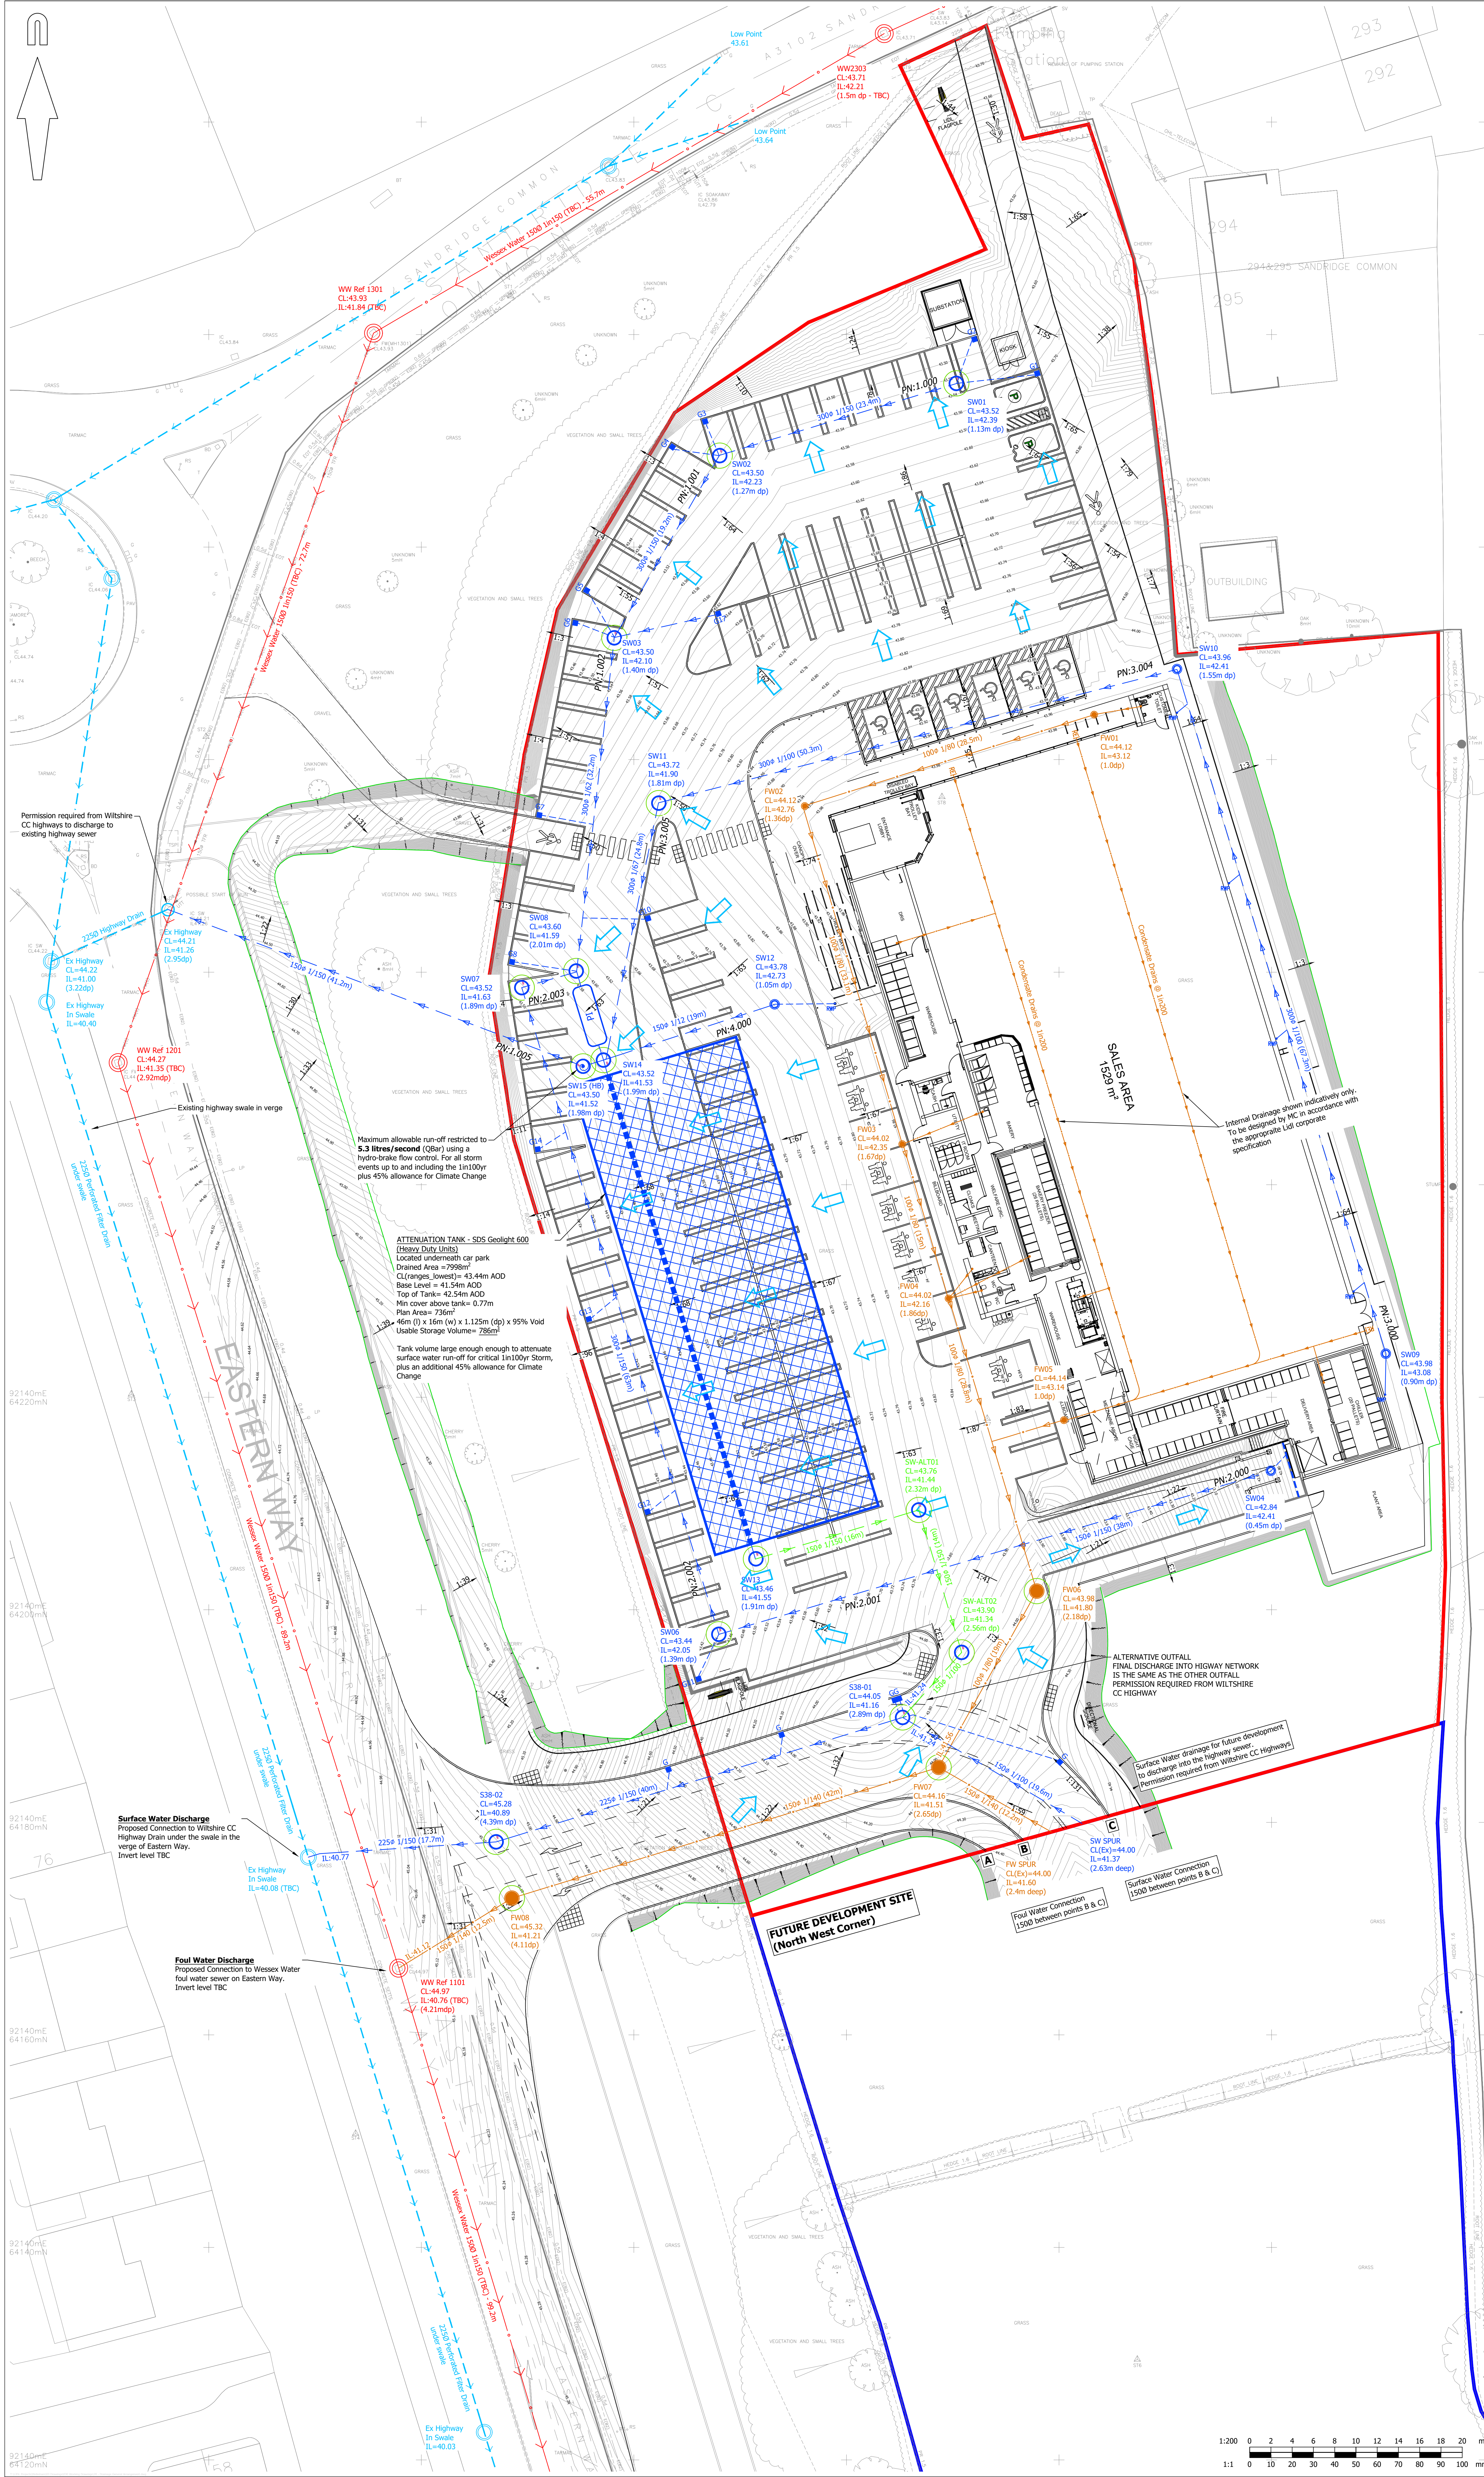

AO ORIGINAL

© Crown copyright and database rights 2025. Ordnance Survey 100055373.

KEY:

PROPOSED SURFACE WATER SEWER AND MANHOLE

PROPOSED SURFACE WATER SEWER AND INSPECTION CHAMBER

PROPOSED PUMPING CHAMBER

PROPOSED HYDROBRAKE

PROPOSED SURFACE WATER LINEAR DRAINAGE CHANNEL

PROPOSED PERFORATED PIPE

PROPOSED PETROL INTERCEPTOR

PROPOSED ATTENUATION TANK

PROPOSED RAIN WATER PIPE

PROPOSED GULLY AND GULLY LEAD

PROPOSED FOUL WATER SEWER AND INSPECTION CHAMBER

PROPOSED FOUL WATER SEWER AND MANHOLE

PROPOSED FOUL DRAINAGE RODDING EYE

EXISTING FOUL SEWER AND MANHOLE

EXISTING SURFACE WATER SEWER AND MANHOLE

RED LINE BOUNDARY

EXCEEDANCE FLOW ROUTES

NOTES:

1. This drawing is not to be scaled.

2. Drawing based on htc Architect's "4034 P402A Proposed Setting Out Site Plan" received on 08/12/2025.

3. This drawing is to be read in conjunction with the following Mayer Brown drawing reference:

- LIDLMEUKSHAM.23/11 - Proposed Engineering Layout

KEY TO HEALTH AND SAFETY SYMBOLS

INDICATES A RESIDUAL RISK REQUIRING A COMPULSORY ACTION.

INDICATES A RESIDUAL RISK FOR INFORMATION.

INDICATES A RESIDUAL RISK REQUIRING A PROHIBITIVE ACTION.

INDICATES A RESIDUAL RISK AS A WARNING.

FOR INFORMATION

REV FOR CONSTRUCTION

P5

Scale bar added following comments from Wiltshire County Council. (TC)

SF

27/04/2026

P4

Surface and foul water drainage provision for future disposal land updated (SF)

SF

16/03/2026

P3

Wessex Water & Highway sewers added. S38 drainage added. Surface and foul water outfalls amended. Disposal land future connection spurs revised. (AR)

SF

11/03/2026

P2

Initial Issue. (AR)

SF

06/03/2026

P1

Draft Issue. (AR)

SF

24/12/2025

rev.

amendment

checked

date

m3

mayer brown

Mayer Brown Limited

1st Floor, Oriental Road, Woking, Surrey GU22 8AR

Telephone: 01483 750 508 Fax: 01483 750 437

enquiry@mayerbrown.co.uk www.mayerbrown.co.uk

client

LIDL GREAT BRITAIN LIMITED

project

MELKSHAM EASTERN WAY

scale

1:200

drawn by

AR

checked by

SF

date

December 25

cad file

20.DWG

title

DRAINAGE GENERAL ARRANGEMENT

Mayer Brown Limited jobscode

submittal

revision

P5

drawing number

LIDLMEUKSHAM.23/20

