




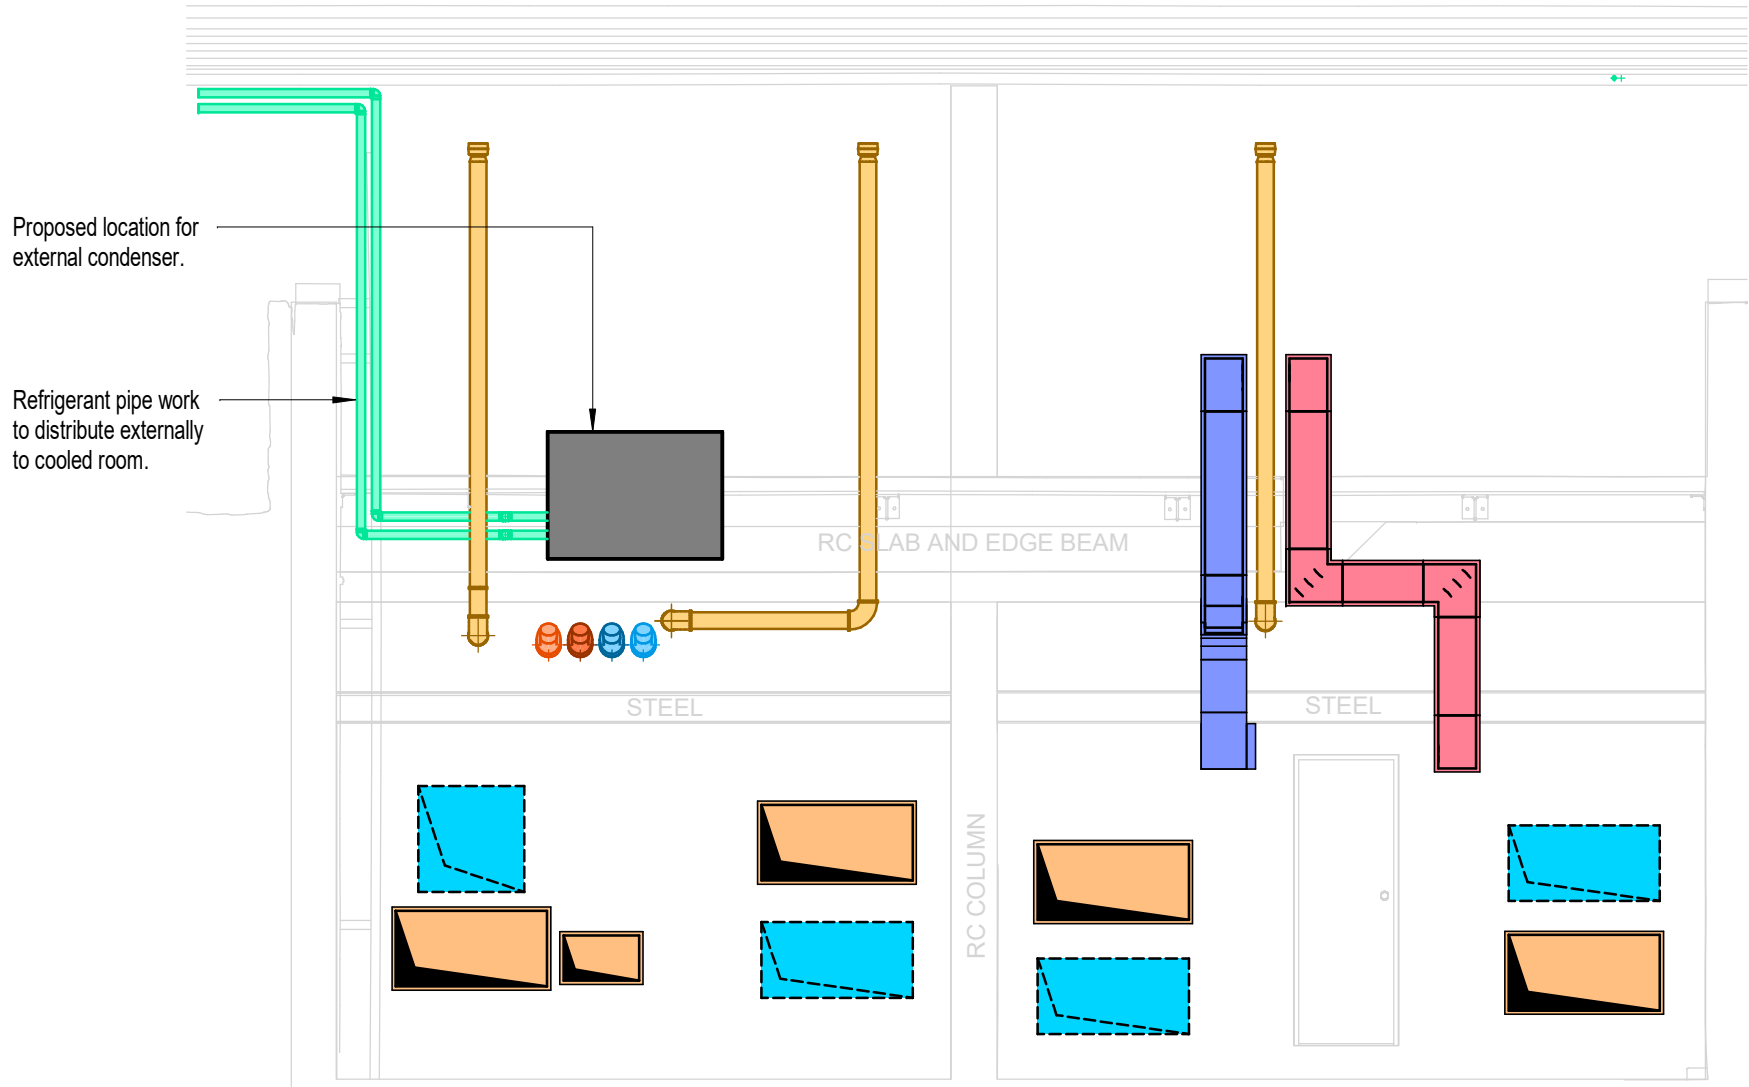

1 Service Penetrations in Elevation
1:50

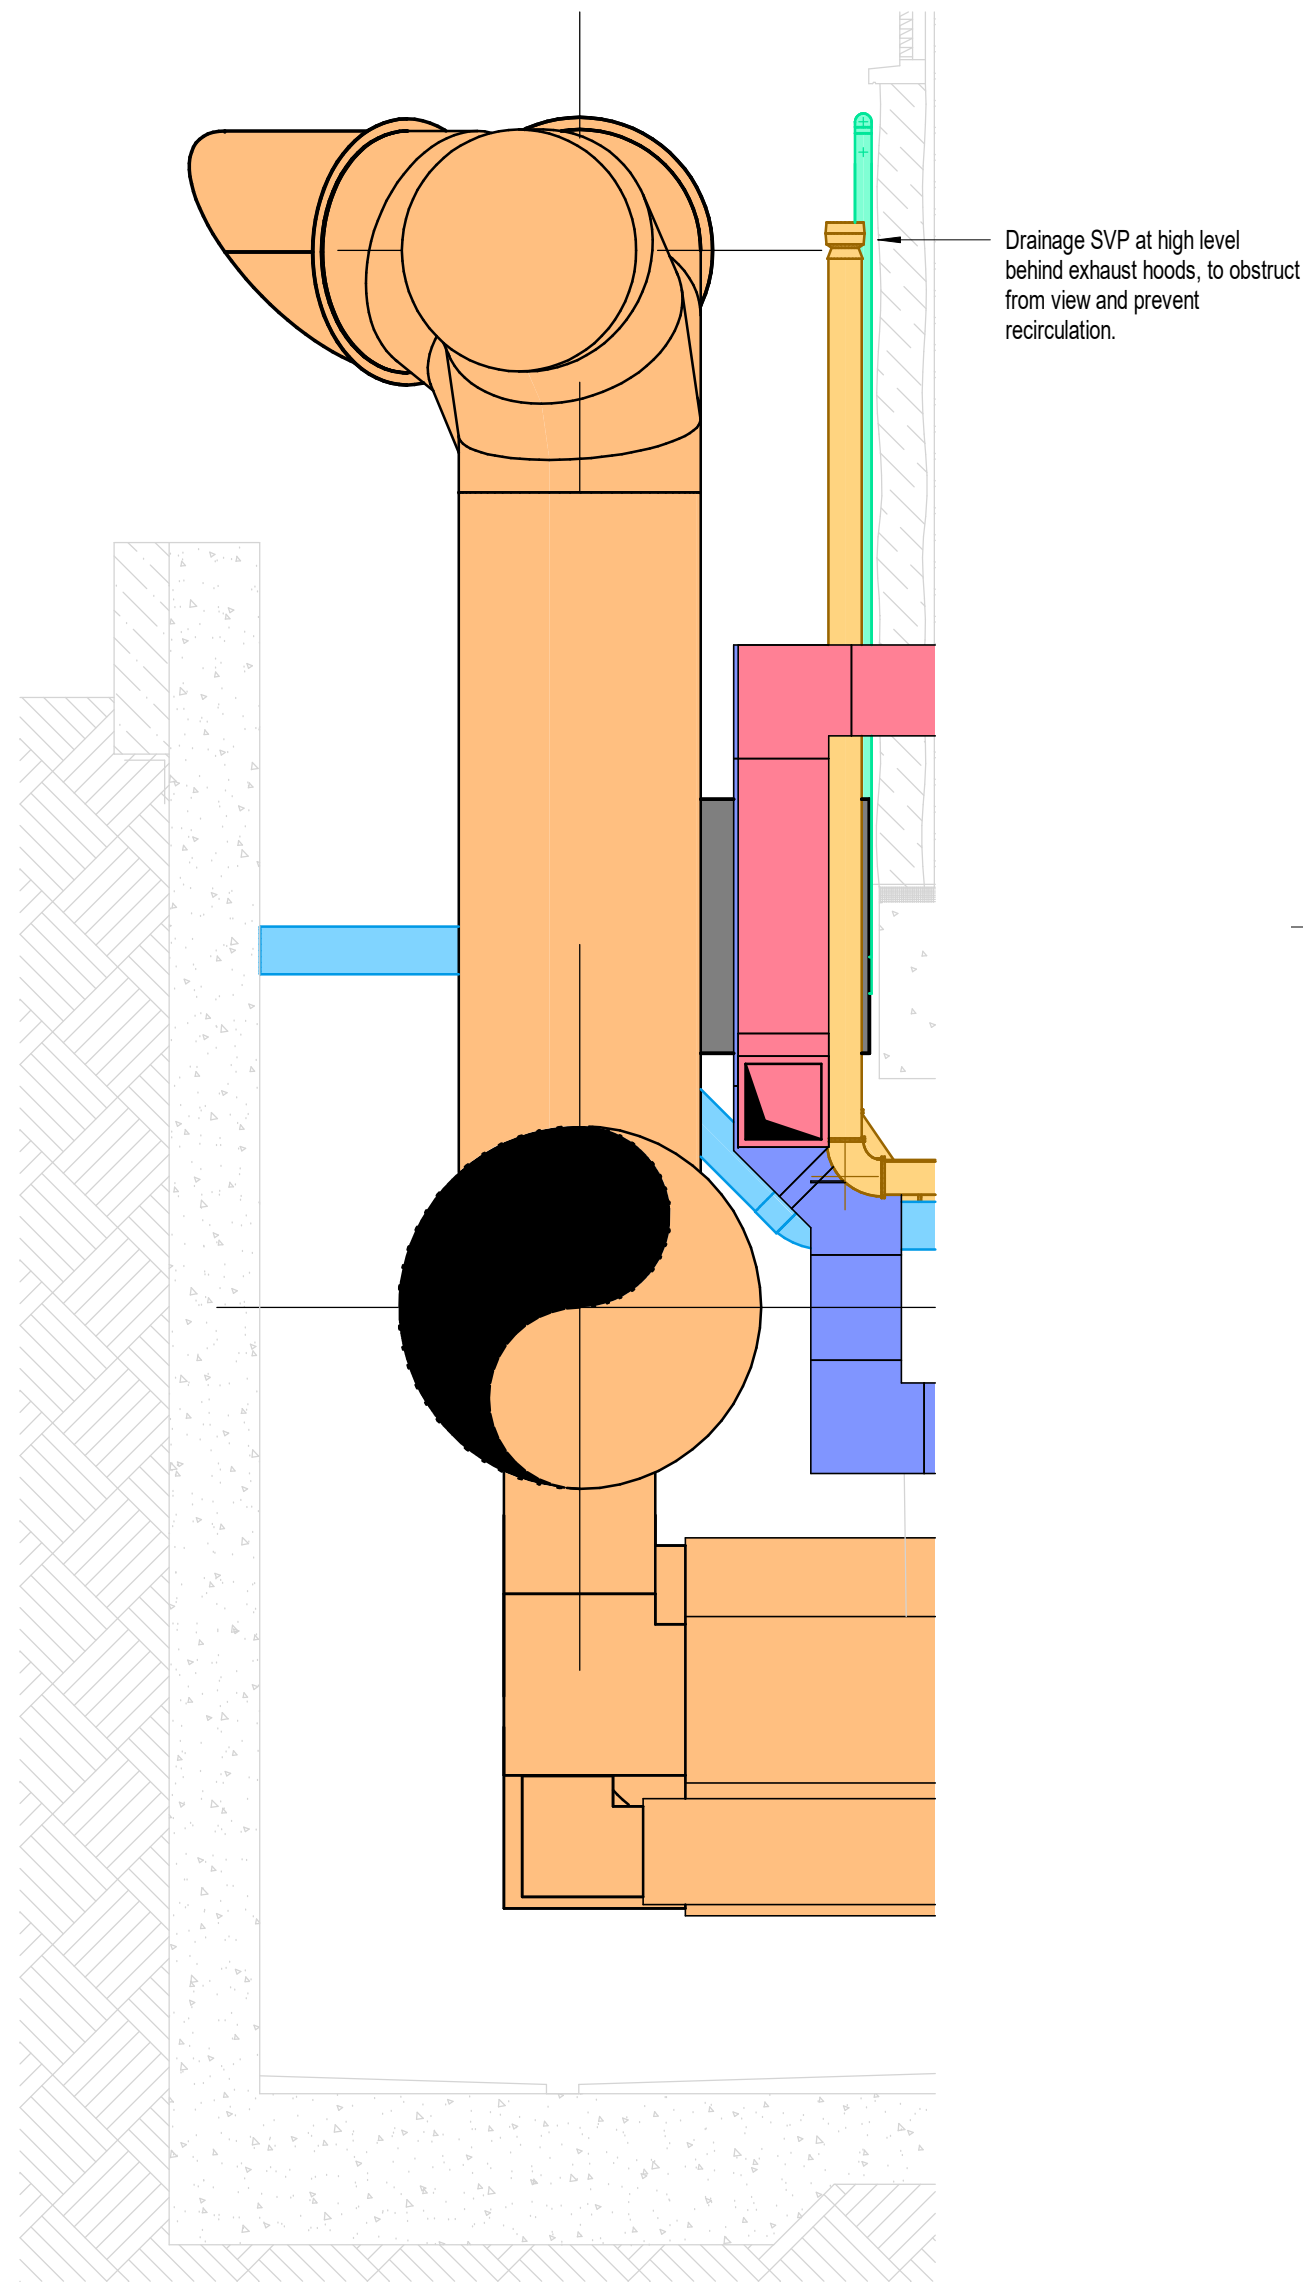

2 External Ductwork In Section
1:25

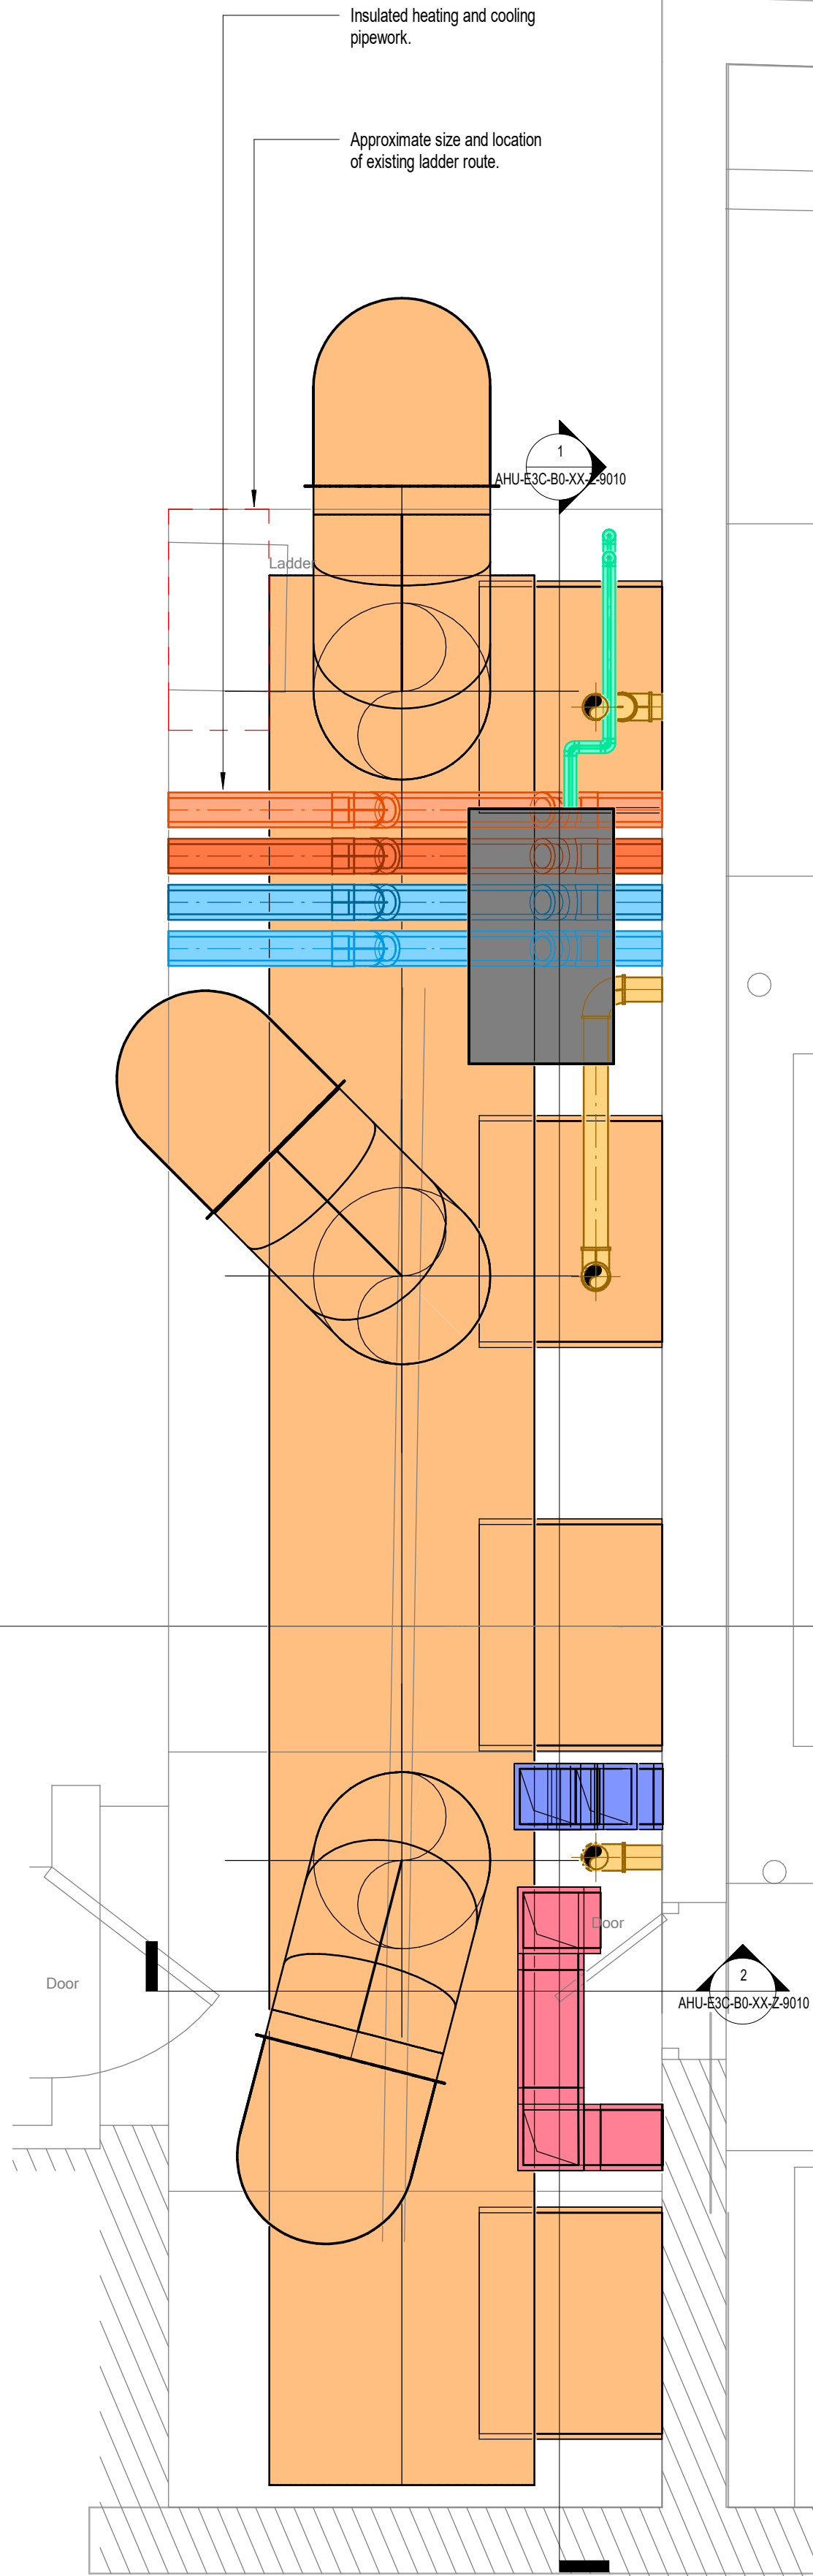

3 AHU Plantroom Proposed Ventilation Layout
1:25



- Do not scale from this drawing.
All dimensions to be confirmed on site.
- Notes
- To be read in conjunction with all associated drawings, schedules, reports and specifications.
 - This is a colour drawing, refer to mechanical and electrical symbol sheets and colour keys.
 - The contractor is to refer to the latest fire strategy and ensure full compliance.
 - The contractor is to agree access requirements with Architect.

P03	S0	16 Mar 26	Preliminary Issue
P02	S0	13 Mar 26	Preliminary Issue
P01	S0	04 Mar 26	Preliminary Issue

Revisions

Client
Whatley Manor Hotel

Architect

MLDE

e³ consulting engineers
QUEEN SQUARE HOUSE, 18-21 QUEEN SQUARE, BRISTOL BS14NH
TEL: 0117 238 0909 www.e3ce.com

Job
Whatley Manor Hotel

Title
AHU and External Ductwork Layouts

Drawing No.
4929-E3C-AHU-B0-D-Z-9010

Scale	Author	Reviewer	Status	Rev.
As indicated @ A1	AB	SC	S0	P03