




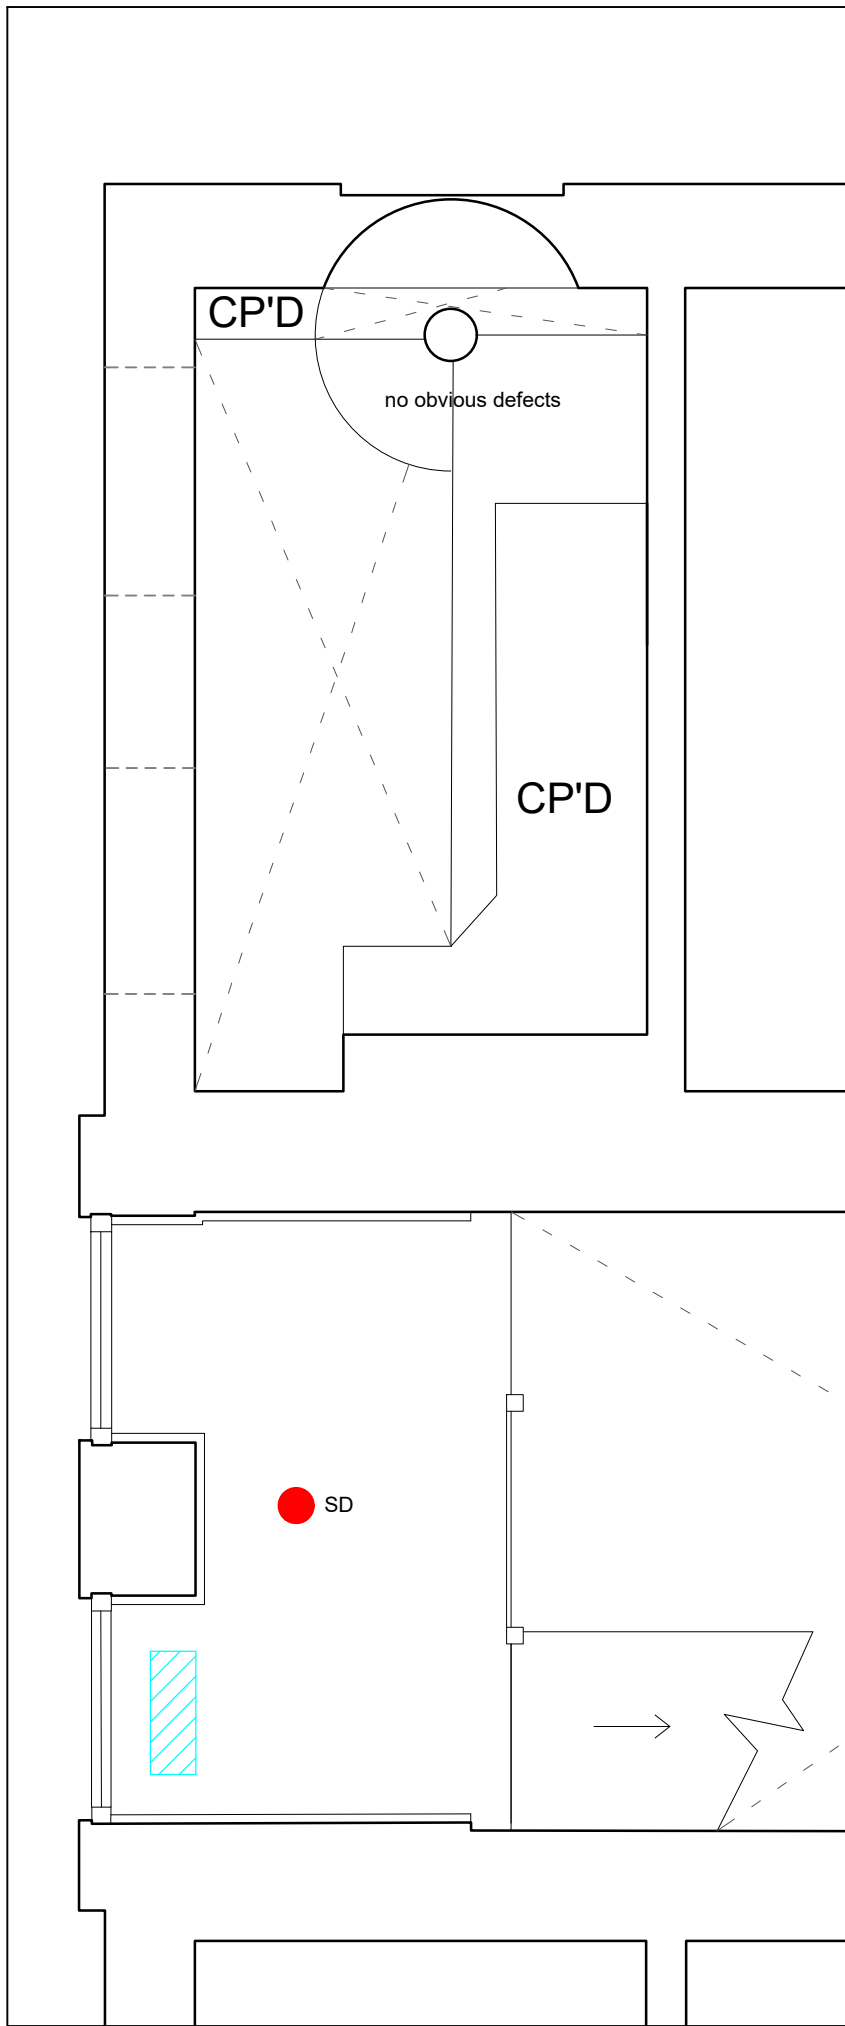

Mezzanine Reflected Ceiling Plan

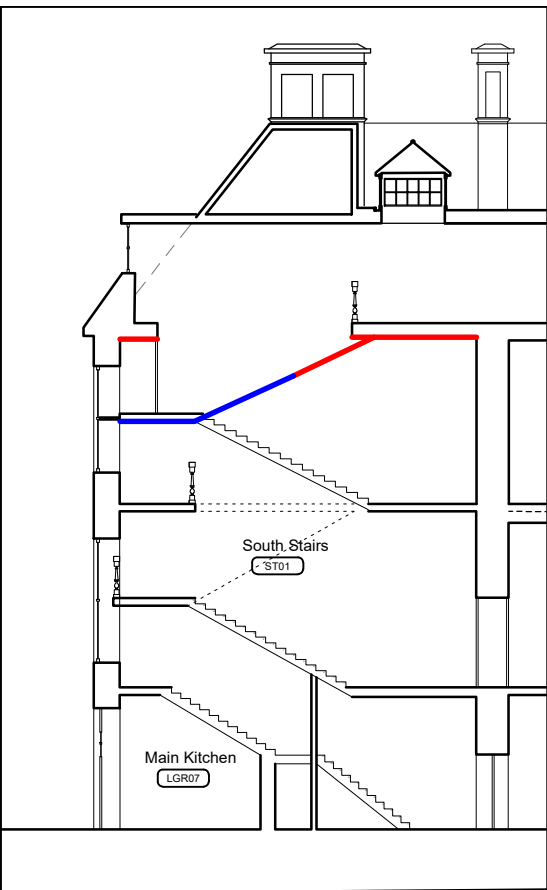

ST01 Ceiling Key Red: First Floor RCP Blue: Mezzanine RCP

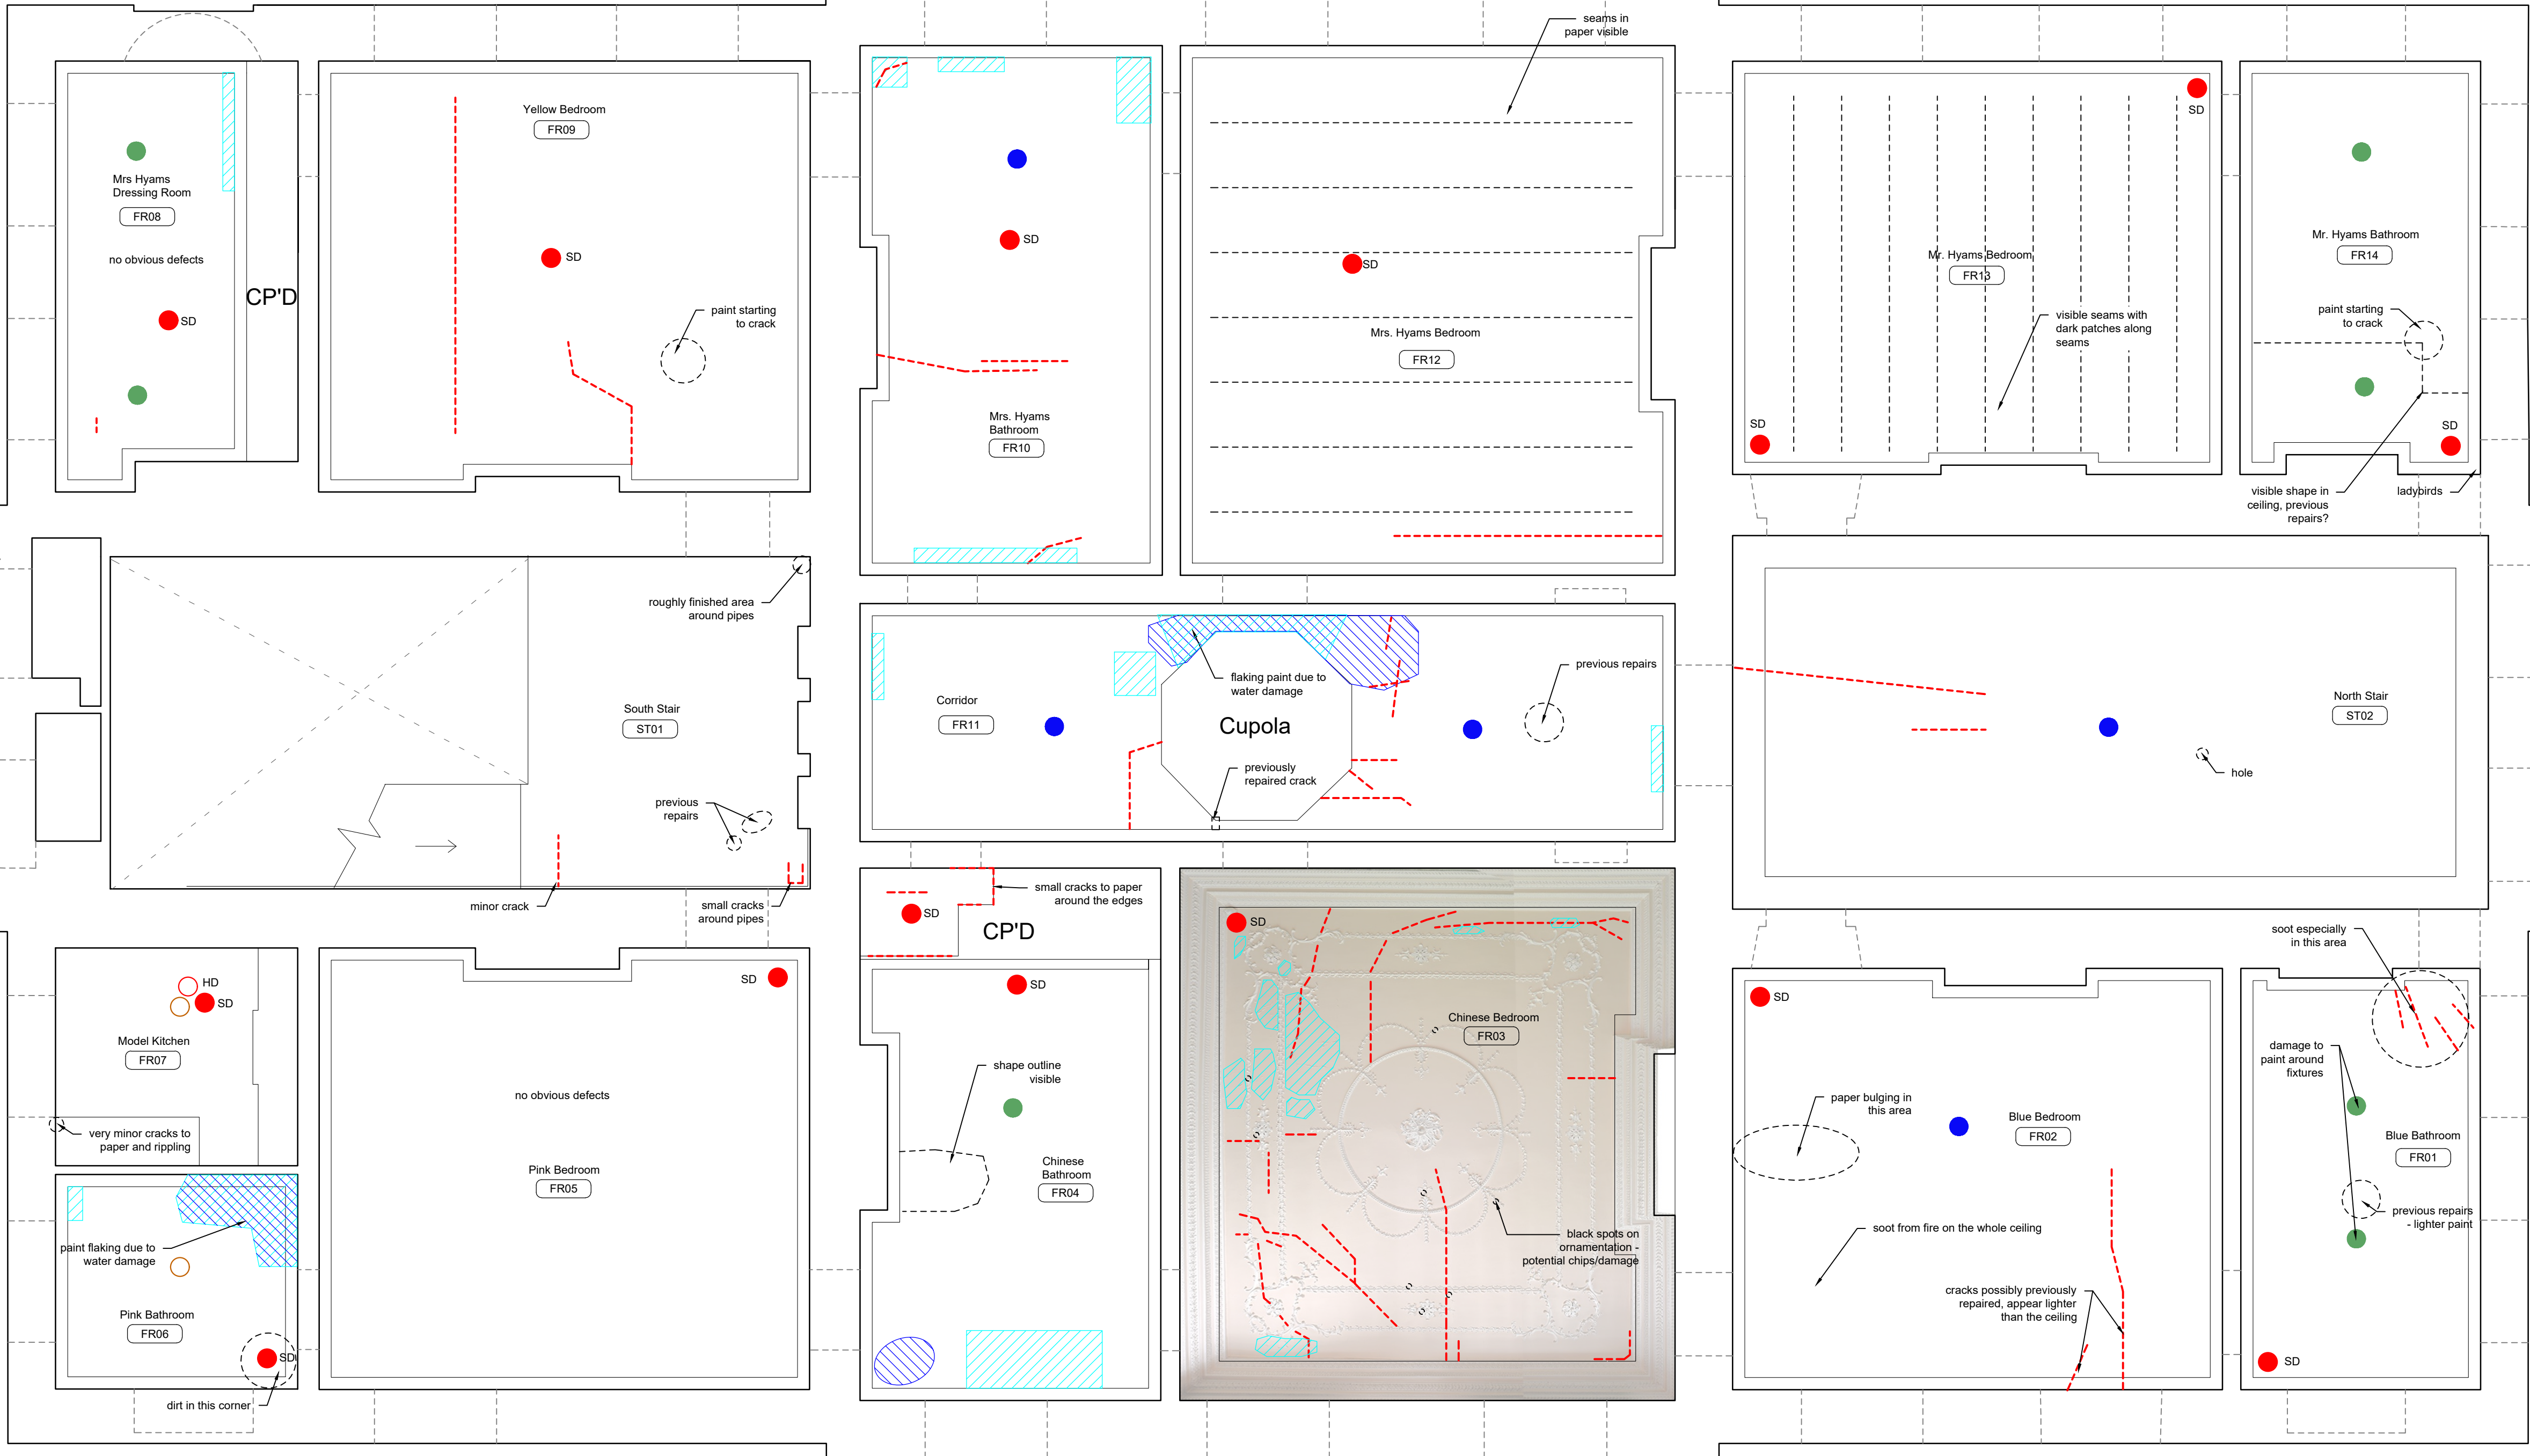

First Floor Reflected Ceiling Plan

DRAWING STATUS		NOTES		Existing elements:		Damage:		REVISIONS		REVISIONS		Status:	
<i>S</i> : Survey = Survey		<i>Do not scale.</i>		□ Light fixture		flaking		* 30/04/26 Issued for LBC		PC		ISSUED FOR LBC	
<i>O</i> : Outline = Outline/Scheme Drawings for proposals, budgets etc.		Contractor or subcontractor to check all dimensions on site before building or manufacture.		● Hook for chandelier		water damage						Project: Ramsbury Manor 263 HE RMI	
<i>D</i> : Development = Final Design drawings for approvals, billing, etc.		All drawings to be read in conjunction with all other professional drawings and specification.		● Hook for large chandelier		cracks						Title: RCP Conditions Survey First Floor	
<i>P</i> : Planning = Drawings issued for Planning, Listed Building, or Local Authority Consents		Based on surveys carried out by:		● Chandelier type fitting		other damage						Scale(A1): 1:50 Scale(A3): 1:100 Drawn: NH Checked: PC	
<i>C</i> : Construction = Fully developed drawings issued under instruction for construction				← Ceiling slope direction (up)								Project Ref: 263 HE RMI 442 Orig no: Revision: Created: 18/10/25	
<i>B</i> : Building Control				● Smoke detector								PEREGRINE BRYANT ARCHITECTURE & BUILDING CONSERVATION	
<i>T</i> : Tender				● Heat detector								The Courtyard, Fulham Palace, Bishop's Avenue, London SW6 6EA T: 020 7384 2111 F: 020 7384 2112 E: info@peregrine-bryant.co.uk	
ST01 Ceiling Key				— Services				rev date notes		chk rev date notes		chk	