

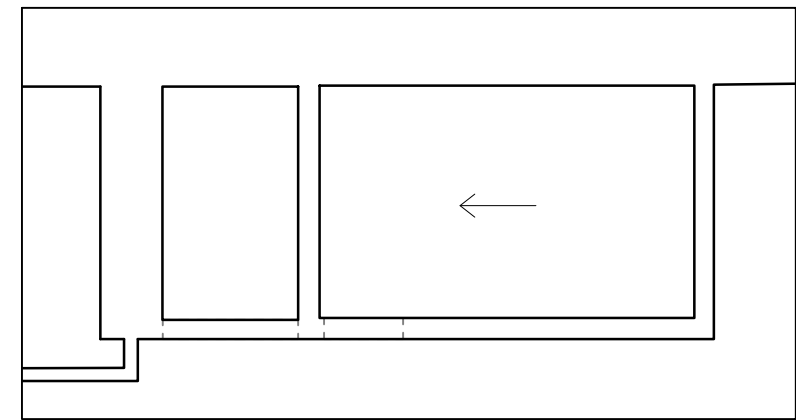
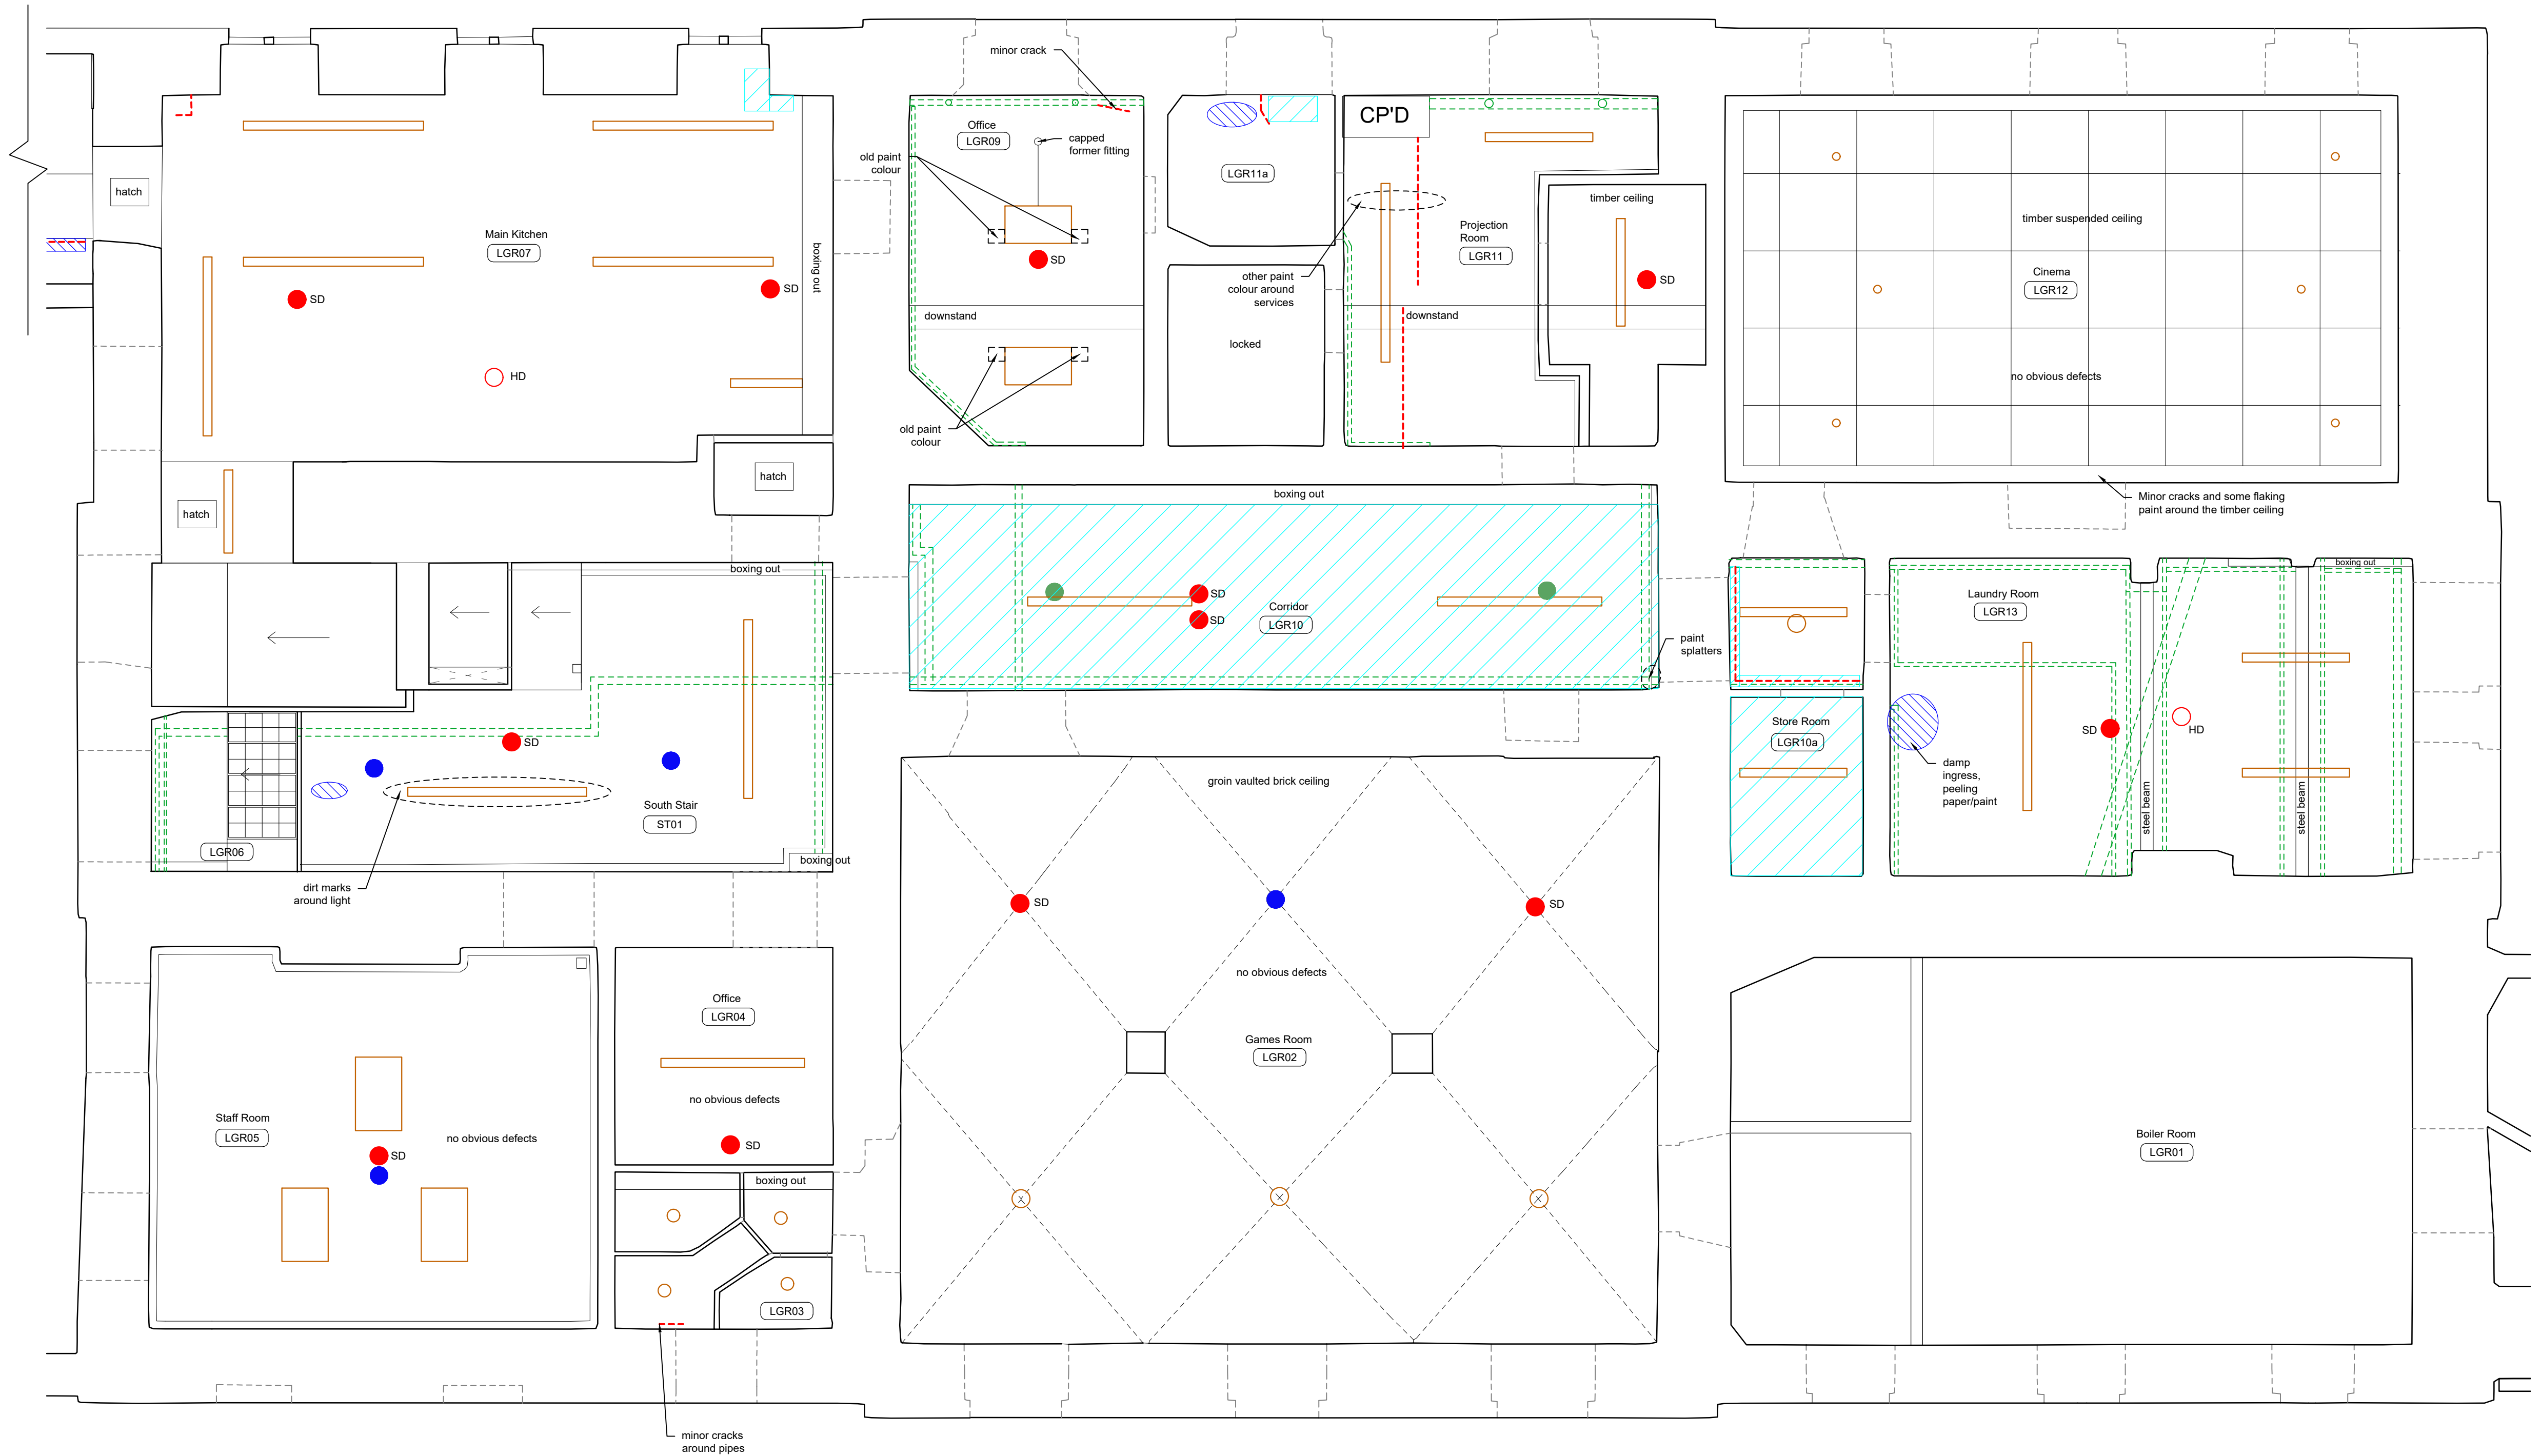


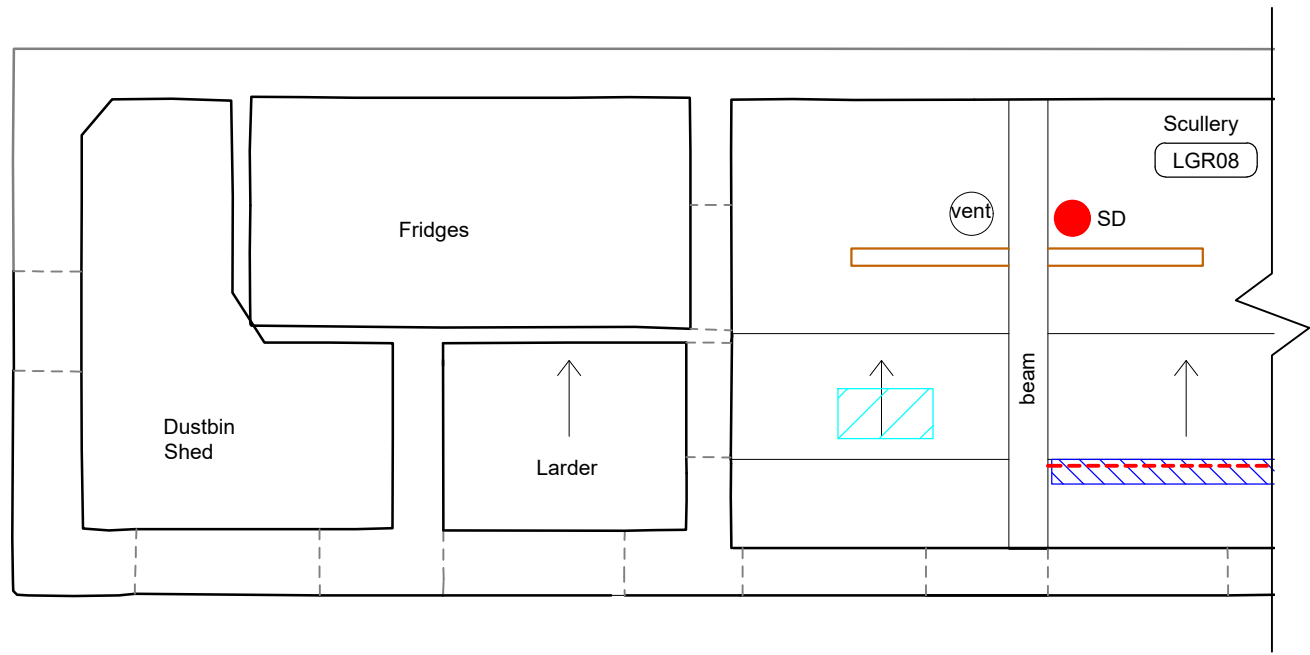

Cupboard Reflected Ceiling Plan

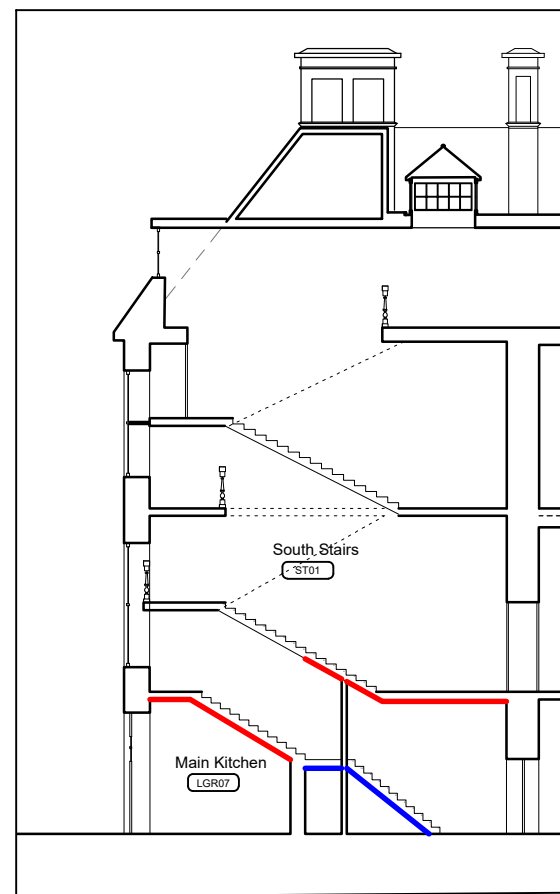

ST01 Ceiling Key Red: Lower Ground Floor RCP
Blue: Cupboard RCP

Lower Ground Floor Reflected Ceiling Plan

DRAWING STATUS

S: Survey = Survey
O: Outline = Outline/Scheme Drawings for proposals, budgets etc.
D: Development = Final Design drawings for approvals, billing, etc.
P: Planning = Drawings issued for Planning, Listed Building, or Local Authority Consents
C: Construction = Fully developed drawings issued under instruction for construction
B: Building Control
T: Tender
I: Information only

NOTES

Do not scale.
Contractor or subcontractor to check all dimensions on site before building or manufacture.
All drawings to be read in conjunction with all other professional drawings and specification.
Based on surveys carried out by:

Existing elements:

- Light fixture
- Hook for chandelier
- Hook for large chandelier
- Chandelier type fitting
- ← Ceiling slope direction (up)
- Smoke detector
- Heat detector
- Services

Damage:

- flaking
- water damage
- cracks
- other damage

SCALE BAR

0 500mm 1000mm 2000mm



REVISIONS

rev	date	notes
*	30/04/26	Issued for LBC

REVISIONS

chk	rev	date	notes

Status: ISSUED FOR LBC

Project:	Ramsbury Manor 263 HE RMI
Title:	RCP Conditions Survey Lower Ground Floor
Scale(s):	Scale(s):
1:50	1:100
Drawn:	NH
Checked:	PC
Project Ref:	263 HE RMI 440
Orig. no:	
Revision:	*
Created:	18/10/25
PEREGRINE BRYANT ARCHITECTURE & BUILDING CONSERVATION	
The Courtyard, Fulham Palace, Bishop's Avenue, London, SW6 6EA T: 020 7384 2111 F: 020 7384 2112 E: info@peregrine-bryant.co.uk	