


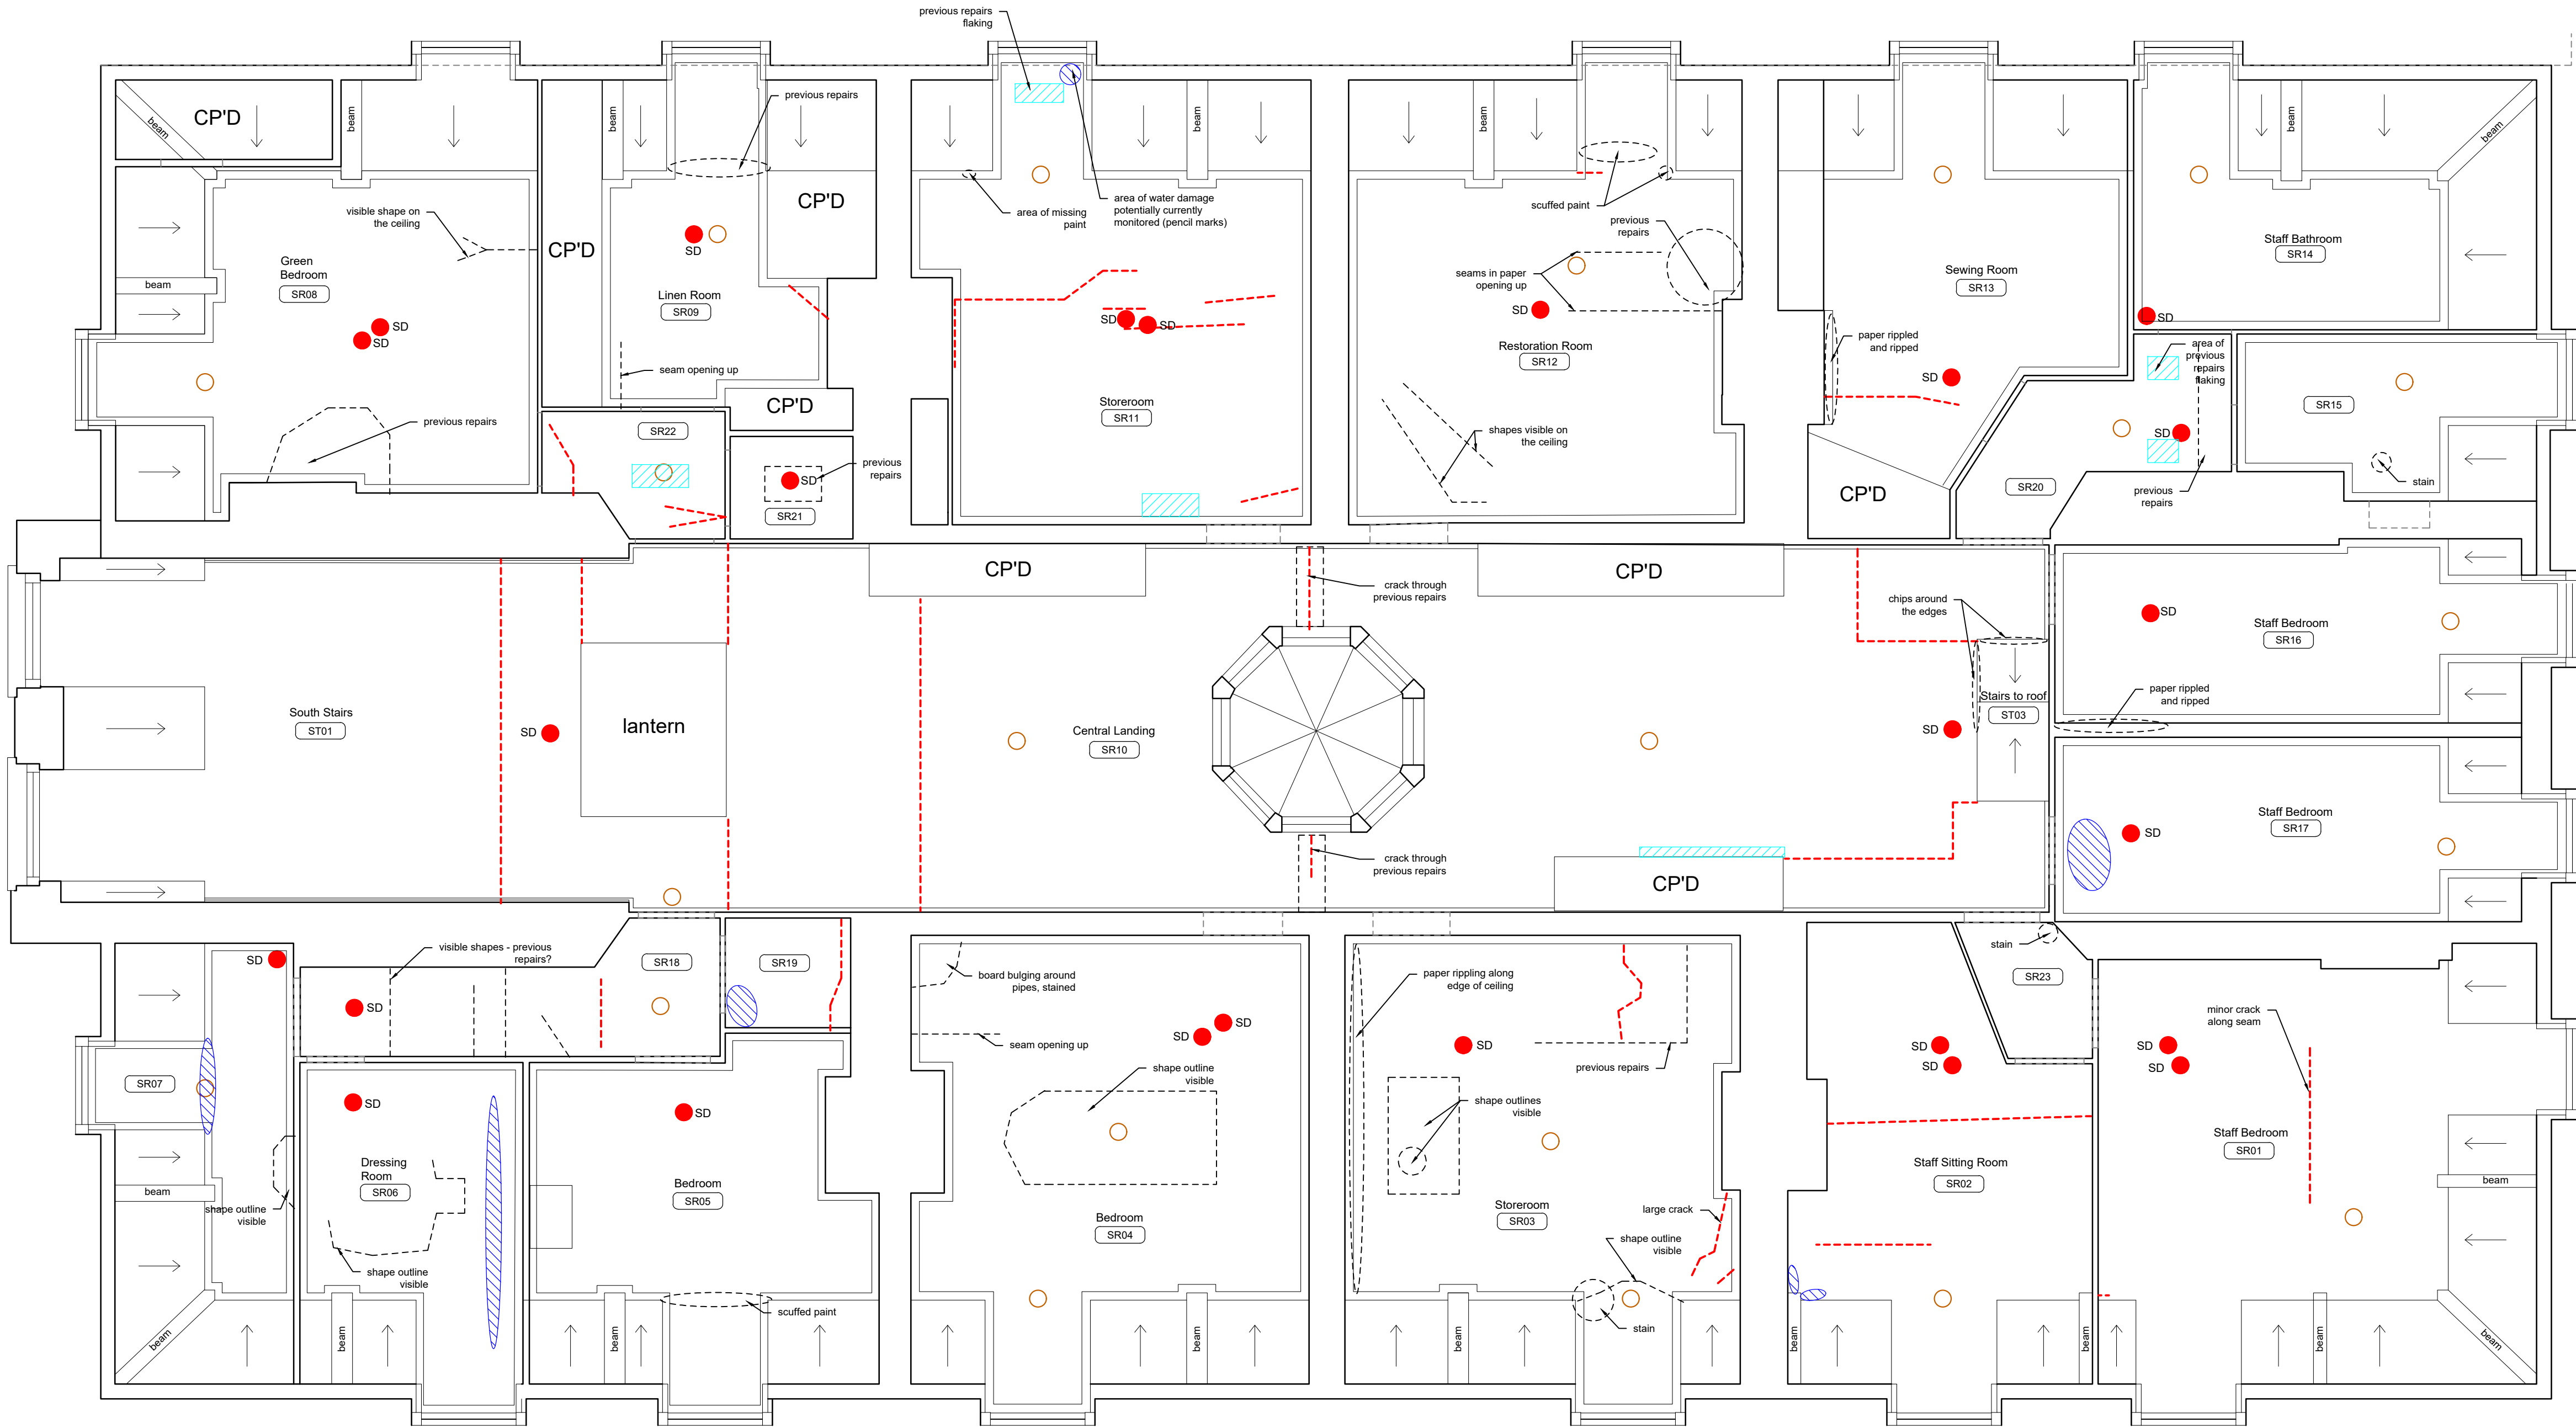

Second Floor Reflected Ceiling Plan

DRAWING STATUS		NOTES		SCALE BAR		REVISIONS		REVISIONS		Status: ISSUED FOR LBC	
<i>S</i> : Survey = Survey <i>O</i> : Outline = Outline/Scheme Drawings for proposals, budgets etc. <i>D</i> : Development = Final Design drawings for approvals, billing, etc. <i>P</i> : Planning = Drawings issued for Planning, Listed Building, or Local Authority Consents <i>C</i> : Construction = Fully developed drawings issued under instruction for construction <i>B</i> : Building Control <i>T</i> : Tender <i>I</i> : Information only		<i>Do not scale.</i> Contractor or subcontractor to check all dimensions on site before building or manufacture. All drawings to be read in conjunction with all other professional drawings and specification. Based on surveys carried out by:		Existing elements: ○ Light fixture ● Hook for chandelier ● Hook for large chandelier ● Chandelier type fitting ← Ceiling slope direction (up) ● Smoke detector ○ Heat detector — Services Damage: flaking water damage cracks other damage		0 50mm 100mm 200mm N		* 30/04/26 Issued for LBC PC		Project: Ramsbury Manor 263 HE RMI Title: RCP Conditions Survey Second Floor Scale@A1: 1:50 Scale@A3: 1:100 Drawn: NH Checked: PC Project Ref: 263 HE RMI 443 Orig. no.: Revision: 1/08/25 Created: 1/08/25 PEREGRINE BRYANT ARCHITECTURE & BUILDING CONSERVATION The Courtyard, Fulham Palace, Bishop's Avenue, London SW6 6EA T: 020 7384 2111 F: 020 7384 2112 E: info@peregrine-bryant.co.uk	
rev	date	notes	chk	rev	date	notes	chk	rev	date	notes	chk