
 




-  Bin store
-  Cycle store
-  Vehicle recharging point
-  ASHP Air Source Heat Pump

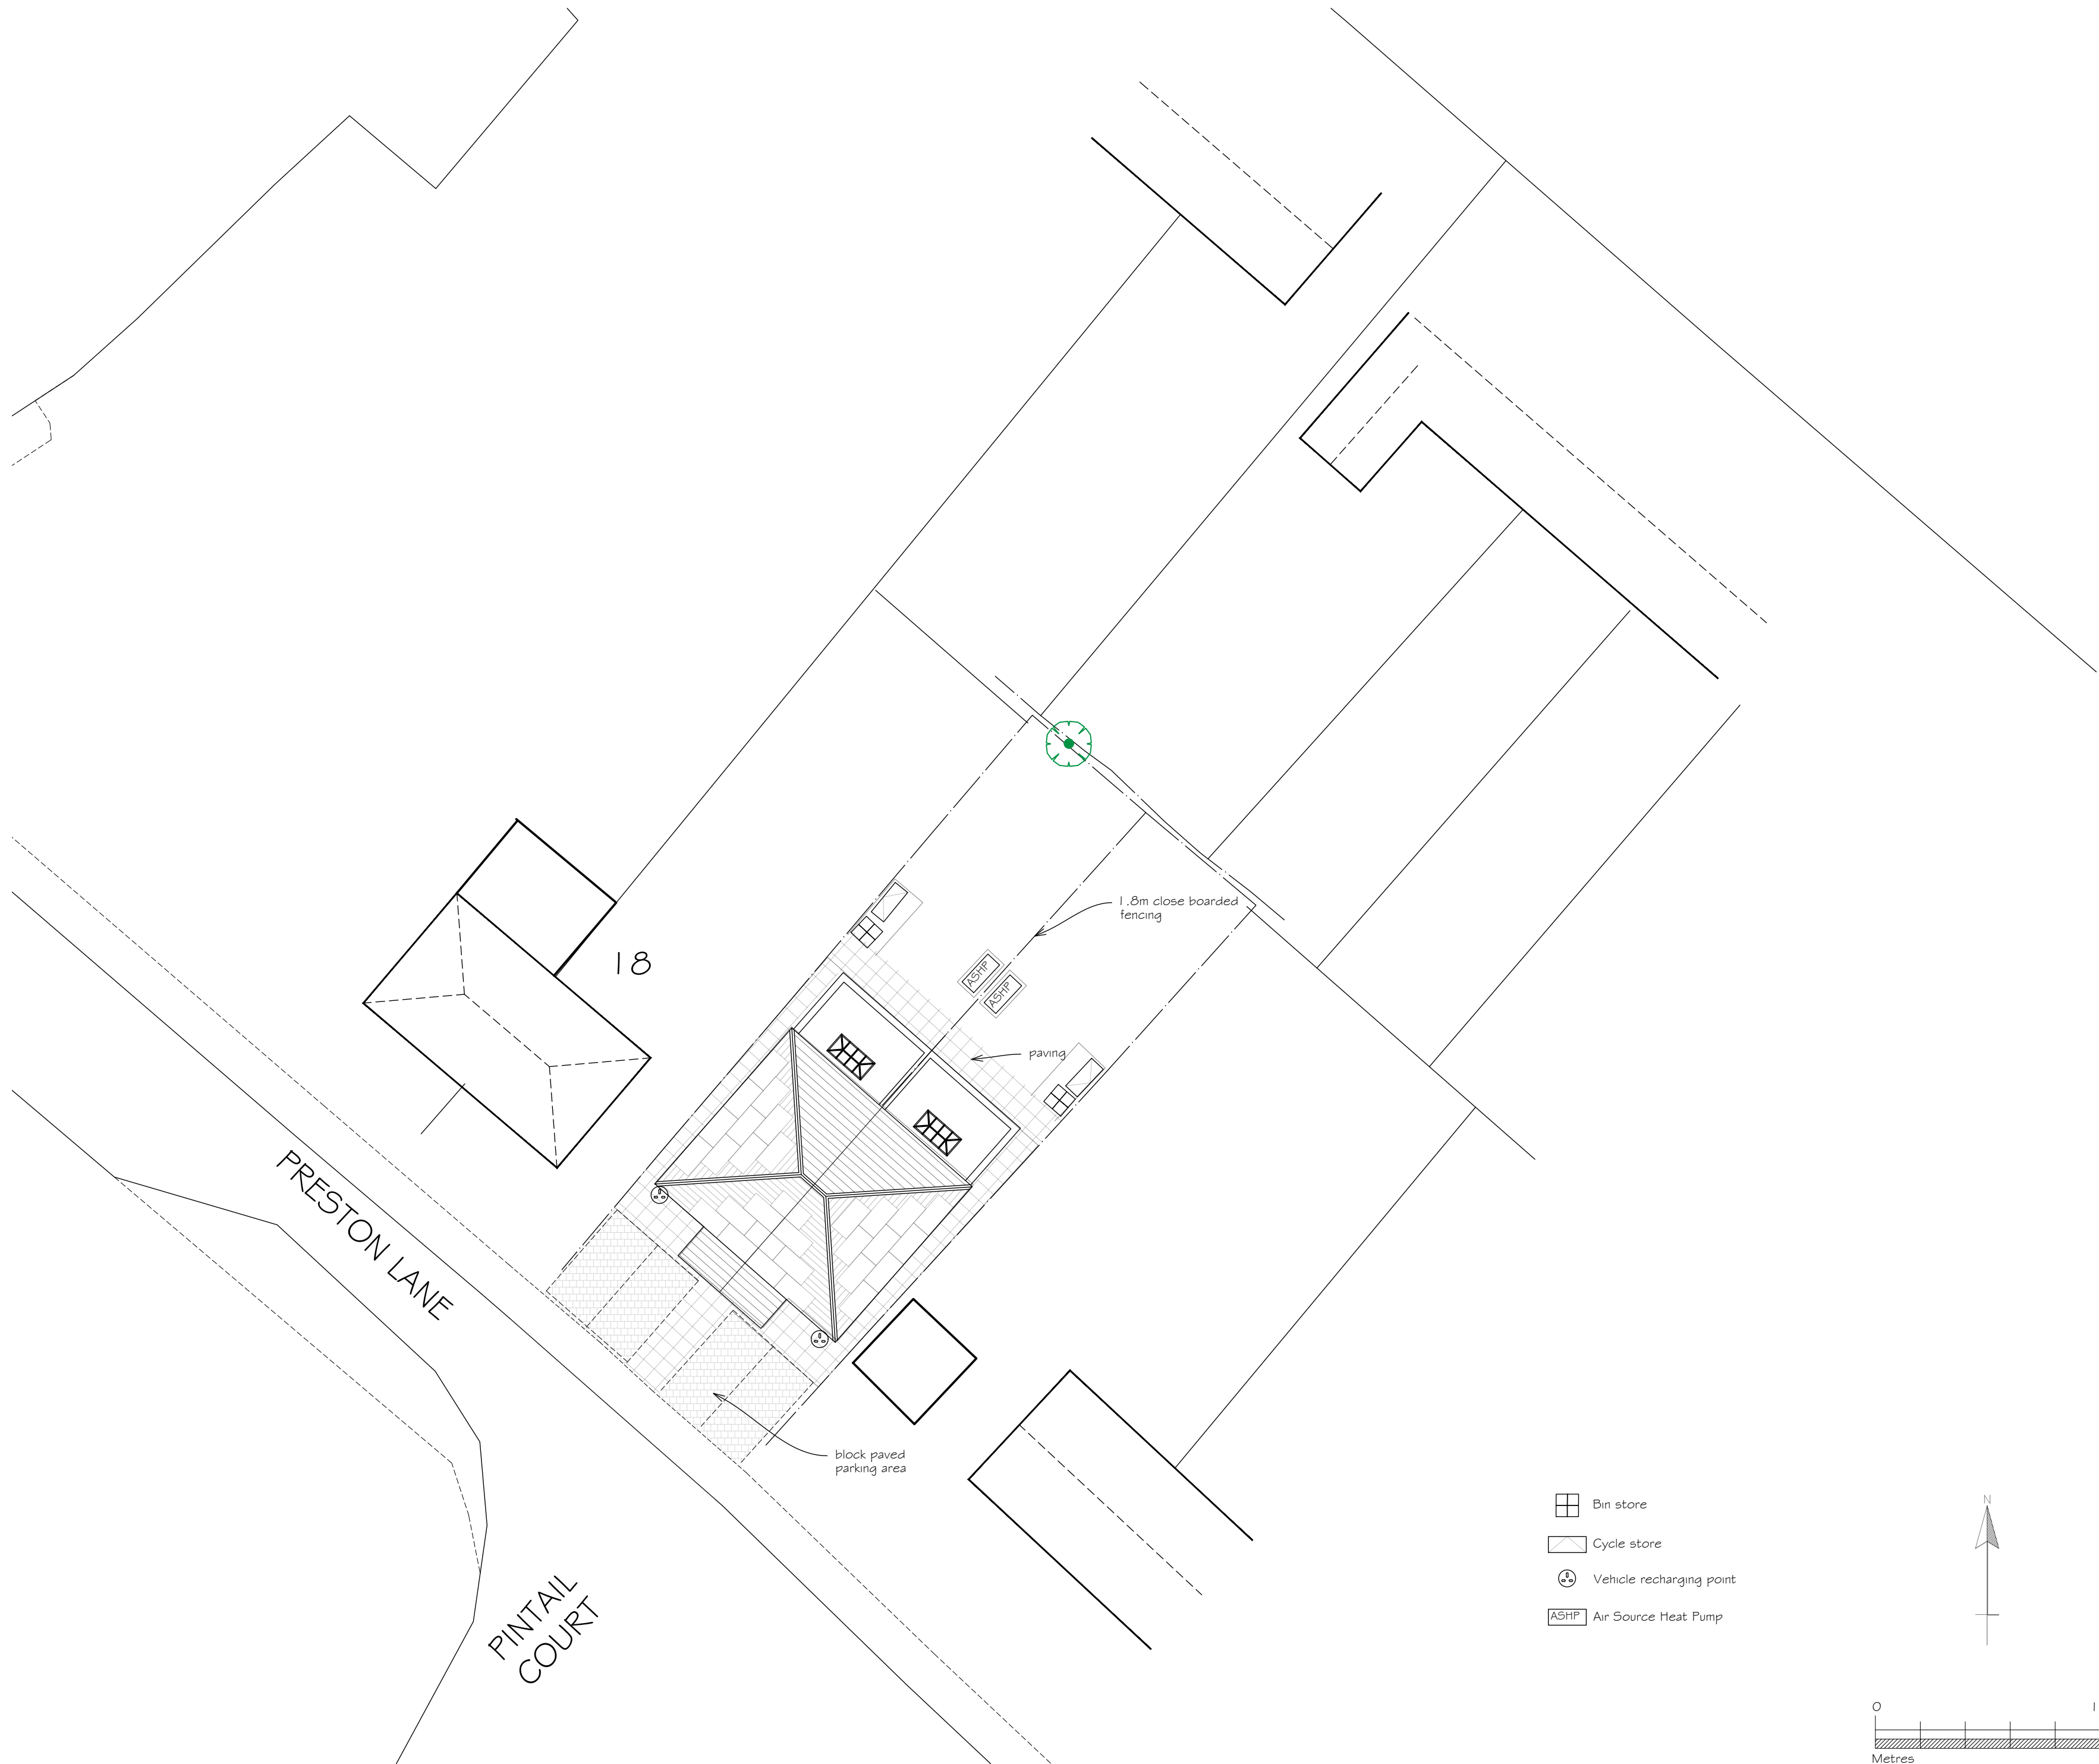



**TOWN AND COUNTRY
PLANNING
DEVELOPMENT
CONSULTANTS**

LPC (TRULL) LTD.,
TRULL, TETBURY, GLOUCESTERSHIRE GL8 8SQ
Tel: 01285 841433 email: admin@lpc-trull.com

Client
Mr L Alabi

Project
18 Preston Lane, Lyneham,
SN15 4AR

Drawing
Existing Site Plan

Date: March 2026 Scale: 1:200 @ A2
Drawing Number:
LPC 6033 EX 02