


LEGEND

LIGHT FITTINGS		Directional Recessed Down Light.
		Non-directional Recessed Down Light.
		Ceiling Mounted Fitting. (used with a text symbol above)
		Directional Surface-Mounted Spotlight.
		Surface-Mounted Spotlight.
		LED Batten Lighting.
		W/L Wall Mounted Fitting.
		P/L Picture light.
		R/L Reading light.
		Recessed UpLight
		Floor Mounted UpLight.
		LED Horizontal Linear LED Strip.
		Concealed Lighting. Vertical LED light strip with contact closer switch.
		Recessed Wall Light / Steplight
		Table lamp (used with Sump power point)
		External Spike Light.
		External Bollard Light
		Table light small square
		Table lamp medium square (used with Sump power point)
		Table lamp large square (used with Sump power point)
		LED curve straight downlight
		LED single colour tape light
		Fs Floor standing light
		Fs Floor standing light
		Table light small round
		Table light medium round
		Table light large round
		Low level courtesy light
		Decorative mirror light
		Decorative wall light
		Cero straight IP rated downlight
		Curve mini downlight
		Curve midi downlight
		Decorative wall light
		Decorative wall light
		Decorative wall light
		Decorative wall light
		LED adjustable downlight
		LED Panas downlight
		M11 LED adjustable stirup mounted spot
		Decorative mirror light
		Decorative mirror light
		Decorative ceiling pendant
		Banister torchere
		Suspension light-rod

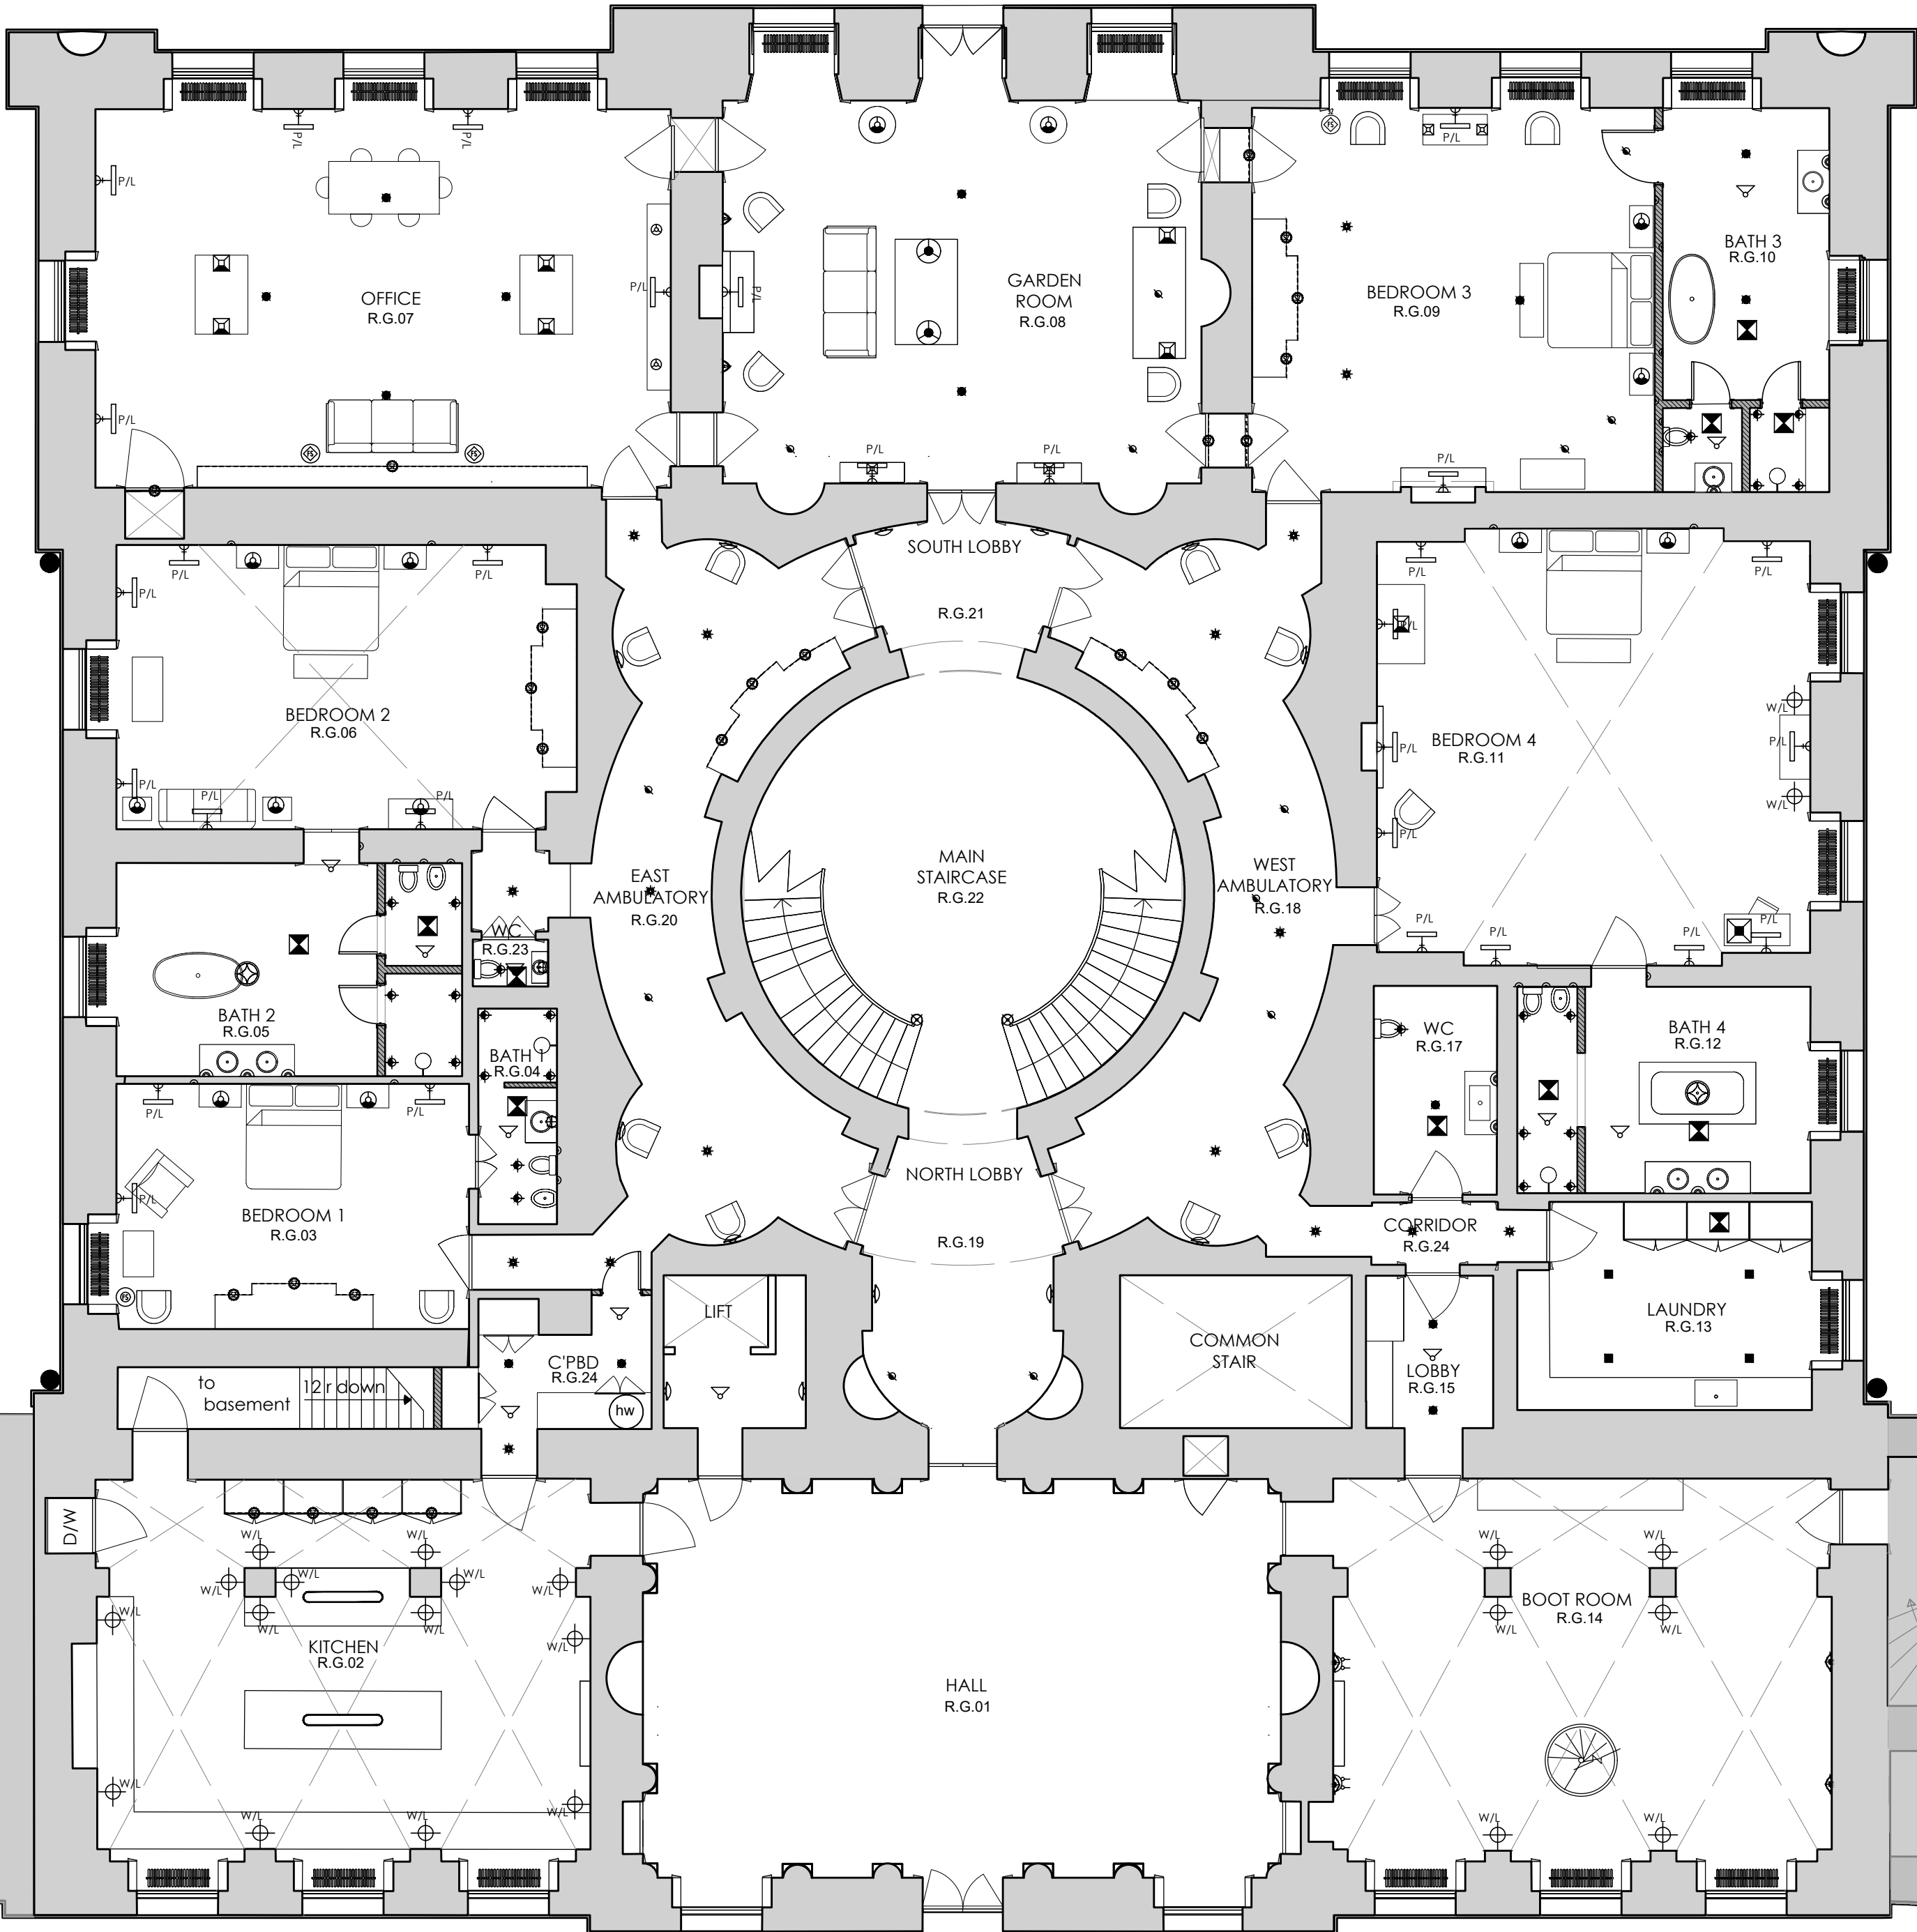

LIGHT FITTINGS TEXT	P	Depicts a pendant fitting when used with a ceiling fitting below.
	B	Depicts a bulkhead fitting when used with a ceiling fitting below.
	IP	Depicts an Ingress Protection rated fitting when used with a light fitting below.
	E	Depicts an emergency light when used with a fitting below.
LIGHTING CONTROL	Ex	Depicts an External light when used with a fitting below.
	CX	Circuit Reference.
	LKP	Lighting Control Keypad.
	CX-XX	Standard Lighting Switch.
POWER FITTINGS		PIR Motion Sensor for light fitting.
	D	Depicts a dimmer switch when used with a standard switch above.
	T	Depicts a timer switch when used with a standard switch above.
	2 3	Depicts either a two way or three way light switch.
		Door/Movement Operated Switch
	TV	TV Outlet.
	WAP	Wireless Access Point.
	D	Data Point.
	BT	Telephone Outlet.
		Single 13amp Power Socket.
		Double 13amp Power Socket.
		Double 13amp Power Socket above counter level.
POWER FITTINGS	USB	USB Point when used with a power socket above.
	EX	External Power Point when used with a power socket above.
	5	5amp Power Socket (used with circuit reference)
		Un-switched Fused Spurs.
		Switched Fused Spurs.
		Floor box (used with symbols above).
		Shaver Socket.
		Extract fan.
		Demister Heat Pad Fitted Behind Mirror.
	WT	Motorised Window Treatment.
		Isolator Switch.
		Lift Control - Landing Operating Panel.
POWER FITTINGS		Mobile Signal Booster Antenna.
		LAUNDRY Clock point

A1 Sheet Size

NOTES

1. All dimensions and levels are to be checked on site by the Main Contractor before work commences. The Architect is to be informed immediately of any discrepancies.
 2. Do not scale this drawing, use written dimensions only.
 3. Larger scale drawings are to be used over smaller scale drawings.
 4. All dimensions are in millimetres unless otherwise stated.
 5. If in doubt ask.
- © Copyright of Mitchell Berry Architects.

Rev	Date	Notes
-----	------	-------

PLANNING

Project New Wardour Castle, Tisbury, Salisbury SP3 6RP

Client Private Client

Title Proposed Ground Floor Plan Central Block Electrical - Lighting & Overhead (High Level)

Scale	1:100@A1	Drawn by	VR
Date	May 26	Checked by	JB

Drawing Number	2517 - P101	Revision	.
----------------	-------------	----------	---

MITCHELL BERRY
ARCHITECTS
THE STUDIO · 9 STRATFORD ROAD · LONDON · W8 6RF
TEL 020 7938 4358
EMAIL studio@mitchellberryarchitects.co.uk

Existing Fabric
Proposed Fabric

