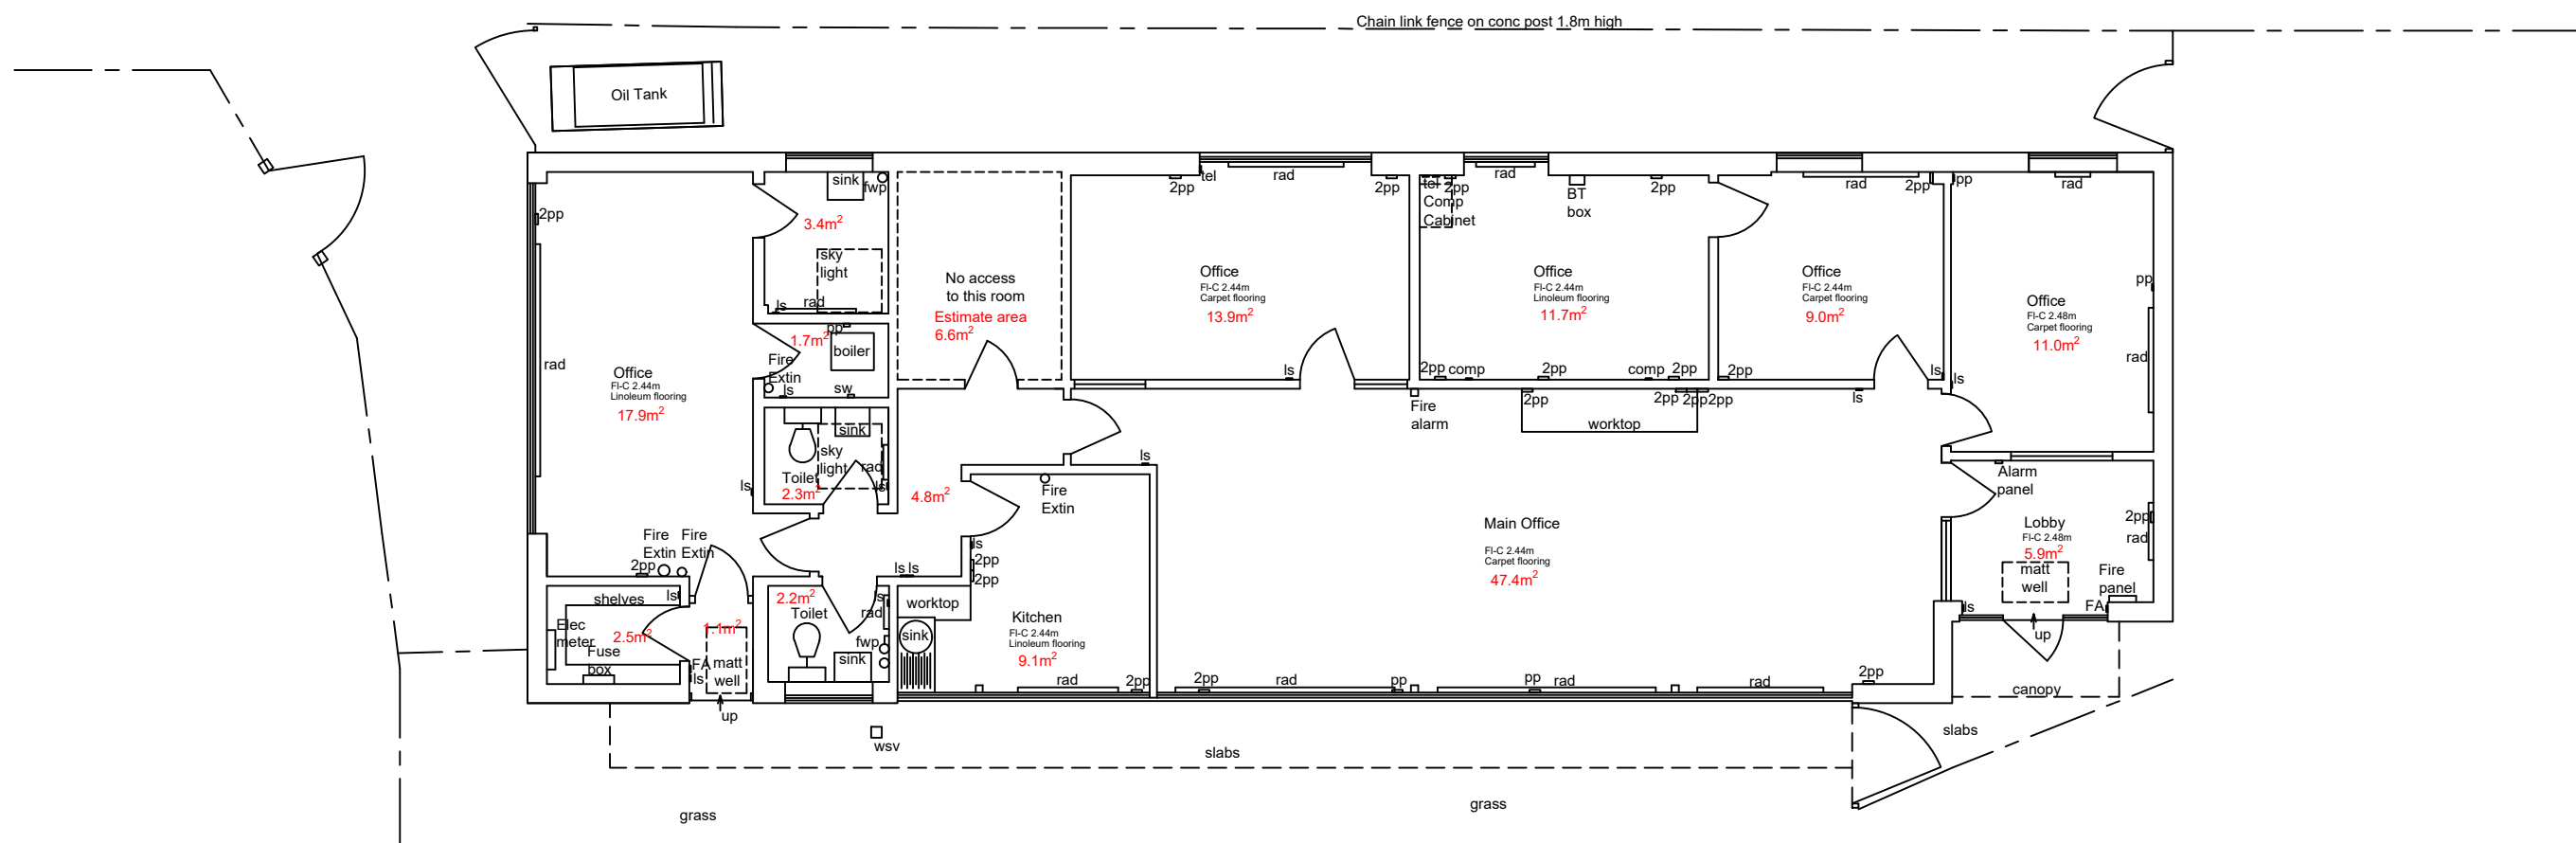
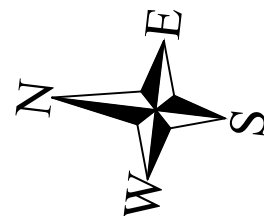


Key
Light switch shown ls
Double power point shown 2pp
Single power point shown pp
Radiator shown rad
Fire alarm push button shown FA
Water stop valve shown wsv

SITE:	Melksham Station Approach Office building - Floor Plan	SCALE:	1:100@A3	DRAWN:	PFS	NOTES:	
		DATE:	April 2026	CAD REF:			