


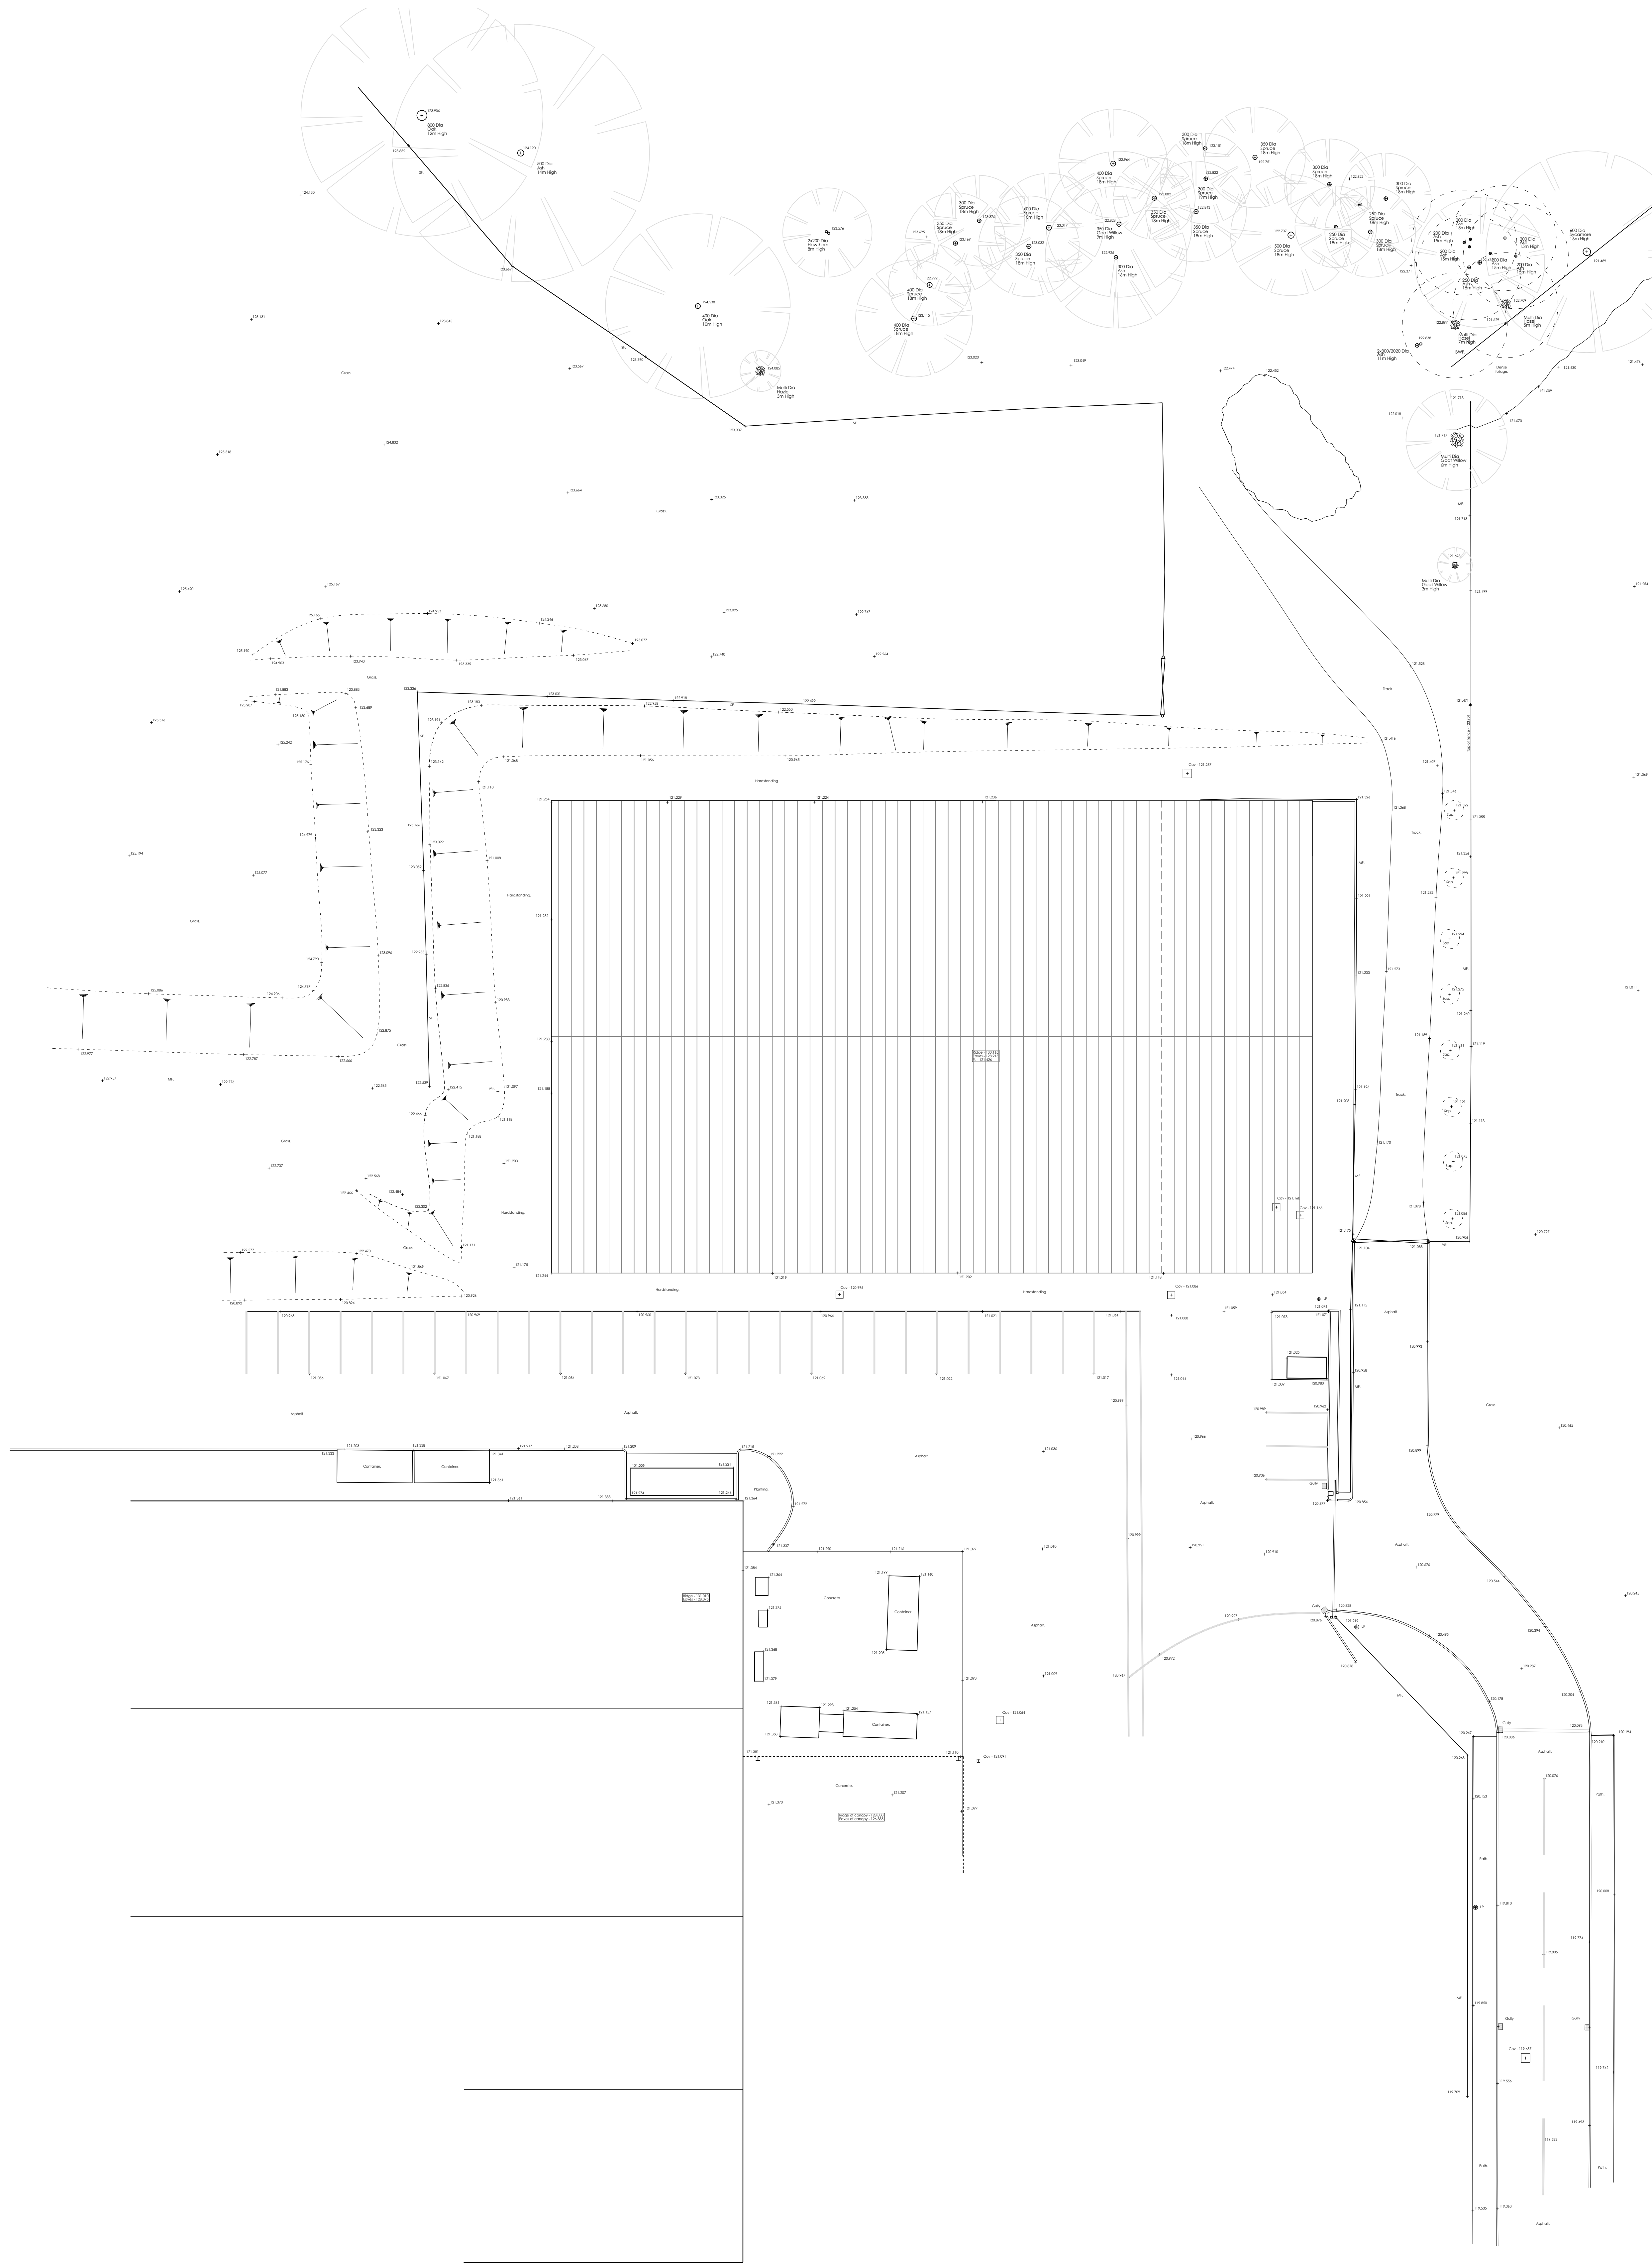

KEY

Contour lines

Roof overhang

FW drainage run

Overhead wires BT


Overhead wires Electricity

Tree (pole and approximate canopy)

Tree off site - indicative canopy

Inspection Chamber cover and invert level

TEXT Key			
	At Valve	IC	Inspection Chamber
	Ballard	INV	Invert Level
	BT Pole	KO	Kerb Outlet
	BT Cover	LP	Lamp Post
WF	Barbed Wire Fence	WM	Water Meter
	Window/Door Cill	FH	Fire Hydrant
TV	Cable Television Cover	OM	Bench Mark
	Cabinet	PB	Post Box
LF	Chain Link Fence	PPF	Post Panel Fence
OV	Cover Level	PRF	Post Rail Fence
	Electric Power Pole	RS	Road Sign
	Eaves Level (u/s fascia)	RWP	Rain Water Pipe
	Fire Hydrant	SVP	Sol Vent Pipe
	Floor Level	SF	Stock Fence
	Fence Post	TL	Traffic Light
	Gully	UTL	Unable To Lift
	Gate Post	WM	Water Meter
	Gas Valve	WST	Water Stop Tap
	Window/Door Head	WO	Wash Out
			Gates

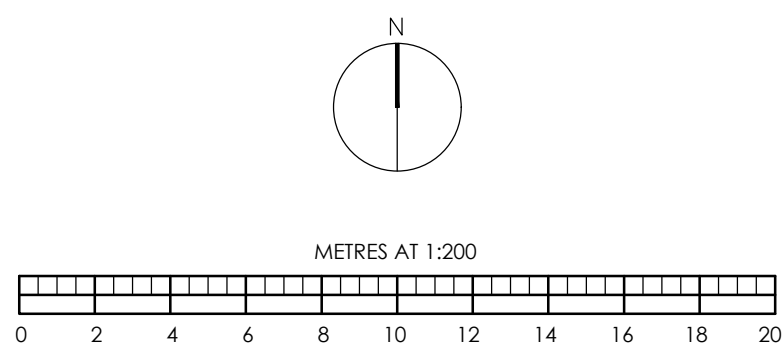

BRIMBLE LEA

Chartered Planning Consultants & Architects

Unit 3, Kingsmead Business Park,
Gillingham, Dorset, SP8 5FB

T (01747) 823232 www.brimblelea.com

PROJECT

Hillbush,
Norwood Park,
Castle Street,
Mere,
BA12 6FE.

DRAWING

Proposed Site Plan

SCALE

1:200 @ A0

DRAWING ORIGINATOR

DWR

DATE

18.11.2025

DRAWING No.

25103 - 5

REVISION

B