

LEGEND


CX	Directional Recessed Down Light.
CX	Non-directional Recessed Down Light.
	Ceiling Mounted Fitting. (used with a text symbol above)
	Directional Surface-Mounted Spotlight.
	Surface-Mounted Spotlight.
	LED Batten Lighting.
	W/L Wall Mounted Fitting.
	P/L Picture light.
	R/L Reading light.
	Recessed UpLight
	Floor Mounted UpLight.
LED	Horizontal Linear LED Strip.
	Concealed Lighting. Vertical LED light strip with contact closer switch.
	Recessed Wall Light / Steplight
	Table lamp (used with Sump power point)
	External Spike Light.
	External Bollard Light
	Table light small square
	Table lamp medium square (used with Sump power point)
	Table lamp large square (used with Sump power point)
	LED curve straight downlight
	LED single colour tape light
	Floor standing light
	Floor standing light
	Table light small round
	Table light medium round
	Table light large round
	Low level courtesy light
	Decorative mirror light
	Decorative wall light
	Cero straight IP rated downlight
	Curve mini downlight
	Curve midi downlight
	Decorative wall light
	Decorative wall light
	Decorative wall light
	Decorative wall light
	LED adjustable downlight
	LED Panas downlight
	M11 LED adjustable stirup mounted spot
	Decorative mirror light
	Decorative mirror light
	Decorative ceiling pendant
	Banister torchere
	Suspension light-rod

Generally:

- All existing ceilings are to be retained unless indicated otherwise.
 - Where downlights are to be removed, the ceiling is to be made good with matching materials.
- Existing Fabric

Proposed Fabric

Proposed Cornices

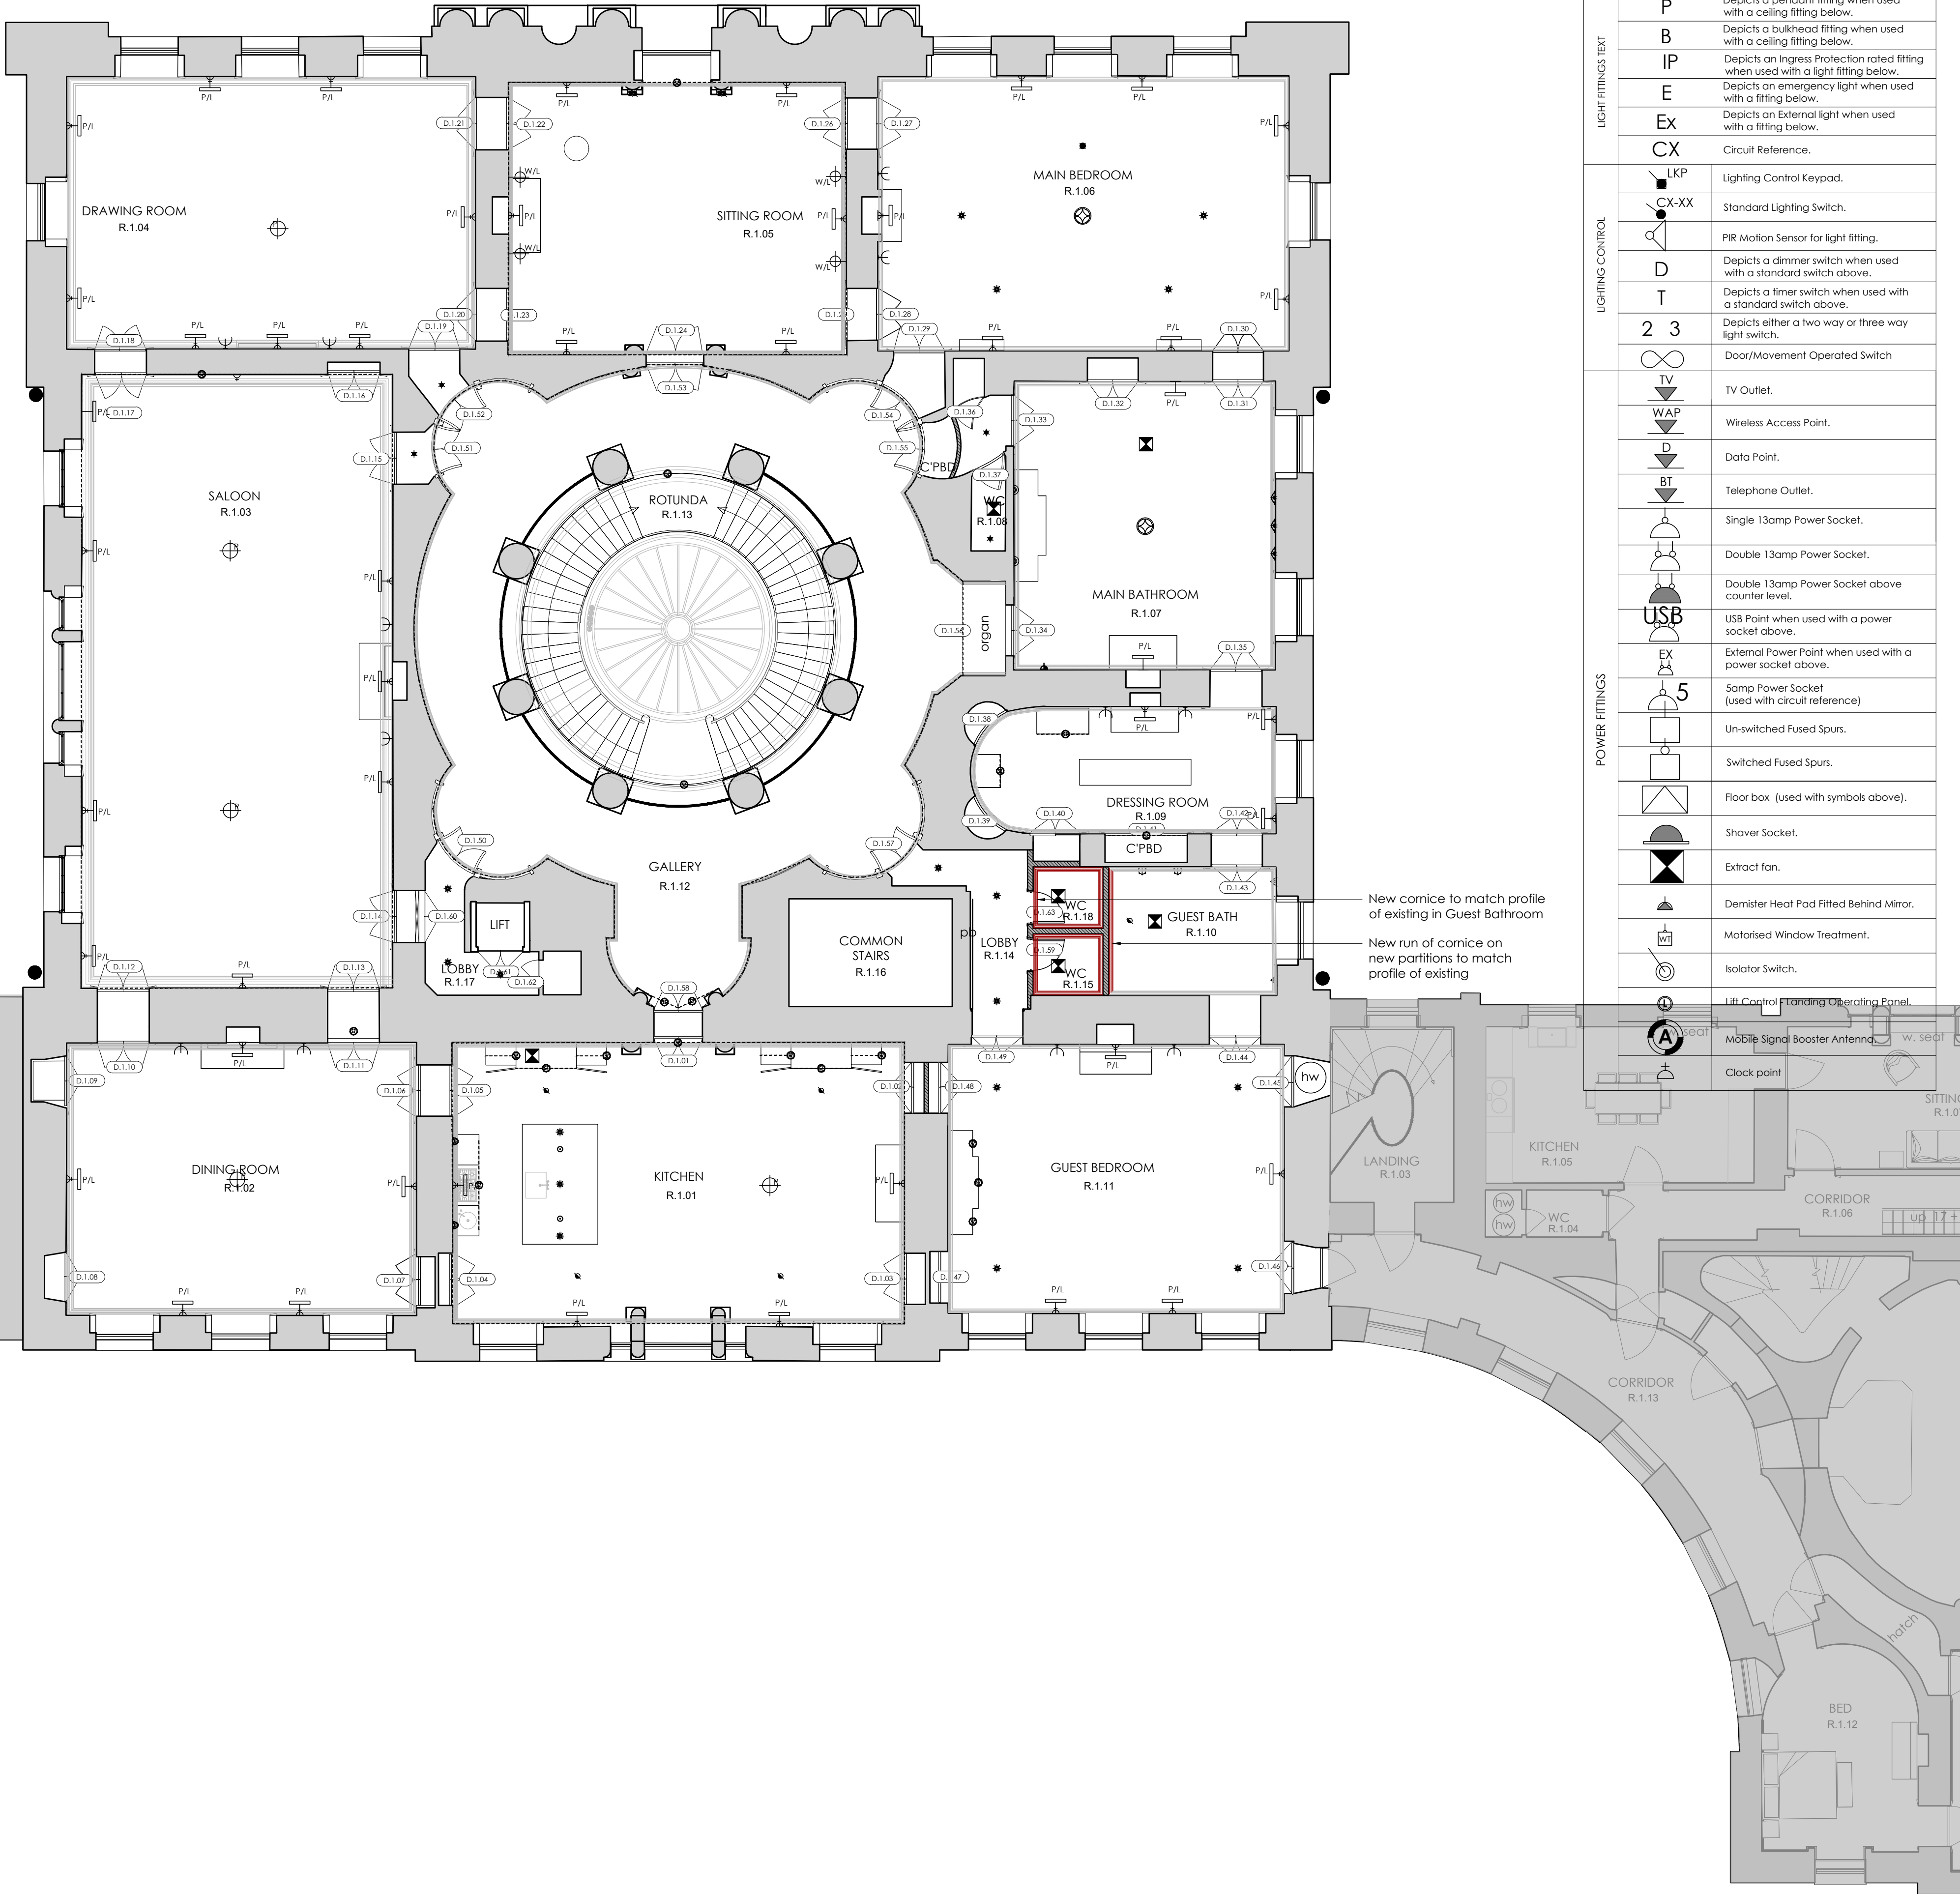

LIGHT FITTINGS TEXT	P	Depicts a pendant fitting when used with a ceiling fitting below.
	B	Depicts a bulkhead fitting when used with a ceiling fitting below.
	IP	Depicts an Ingress Protection rated fitting when used with a light fitting below.
	E	Depicts an emergency light when used with a fitting below.
	Ex	Depicts an External light when used with a fitting below.
LIGHTING CONTROL	CX	Circuit Reference.
	LKP	Lighting Control Keypad.
	CX-XX	Standard Lighting Switch.
	PIR	PIR Motion Sensor for light fitting.
	D	Depicts a dimmer switch when used with a standard switch above.
POWER FITTINGS	T	Depicts a timer switch when used with a standard switch above.
	2 3	Depicts either a two way or three way light switch.
	∞	Door/Movement Operated Switch
	TV	TV Outlet.
	WAP	Wireless Access Point.
	D	Data Point.
	B	Telephone Outlet.
		Single 13amp Power Socket.
		Double 13amp Power Socket.
		Double 13amp Power Socket above counter level.
	USB	USB Point when used with a power socket above.
	EX	External Power Point when used with a power socket above.
	5	5amp Power Socket (used with circuit reference)
		Un-switched Fused Spurs.
		Switched Fused Spurs.
		Floor box (used with symbols above).
		Shaver Socket.
		Extract fan.
		Demister Heat Pad Fitted Behind Mirror.
		Motorised Window Treatment.
		Isolator Switch.
		Lift Control Standing Operating Panel.
		Mobile Signal Booster Antenna.
		Clock point

A1 Sheet Size

NOTES		
1.	All dimensions and levels are to be checked on site by the Main Contractor before work commences. The Architect is to be informed immediately of any discrepancies.	
2.	Do not scale this drawing, use written dimensions only.	
3.	Larger scale drawings are to be used over smaller scale drawings.	
4.	All dimensions are in millimetres unless otherwise stated.	
5.	If in doubt ask.	
©	Copyright of Mitchell Berry Architects.	

Rev	Date	Notes
a	19.05.26	Added WC R.1.18

Status	PLANNING
--------	----------

Project	New Wardour Castle, Tisbury, Salisbury SP3 6RP
Client	Private Client

Title	Proposed First Floor Central Block Reflected Ceiling Plan		
Scale	1:100@A1	Drawn by	VR
Date	October 25	Checked by	JB

Drawing Number	2517 - P71	Revision	a
----------------	------------	----------	---

MITCHELL BERRY ARCHITECTS			
THE STUDIO · 9 STRATFORD ROAD · LONDON · W8 6RF TEL 020 7938 4358 EMAIL studio@mitchellberryarchitects.co.uk			