


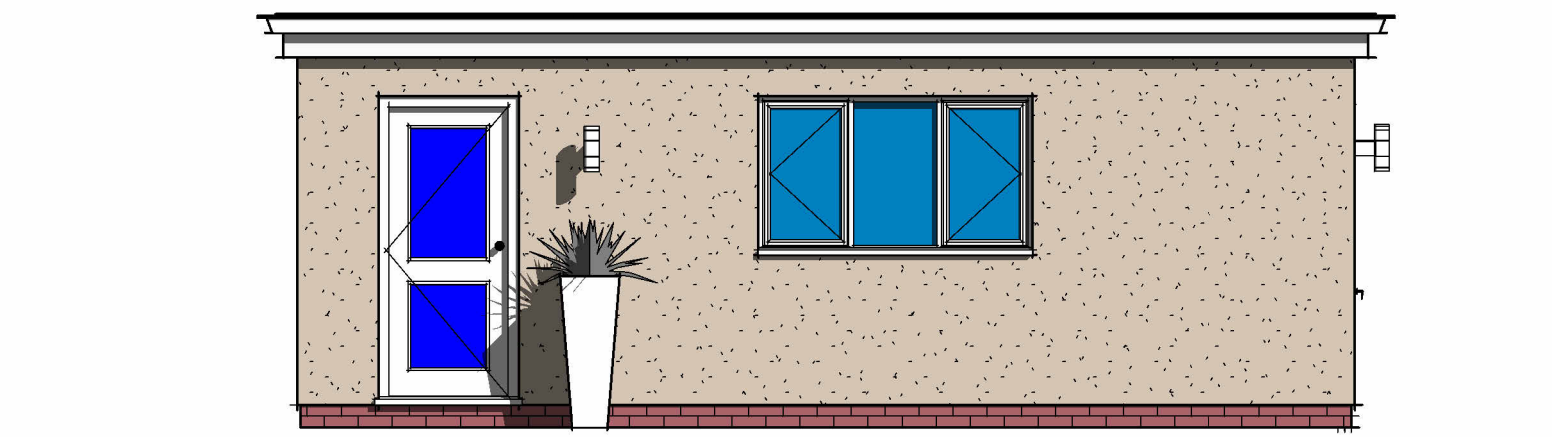


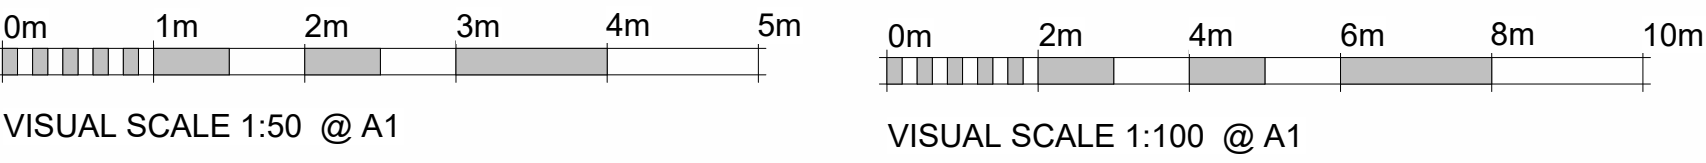


7 Left Side Elevation
1 : 50

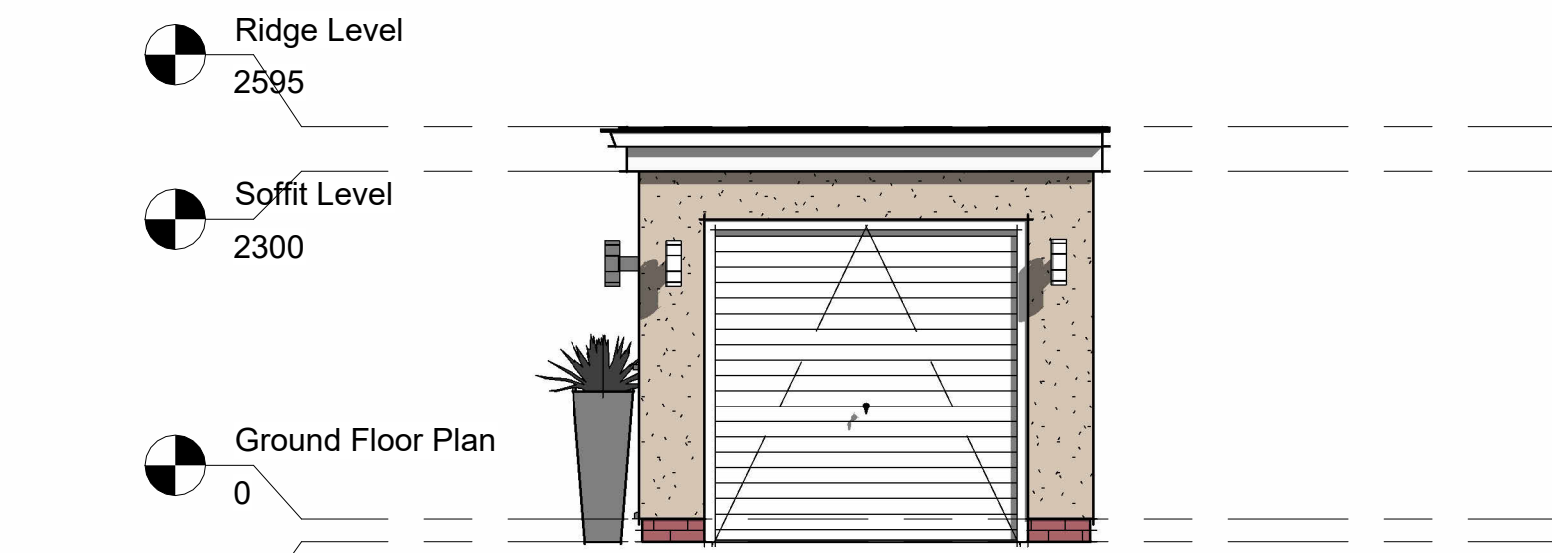


6 Front Elevation
1 : 50

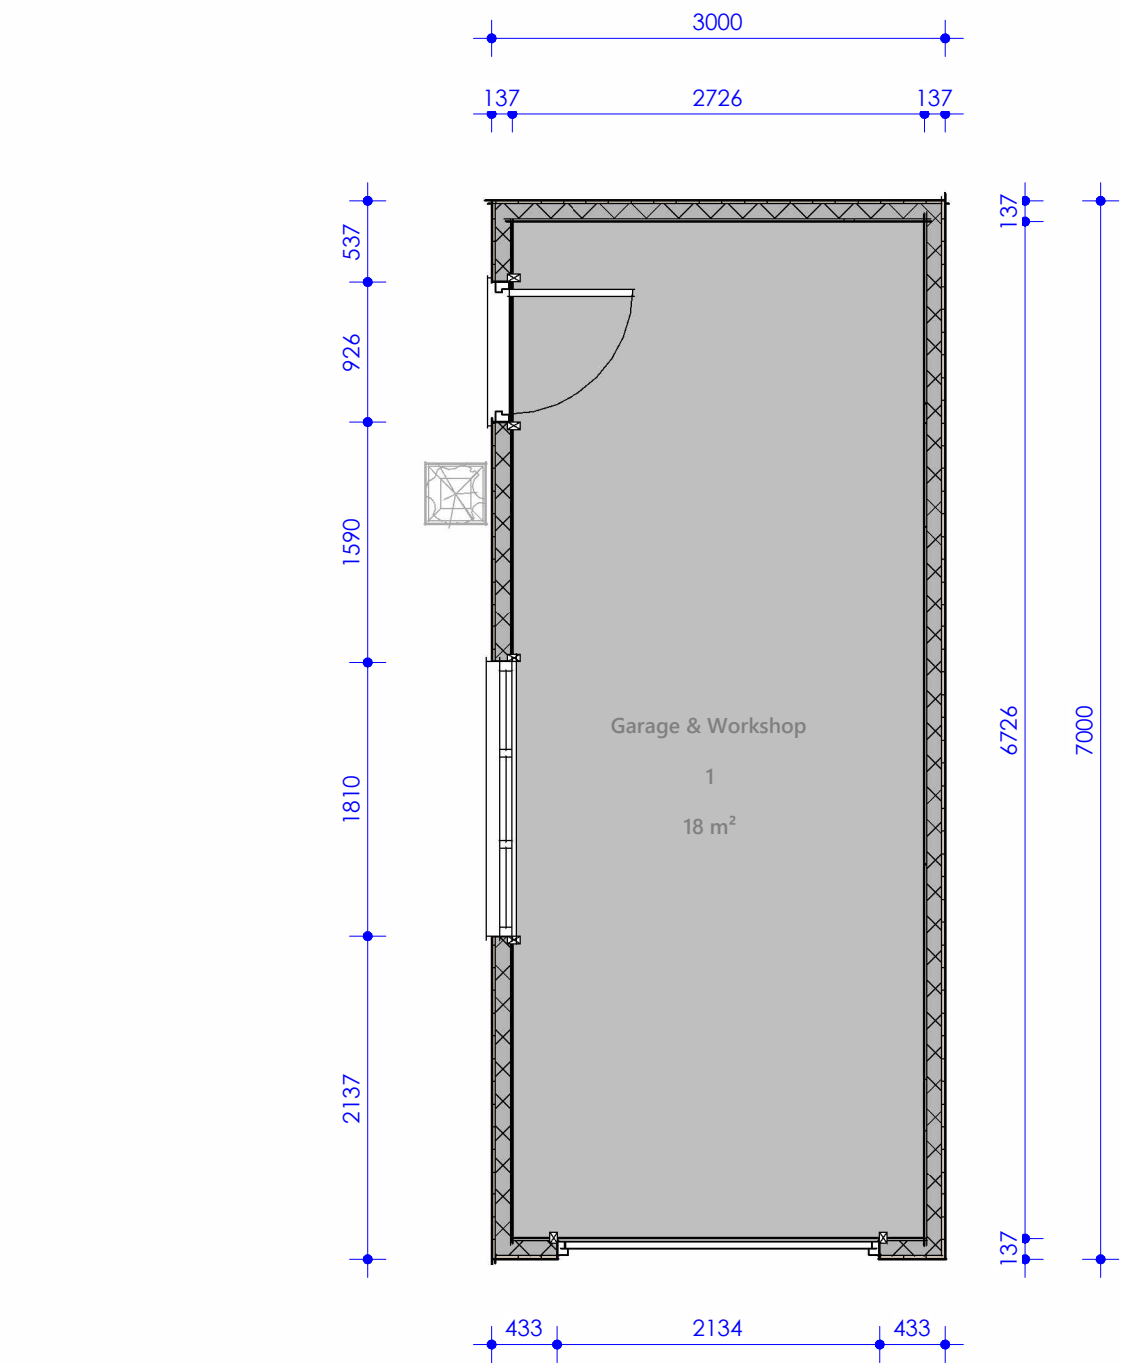





2 Ground Floor Plan
1 : 50

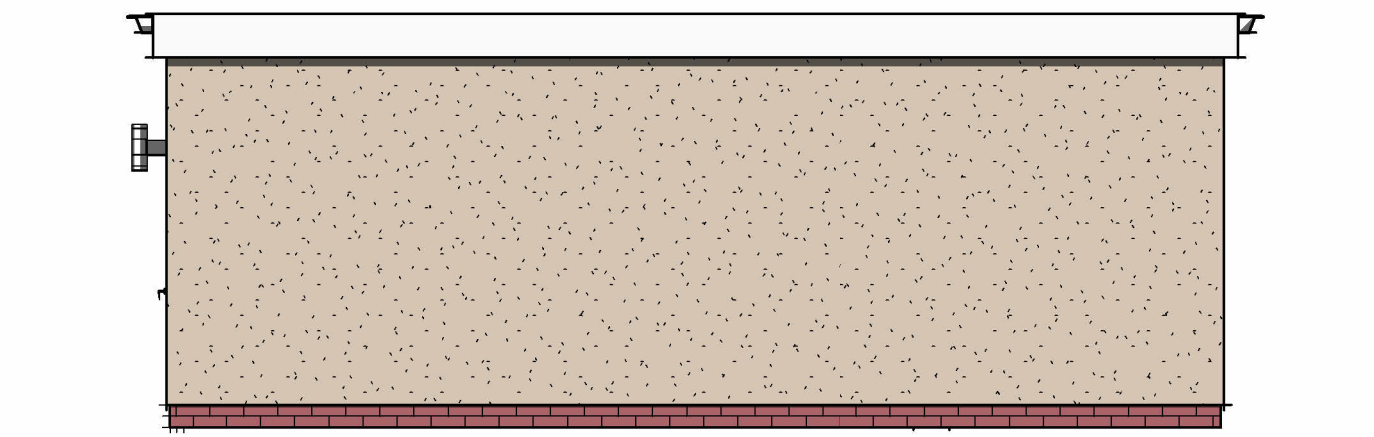

9 Right Side Elevation
1 : 50

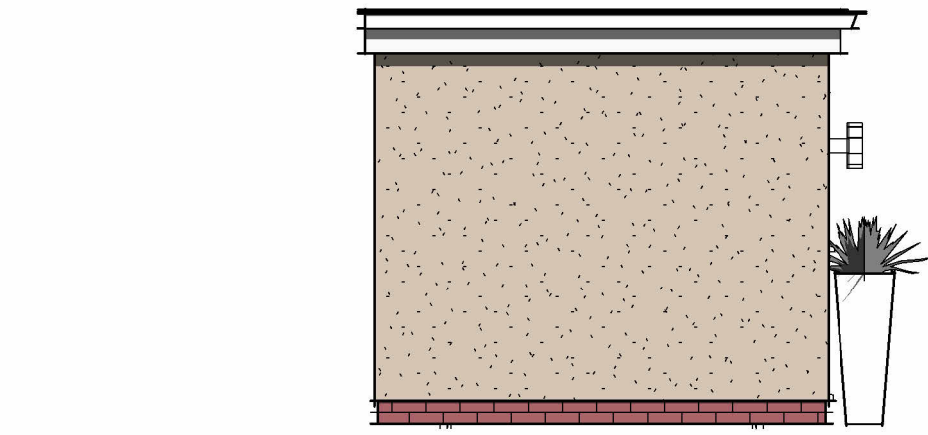

8 Rear Elevation
1 : 50

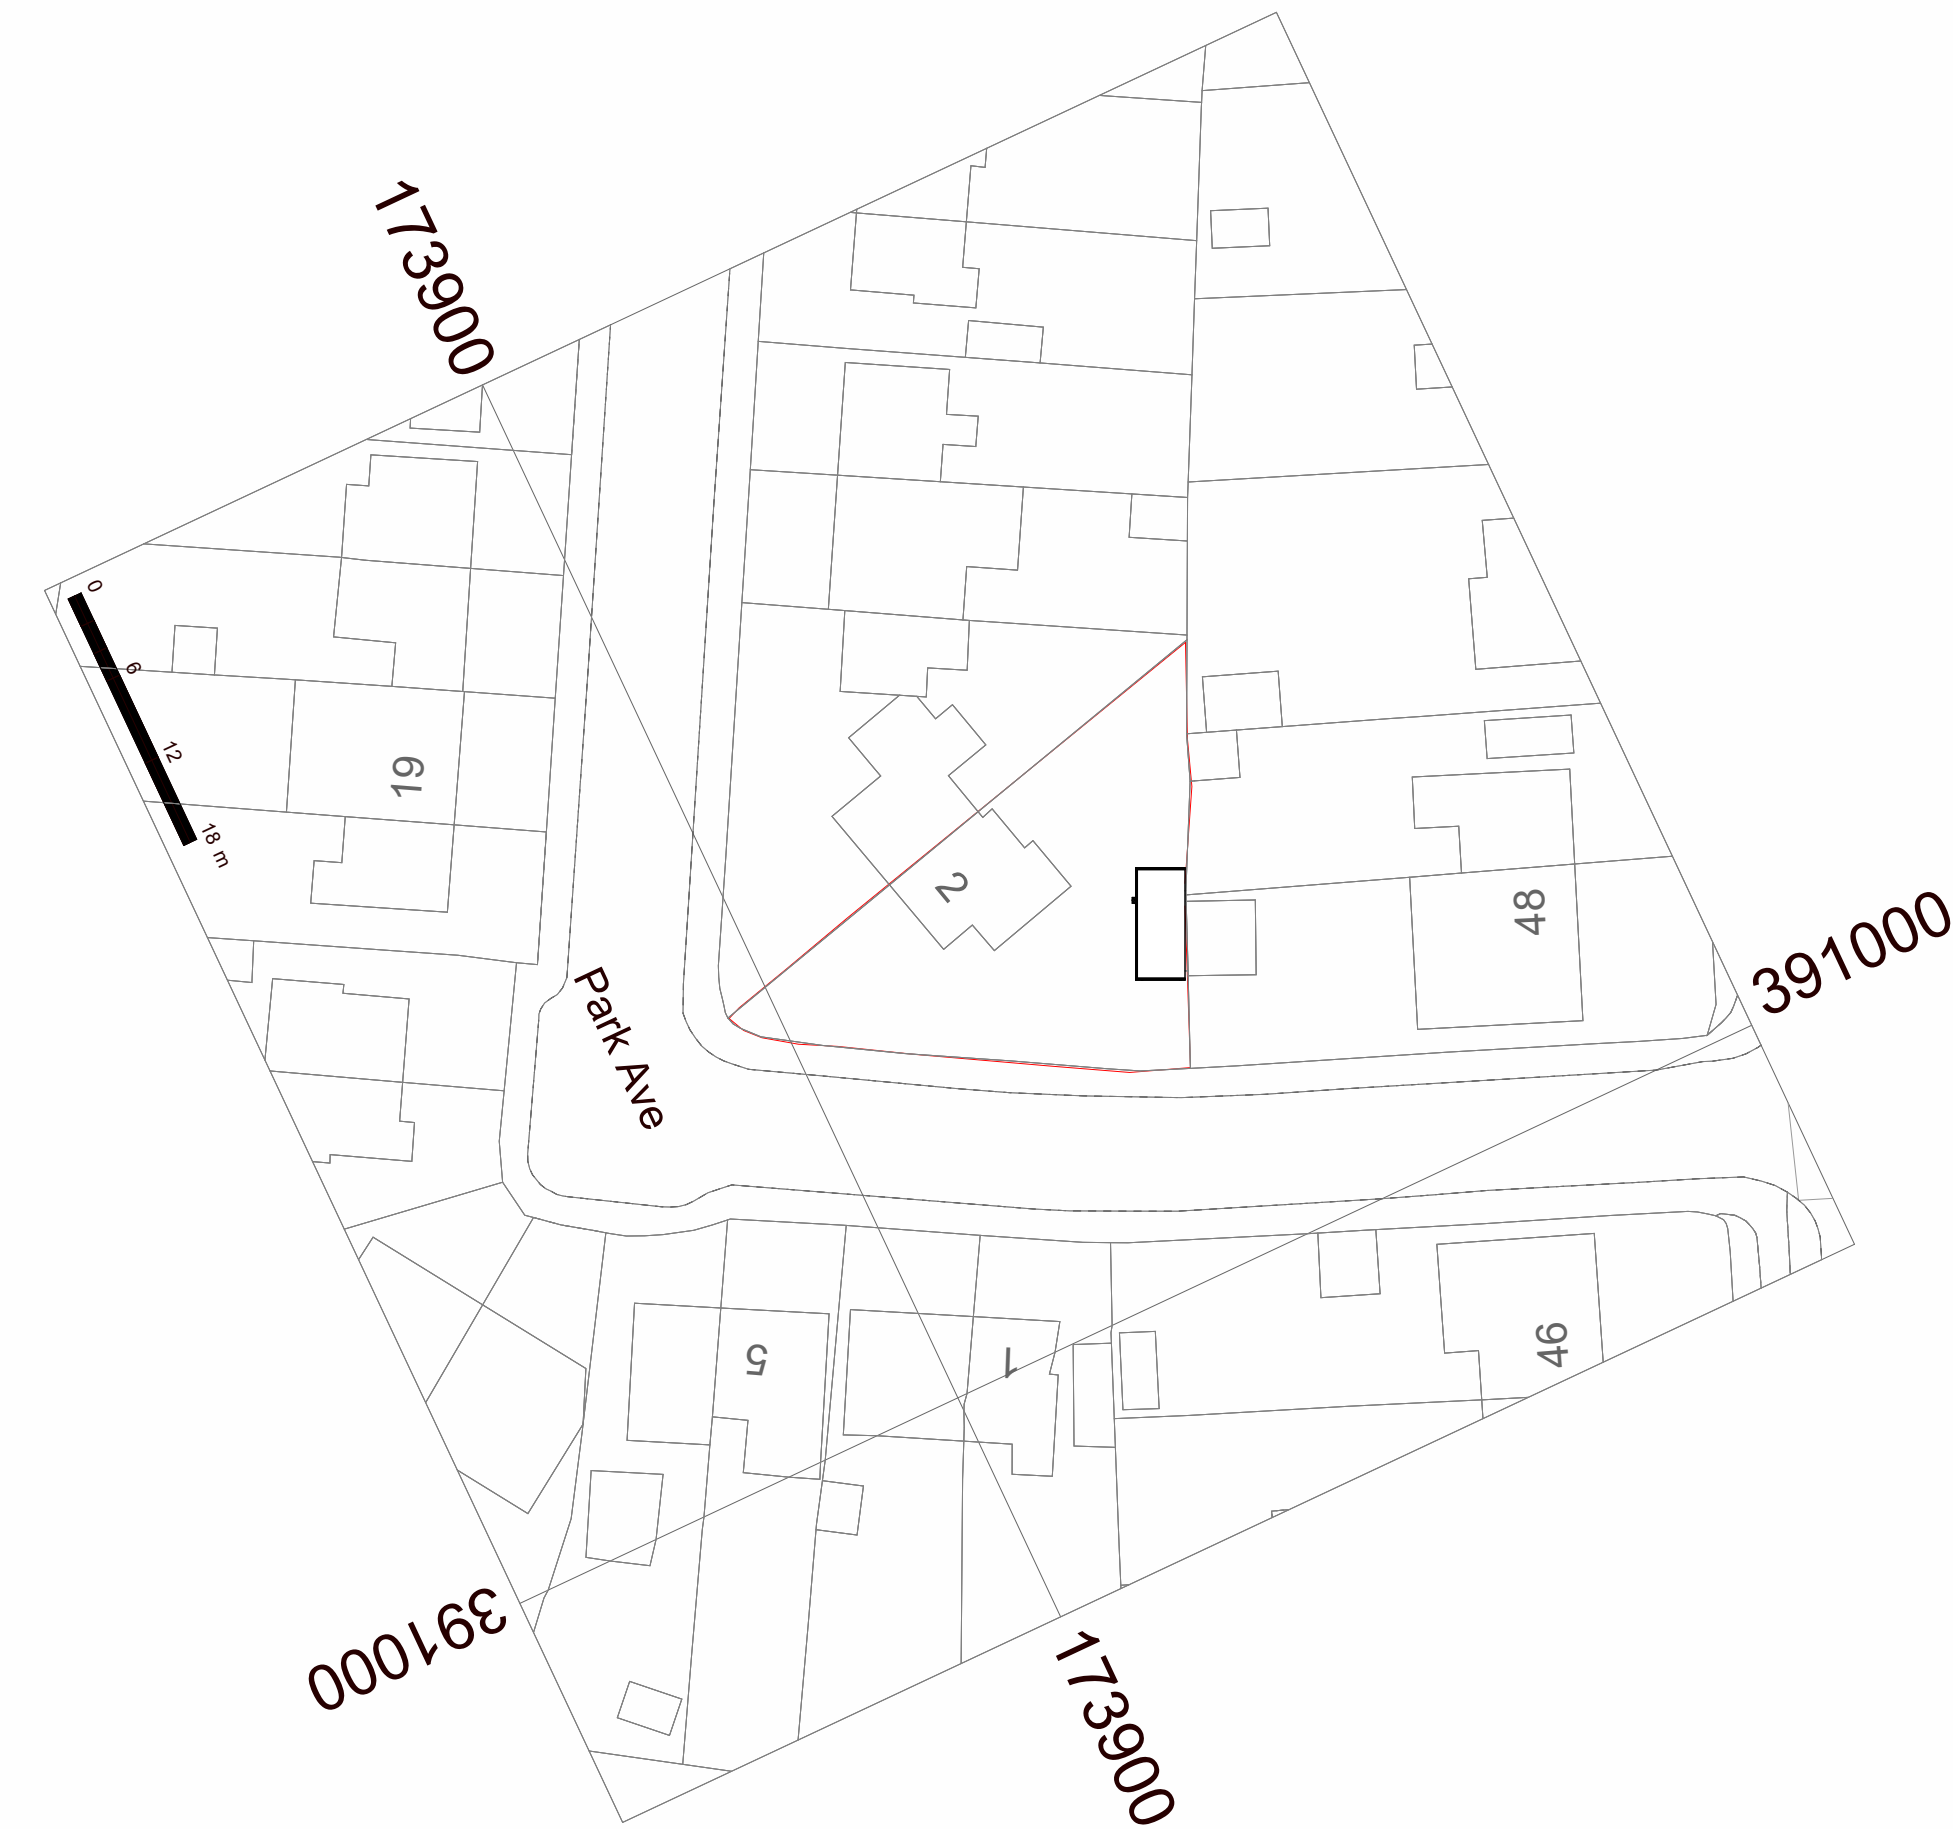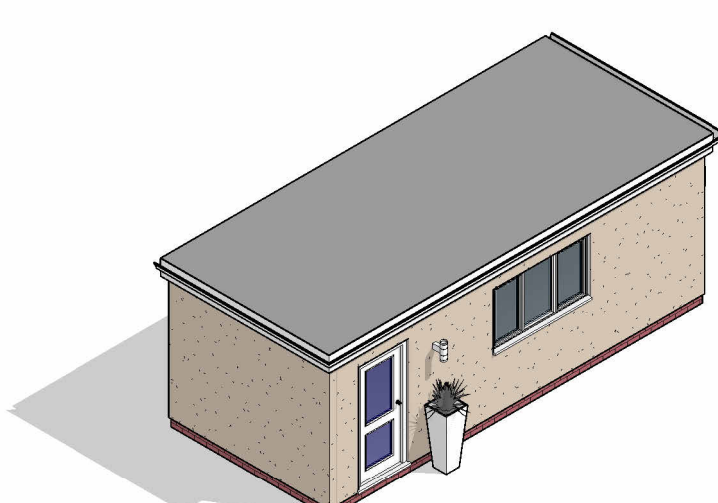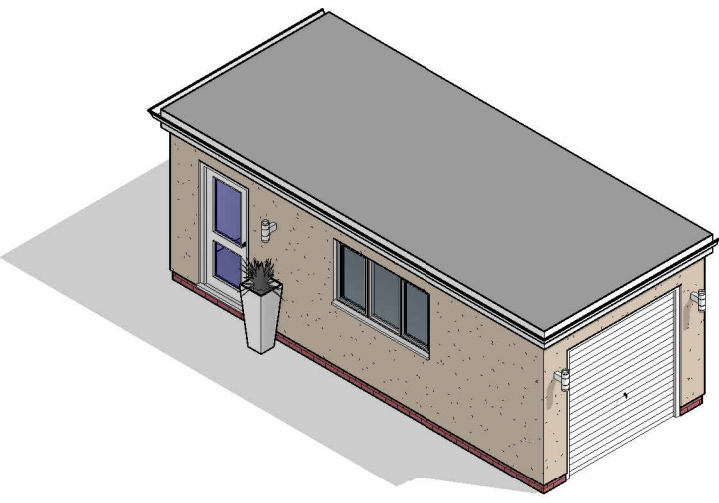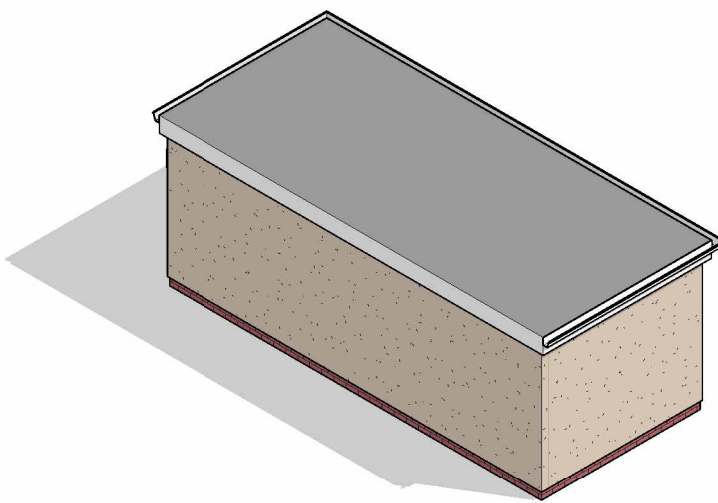

1 Block Plan
1 : 500



Health and Safety Notice

Client and contractor to be aware:

1. The design has elements of working at height
2. The design has drainage elements
3. The design includes demolition tasks
4. The design has trenching works at various depths
5. The design has manual handling tasks
6. The design requires vehicle movements and crane lifts

A1

PLEASE NOTE:

All drawings are for the purposes of planning only unless marked for construction.

All builders to site measure to confirm measurements and layout for setting out, especially door and window positions.

Report all discrepancies to the person named below, do not proceed without instruction.

BRO take no responsibility should any drawing/s unless specified are used for building purposes and measurements should be checked on site.

All drawings remain the property of BRO Architecture Ltd



Wall Structure Key:

- Cavity Wall: Render
- Cavity Wall: Face Brick
- Block Work: 100mm
- Studwork Wall: 75mm
- Metal Frame: 70mm
- Solid Brick Wall: 215mm
- Solid Block Wall: 215mm
- Structural Opening
- Walls Removed

Drainage Key

- S Storm Drainage
- MH Manhole
- FD Foul Drainage
- SVP Soil Vent Pipe
- GP Gulley Pot
- RWP Rainwater Pipe
- AD ACO Drain


Ducting Colour & Use

- Red Electric cable
- Yellow Gas Pipe
- Blue Water pipes
- Green Data/Comms
- Grey BT
- Purple Security Cameras
- Orange Garden Lighting

- 1 Single Power Socket
- 2 Double Power Socket
- C Cooker Point
- Unswitched Fused Spur
- External Power Socket
- Telephone Point
- Cat 6 Data Point
- Extract Vent
- FIRE Fire Alarm Panel
- SS Shaver Socket
- GP Speaker Point
- TV TV Aerial Point
- FB Floor Box
- FS-2 Floor Socket
- PE Passive Extract
- ME Mechanical Extract
- Distribution Board
- SD Smoke Detector
- H Heat Detector
- C Carbon Monoxide Detector
- Extract fan
- Underfloor heating control

DRAWING NUMBER

P1-1

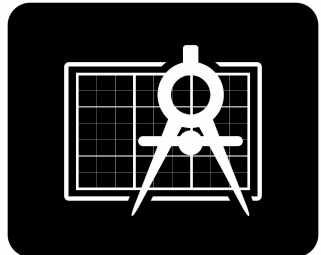

BRO ARCHITECTURE
DESIGNING YOUR DREAMS

Mobile: 07508 856621
Website: www.broarchitecture.co.uk
E-mail: info@broarchitecture.co.uk

CLIENT

Lee Owens

SITE ADDRESS

2 Park Ave Chippenham
SN14 0HA

PROJECT NAME

Proposed Detached Garage

DRAWING NAME

Proposed Garage Plans

DATE
23rd May 26

DRAWN BY
SH

CHECKED BY
Client

REV

SCALE (@ A1)
As indicated

PROJECT NUMBER
SH/BRO/230526-LO