


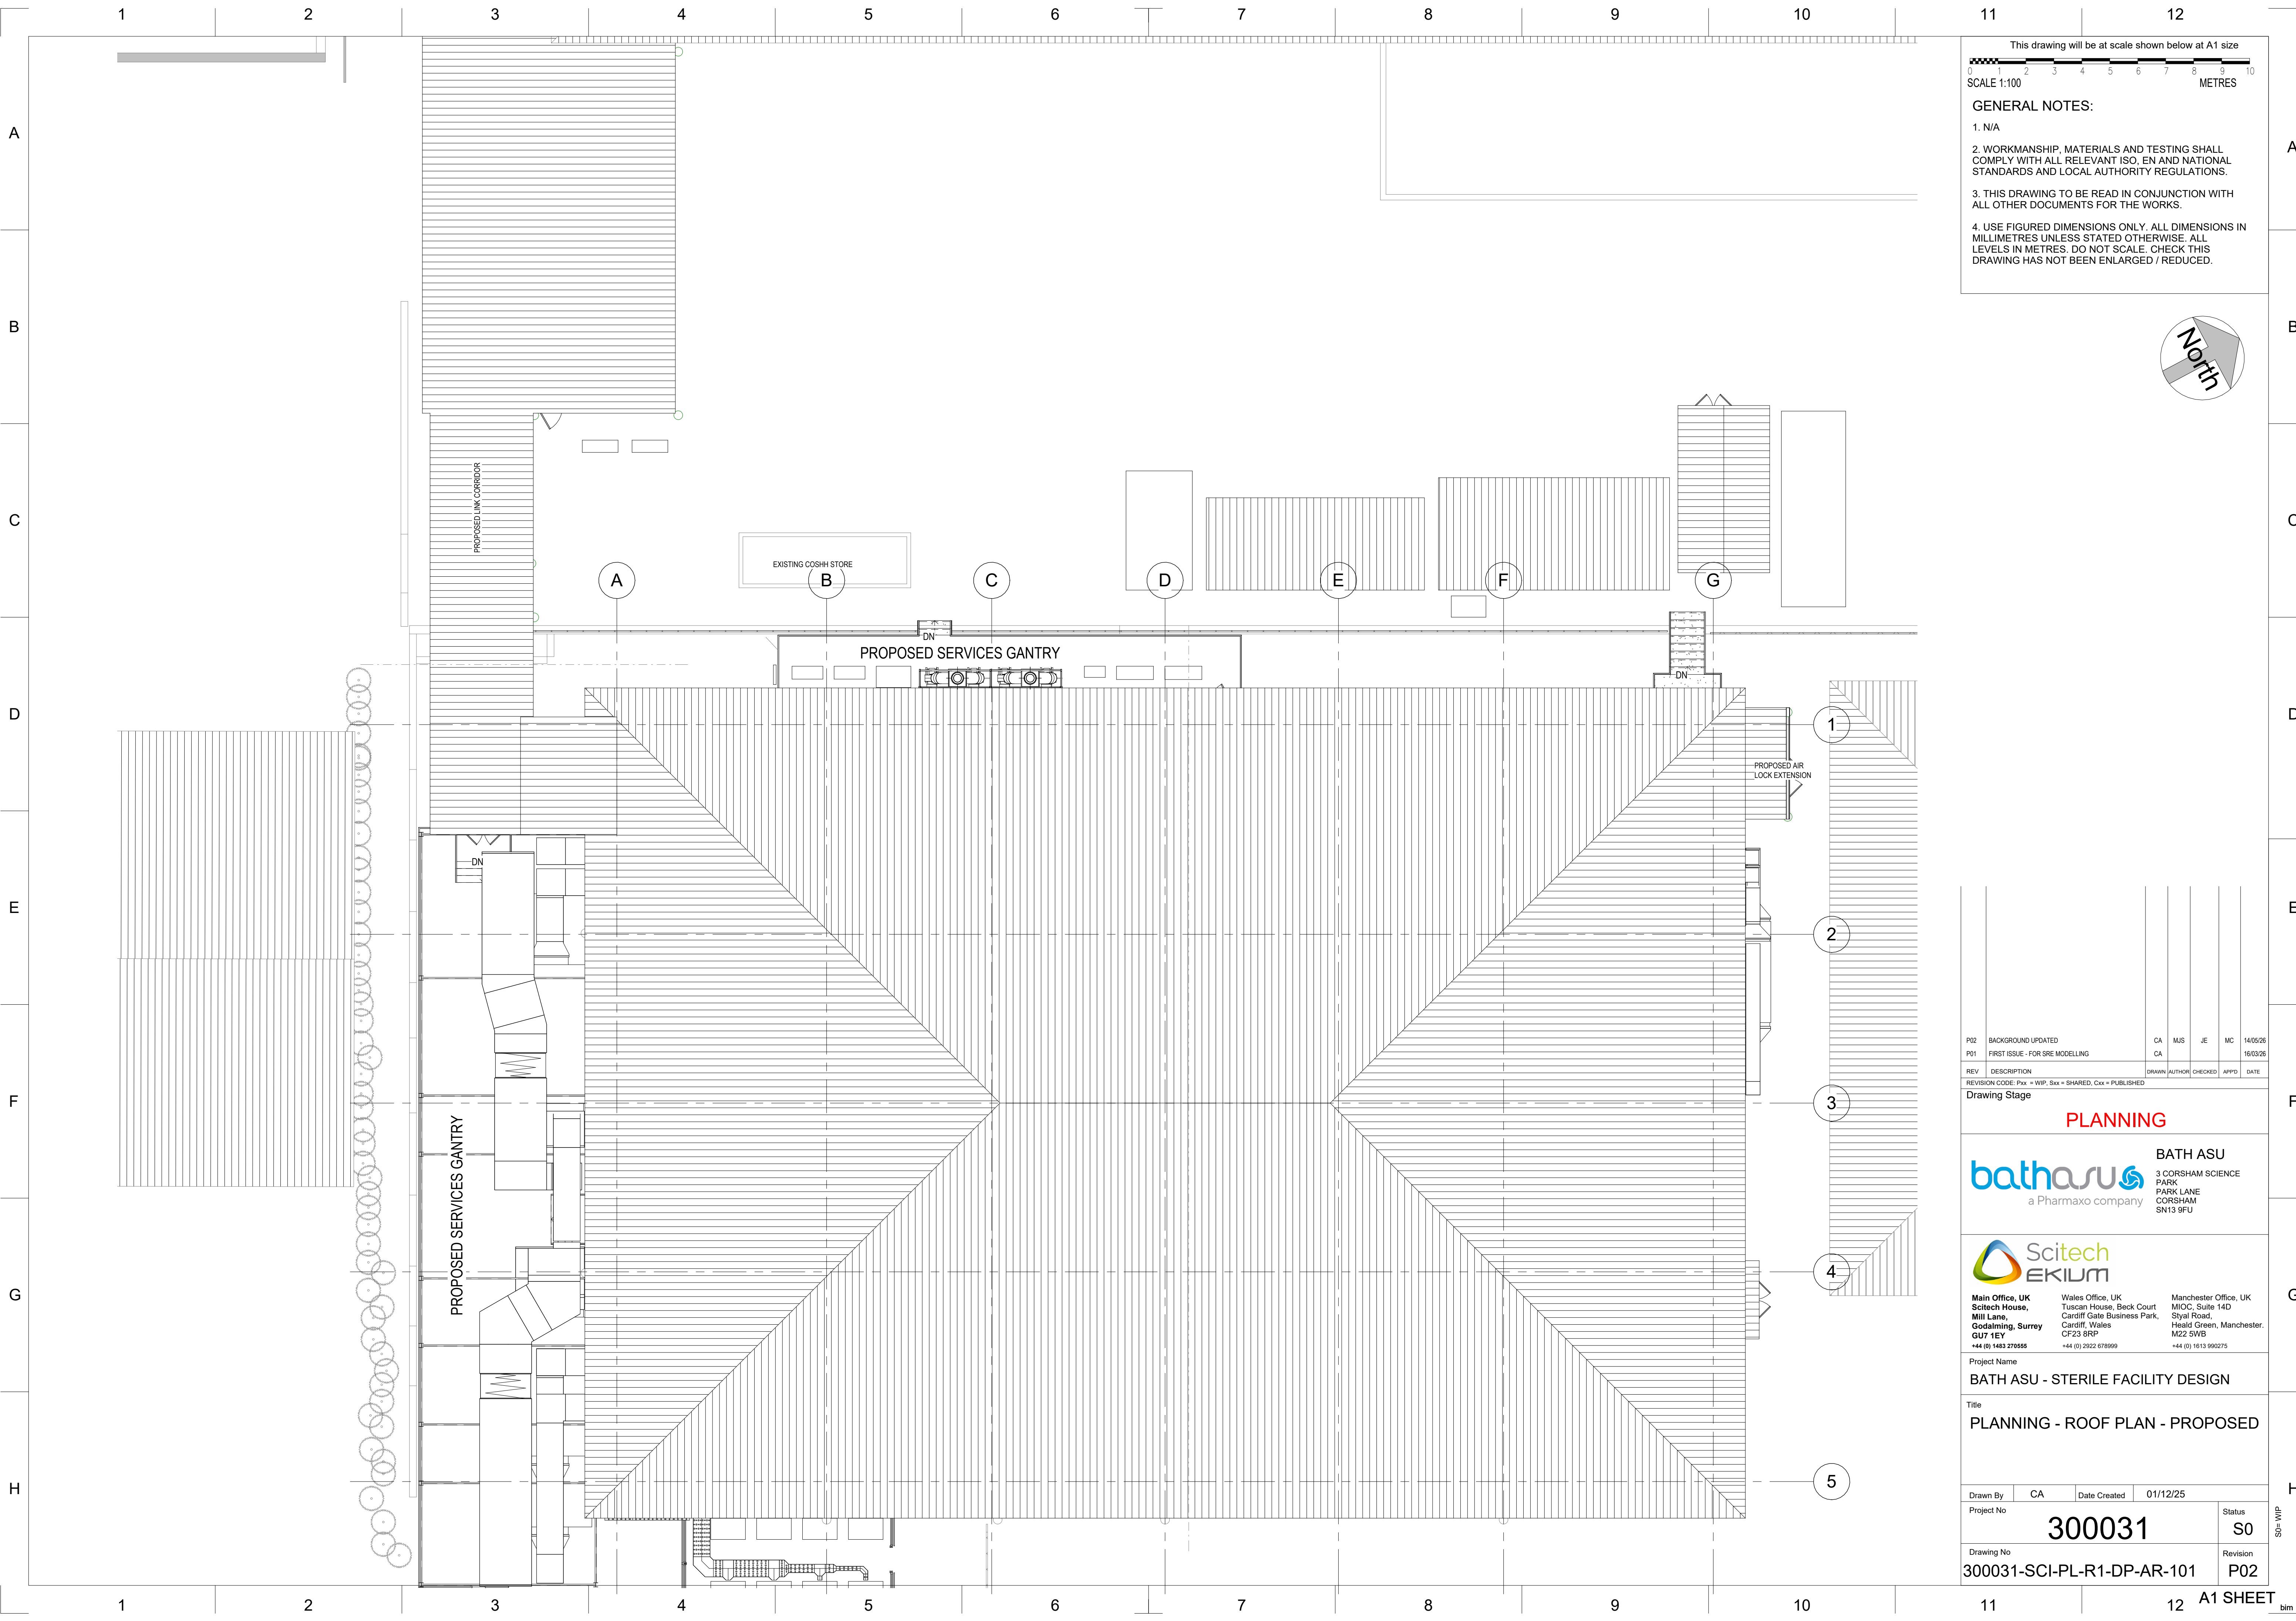

This drawing will be at scale shown below at A1 size

SCALE 1:100


GENERAL NOTES:

1. N/A

2. WORKMANSHIP, MATERIALS AND TESTING SHALL COMPLY WITH ALL RELEVANT ISO, EN AND NATIONAL STANDARDS AND LOCAL AUTHORITY REGULATIONS.

3. THIS DRAWING TO BE READ IN CONJUNCTION WITH ALL OTHER DOCUMENTS FOR THE WORKS.

4. USE FIGURED DIMENSIONS ONLY. ALL DIMENSIONS IN MILLIMETRES UNLESS STATED OTHERWISE. ALL LEVELS IN METRES. DO NOT SCALE. CHECK THIS DRAWING HAS NOT BEEN ENLARGED / REDUCED.

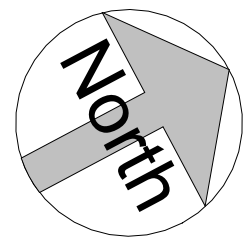

P02	BACKGROUND UPDATED	CA	MJS	JE	MC	14/05/26
P01	FIRST ISSUE - FOR SRE MODELLING	CA				16/03/26

REVISION CODE: Pxx = WIP, Sxx = SHARED, Cxx = PUBLISHED

Drawing Stage

PLANNING

bathasru BATH ASU
a Pharmaxo company
3 CORSHAM SCIENCE PARK
PARK LANE
CORSHAM
SN13 9FU

Scitech
EKUM
Main Office, UK
Scitech House,
Mill Lane,
Godalming, Surrey
GU7 1EY
+44 (0) 1483 276555
Wales Office, UK
Tuscan House, Beck Court
Cardiff Gate Business Park,
Cardiff, Wales
CF23 8RP
+44 (0) 2922 678999
Manchester Office, UK
MIOC, Suite 14D
Styal Road,
Heald Green, Manchester,
M22 5WB
+44 (0) 1613 990275

Project Name
BATH ASU - STERILE FACILITY DESIGN

Title
PLANNING - ROOF PLAN - PROPOSED

Drawn By	CA	Date Created	01/12/25
Project No	300031		Status S0
Drawing No	300031-SCI-PL-R1-DP-AR-101		Revision P02