
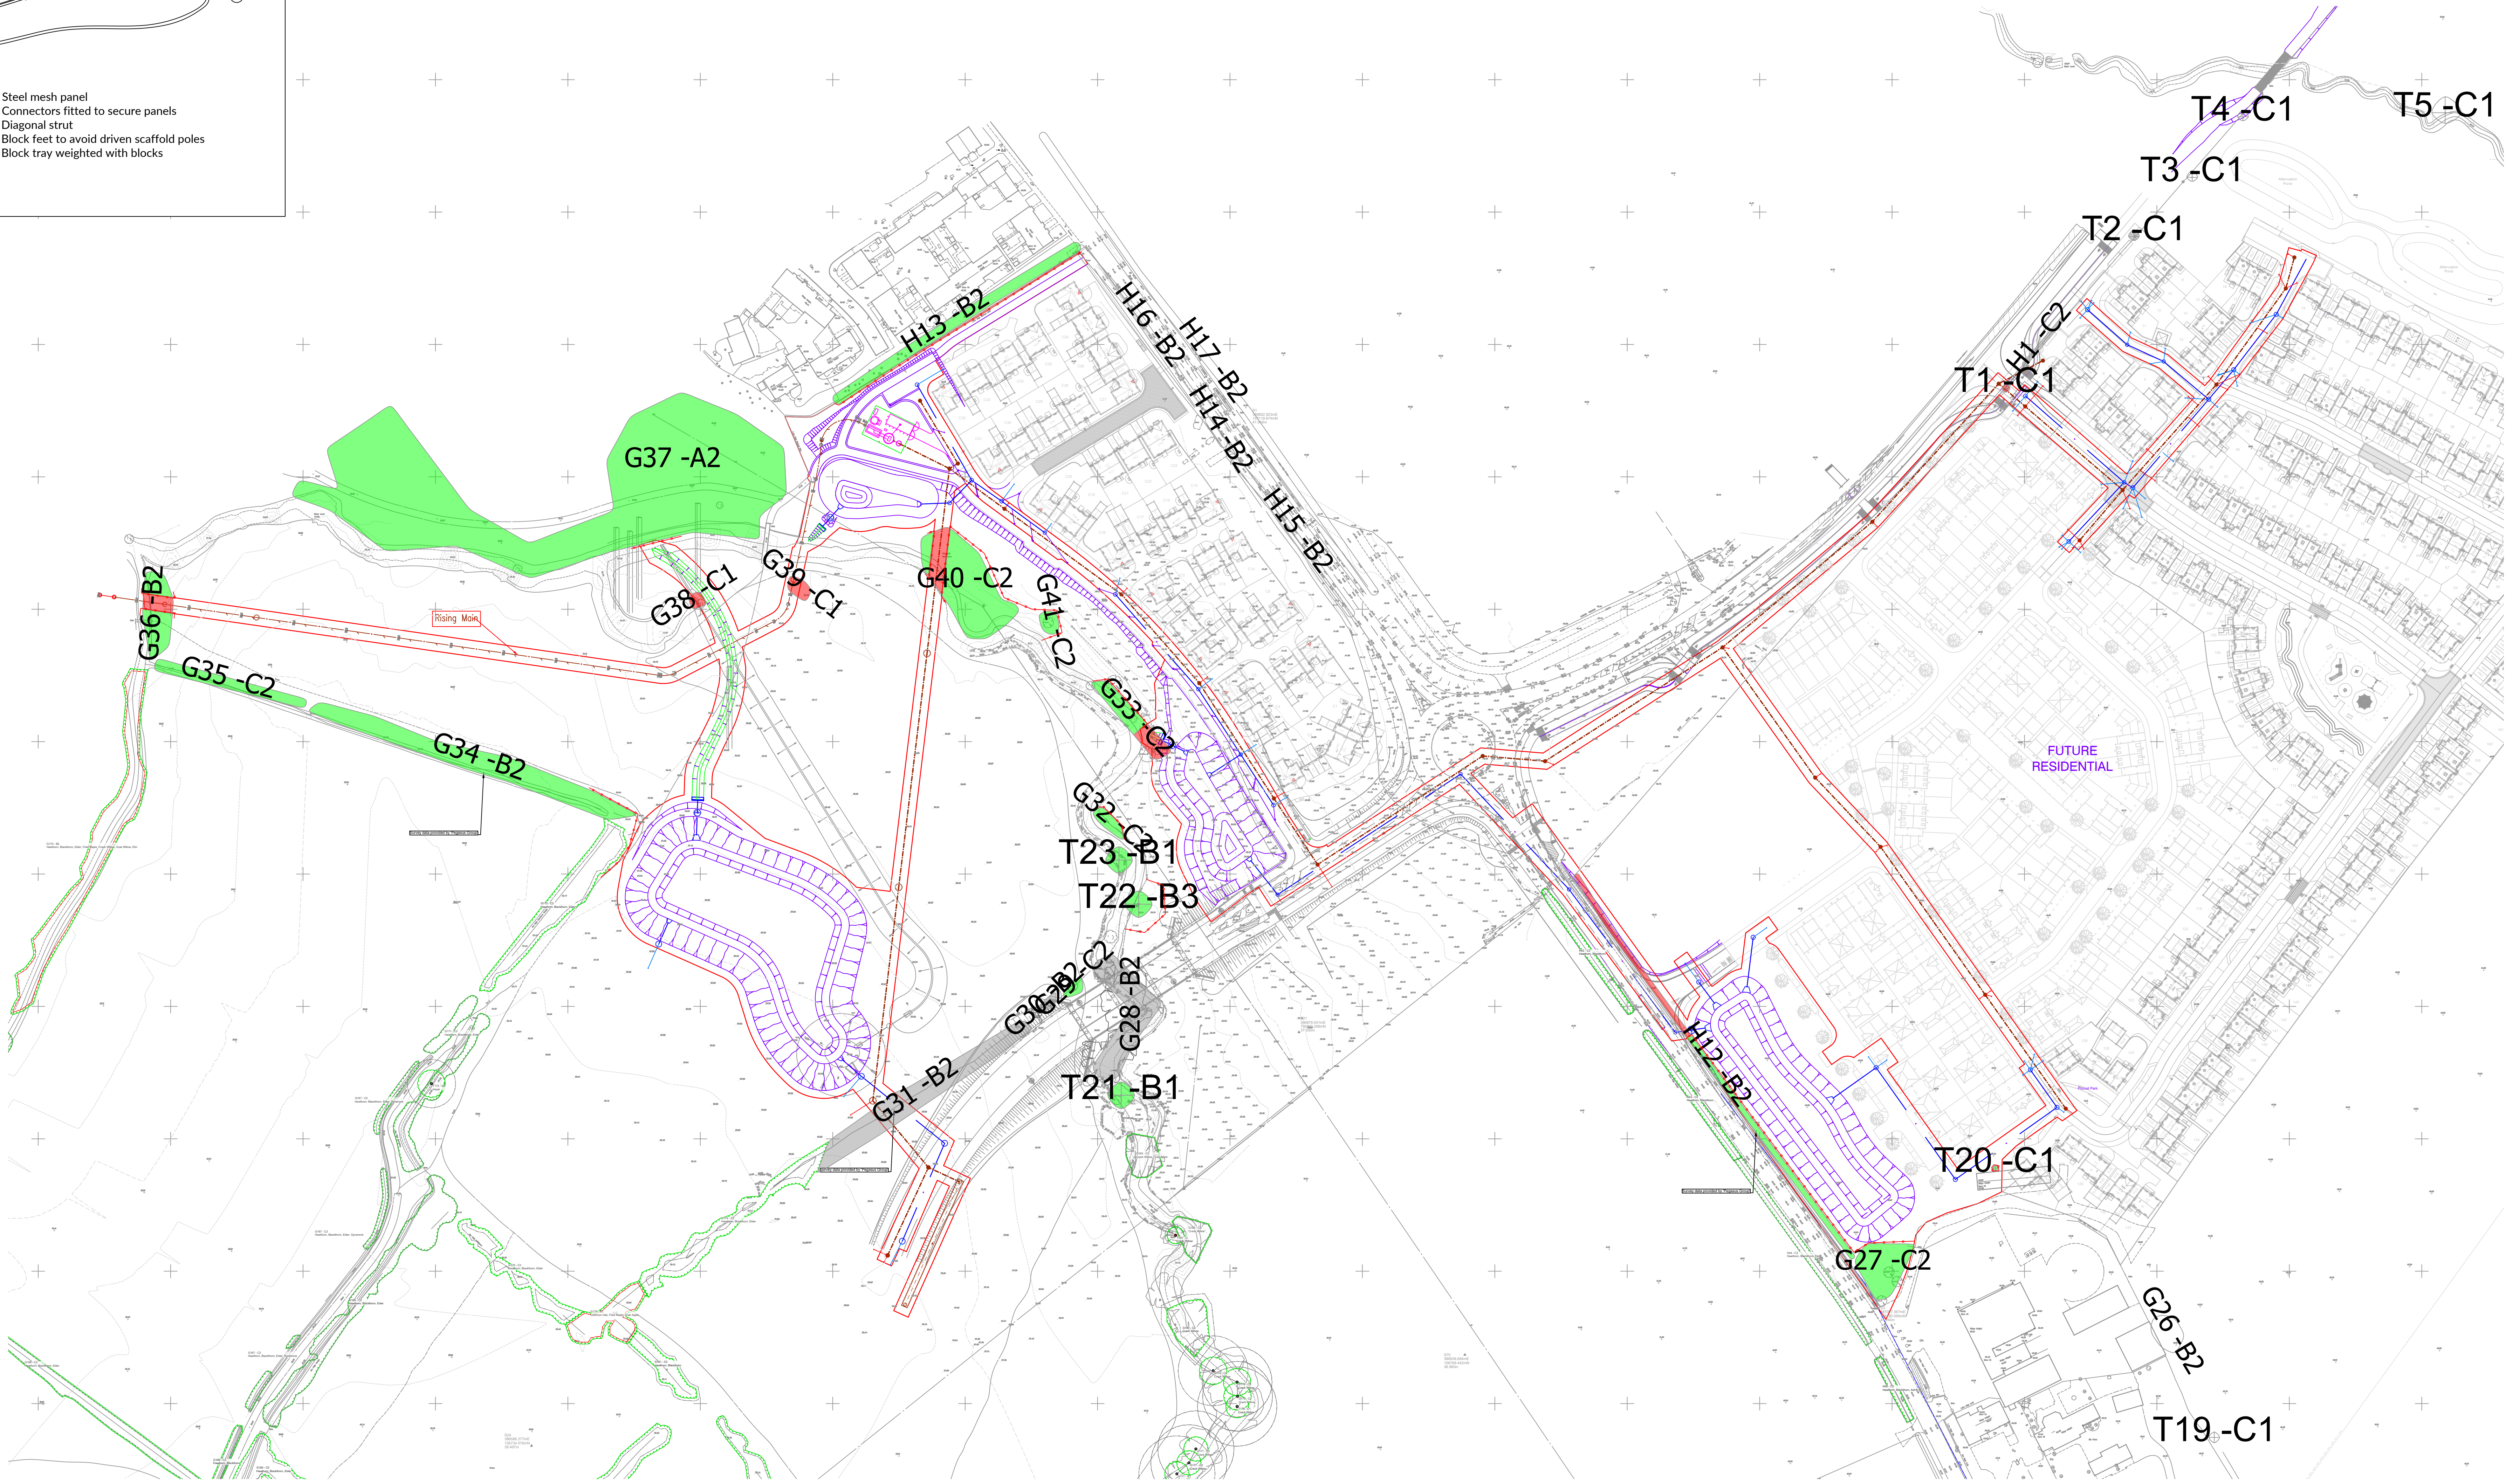


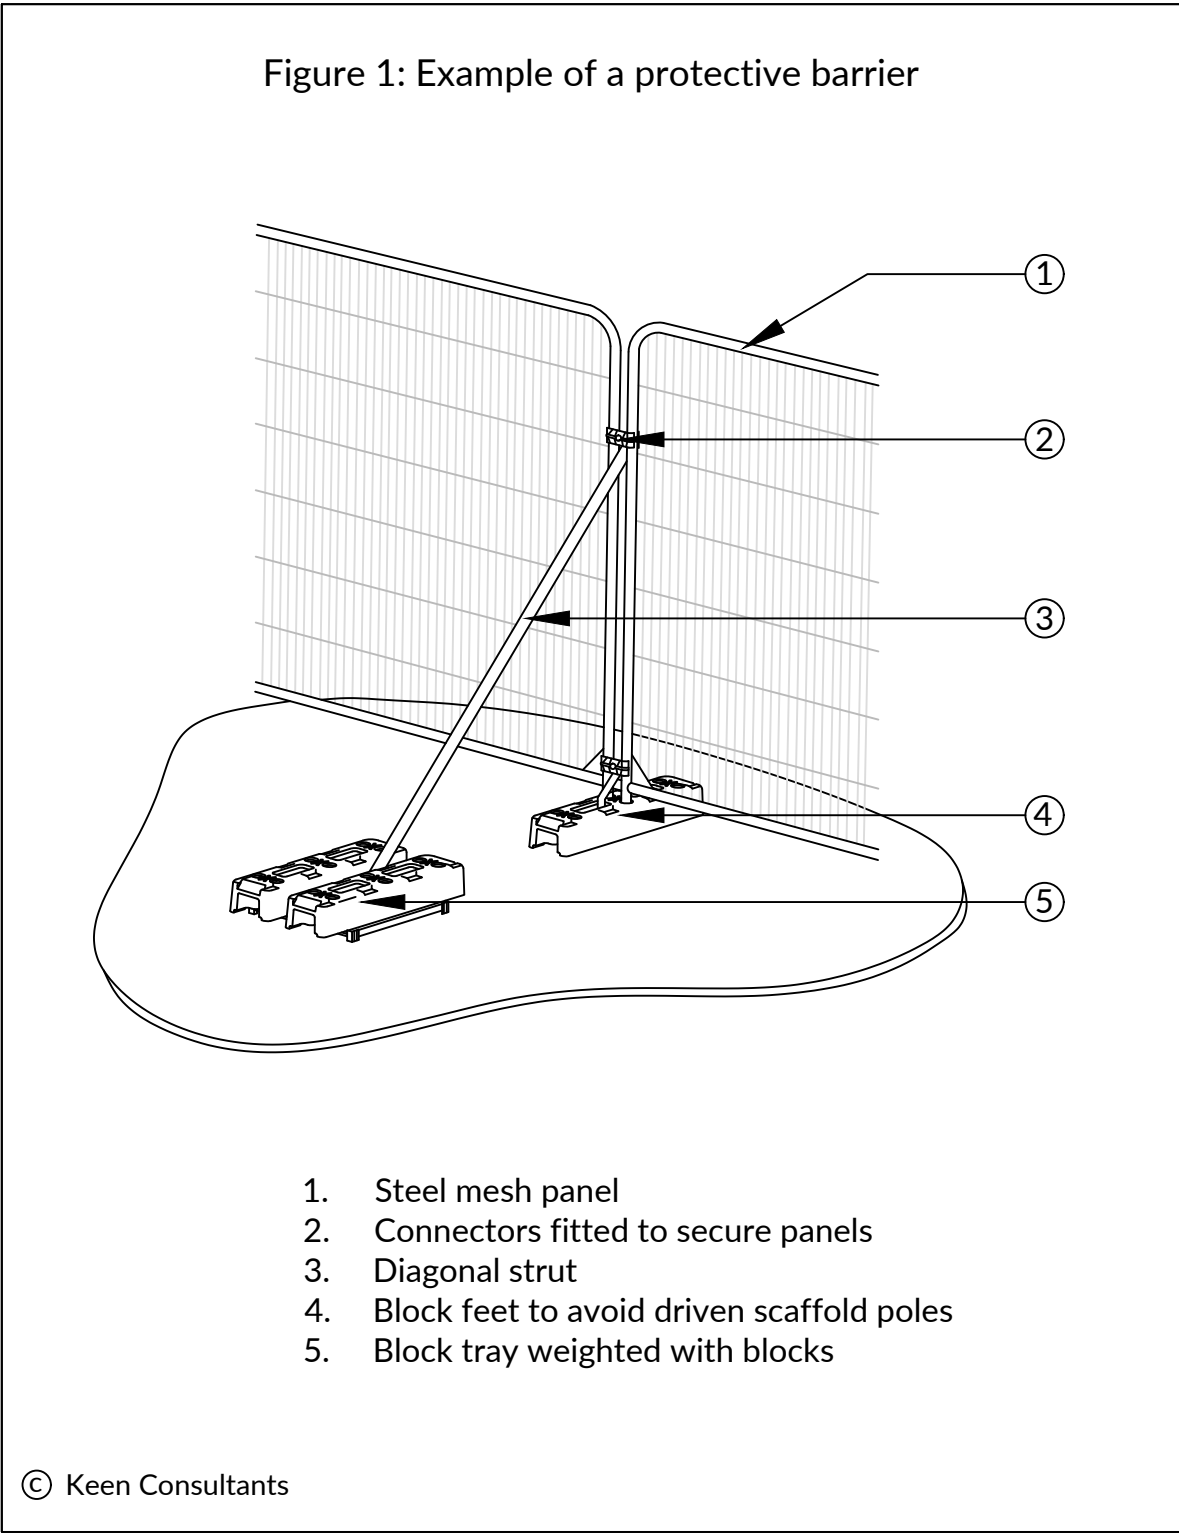

NORTH

0 10m 20m 50m 100m

NOTES

1. This tree survey information has been prepared for planning purposes only. Additional detail will be needed for foundation design.
2. The original of this drawing was produced in colour - a monochrome copy should not be relied upon.
3. Scale for planning purposes only.
4. All dimensions to be checked on site.
5. The copyright of this document resides with Keen Consultants unless assigned in writing by the company.
6. Details shown on this drawing are devised with reference to BS5837:2012 Trees in relation to design, demolition and construction - Recommendations.
7. Check if Tree Preservation Order or Conservation Area protection applies to trees before undertaking tree works.
8. Tree Survey Plan based on ACD Environmental drawing number PERW24302-01A.
9. Where trees were not identified on the topographical survey they have been plotted by eye.
10. Proposed drainage layout based on Phoenix Design Infrastructure Drainage General Arrangement drawing number 566-ID-P-100 RevF.

KEY

- Existing site features
- Proposed drainage
- Existing trees/hedge retained
- Existing trees/hedge for removal
- Existing trees removed for separate RM application
- 2.0m high barrier as detail in Figure 1 (Temporary, for the duration of works)
- T1 Tree number
- C1 BS5837 category

B	Hedgerow removal updated	26.08.25
A	Latest layout overlay	08.08.25
0	Preliminary issue	17.07.25

Rev	Description	Date
B	Hedgerow removal updated	26.08.25
A	Latest layout overlay	08.08.25
0	Preliminary issue	17.07.25

KEEN CONSULTANTS

Keen Consultants is a trading name of Keen Design Limited. Registered No. 12041084
Registered office: The Studio, Timbers, Gables Road, Church Crookham, Fleet, Hampshire GU52 6QY
T 01252 855094
mail@keenconsultants.co.uk
keenconsultants.co.uk

Client
PERSIMMON HOMES

Project
INFRASTRUCTURE DRAINAGE, ASHTON PARK, TROWBRIDGE

Title
TREE PROTECTION PLAN

Date JULY 2025	Scale 1:1000@A0
Drawn by ML	Checked by JTK
Drawing Number 2484-KC-Infra-YTREE-TPP01REV B	