



Wall mounted downward task light on dual PIR & Switch circuit, to hold Envirolight 5w Warm White LED Flood Beam GU10 Bulb

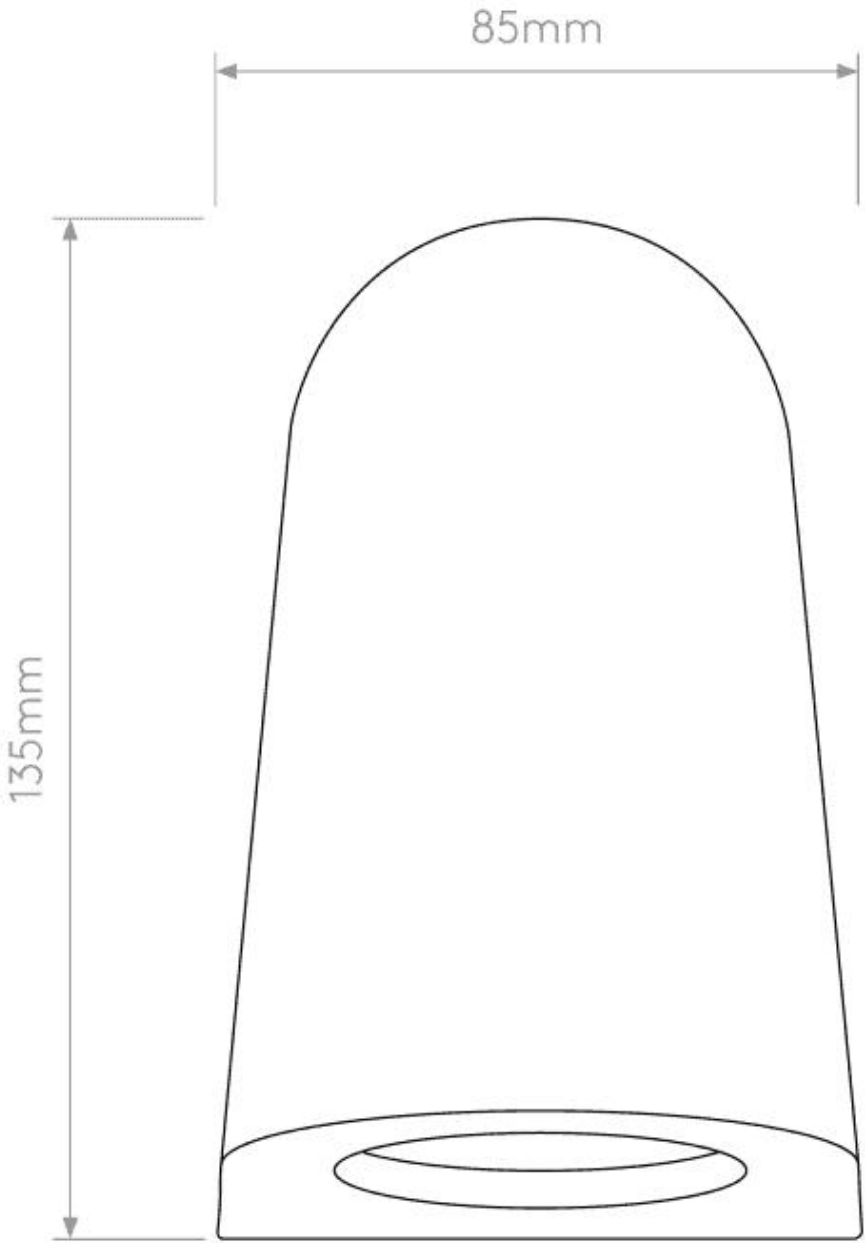

 
01 Front Elevation

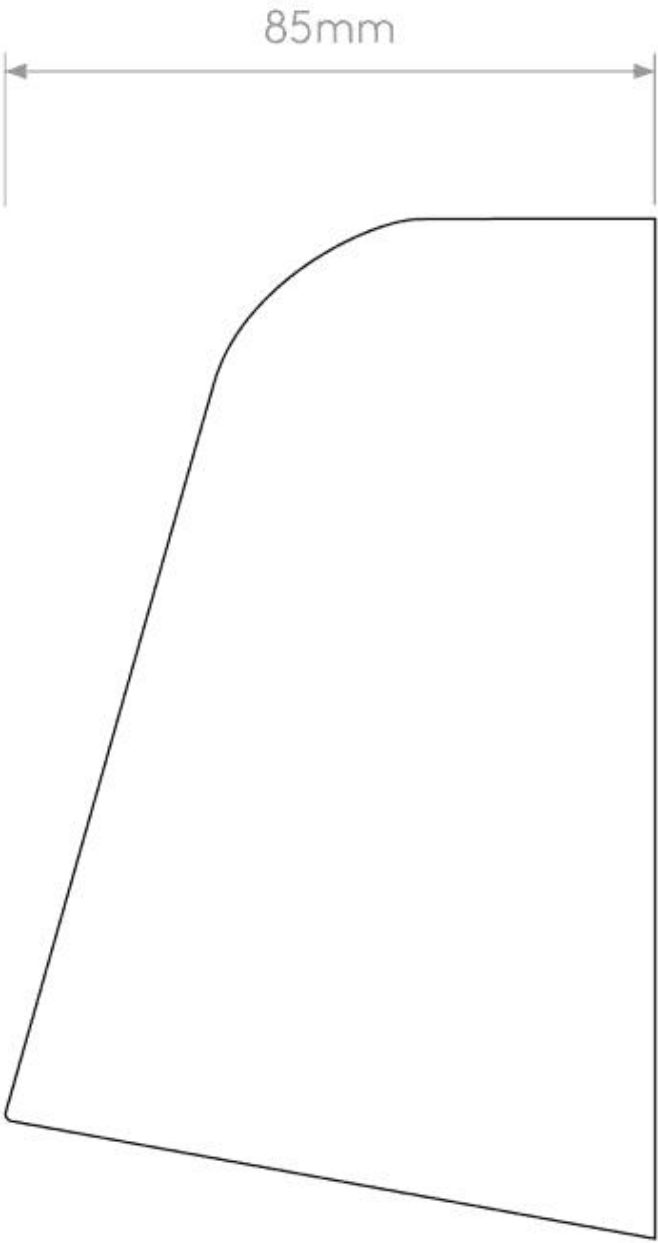

02 Side Elevation



03 Image



PLANNING

No.	Date	Dr/Ch	Revision Notes	Project Title Reybridge Farm Stables Project Client Mr & Mrs Doel Suitability Code - Description .	Sheet Scale: 1:20 @ A3 Date: 27/06/2024 Drawn By: LW Reviewed By: PR Copyright. Check all dimensions on site. . This drawing is only to be used on the site for which designed.	Sheet No. Project ID - Originator - Volume - Level - Type - Role - Number 2047-CMS-XX-00-DR-A-PL24 Sheet Title Proposed Wall Mounted Task Lighting 26 Martingate, Corsham, Wiltshire, SN13 0HL, Web: www.cms-group.co, Tel: 01249 701333	Rev CMS Architects
-----	------	-------	----------------	--	---	--	---