


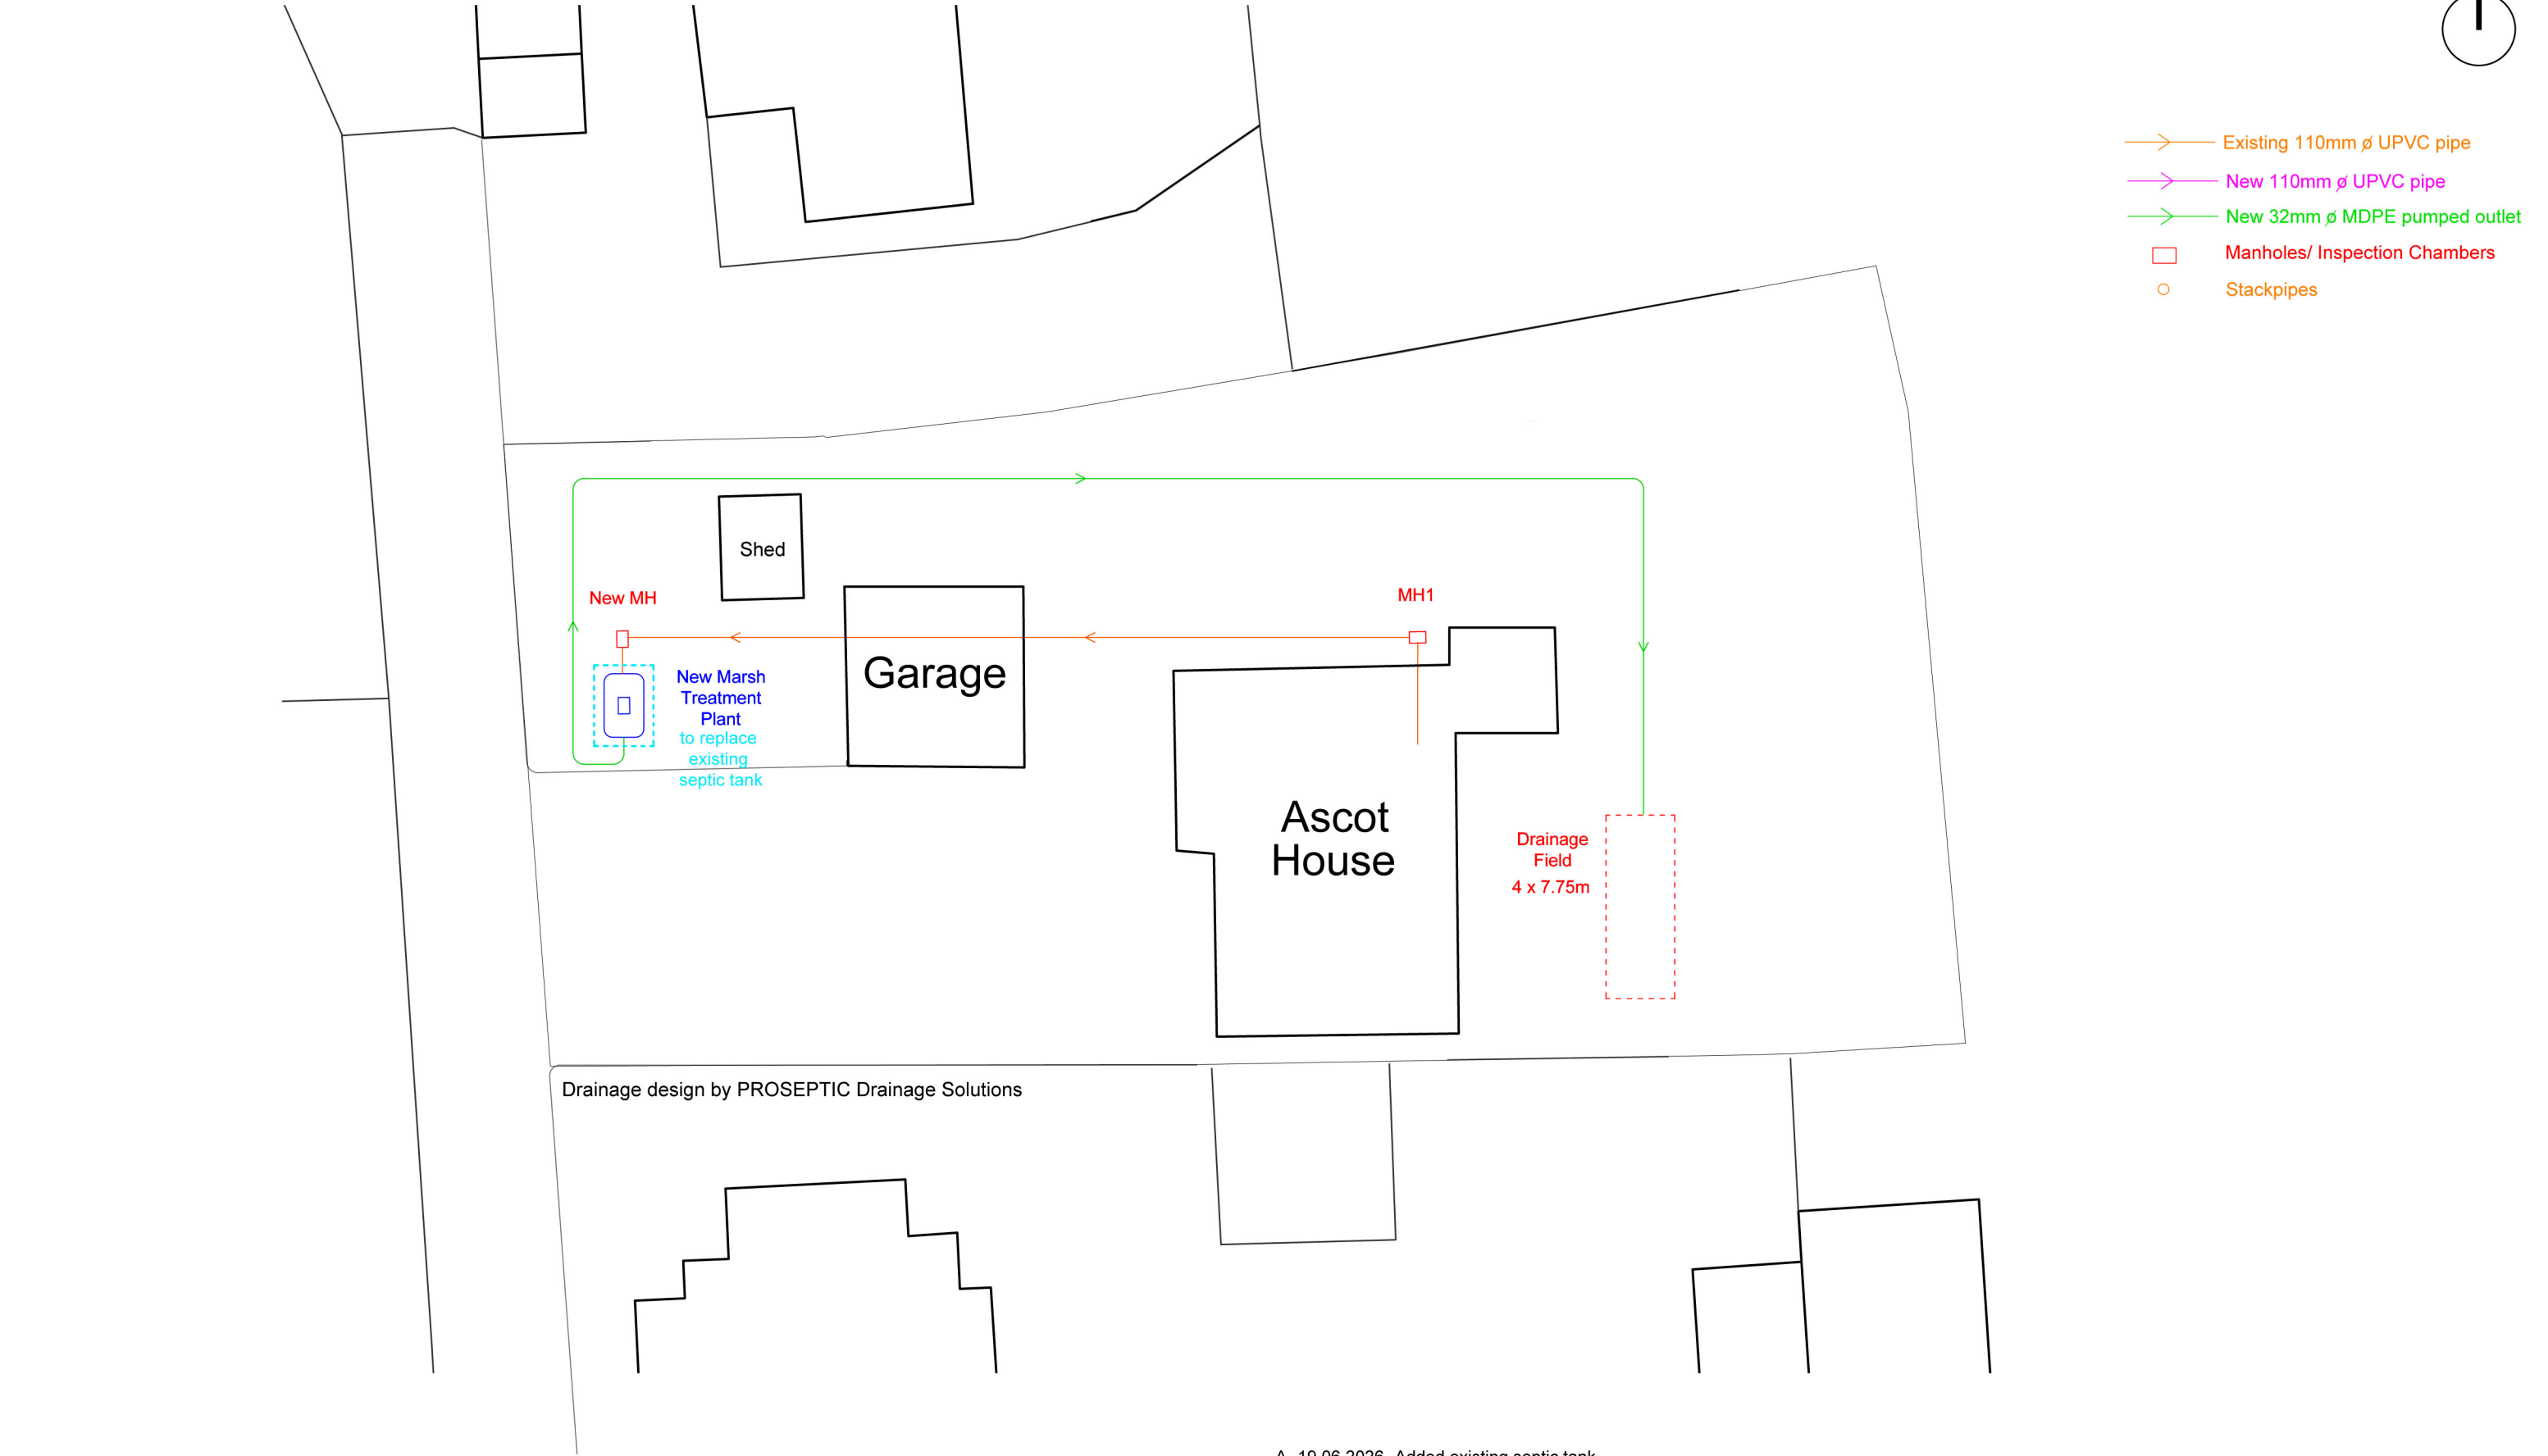

Drainage design by PROSEPTIC Drainage Solutions

A- 19.06.2026- Added existing septic tank

Client - Mr G Baker & Ms E Scott		Contractors must check all dimensions on site. Only figured dimensions are to be worked from. Discrepancies must be reported to the Architect before proceeding. THIS DRAWING IS COPYRIGHT. ©			The Studio 105 Southbroom Road Devizes Wiltshire SN10 1LY tel: 01380 722 204 mob:07733 885 770 www.dra-architects.co.uk	
Project - Proposed Works at Ascot House, Wilsford, Pewsey, Wiltshire, SN9 6HB	Date - 14.05.2026	By - CL	Scale - 1:200 @A3	A		
Drawing - Proposed Site Plan	Job No - 2605	CHKD - NK	Drawing No - PL-001			

