



SOUTH NEWTON HOSPITAL
68.01 kWp

This drawing contains proprietary information belonging to Revolution Energy Services Ltd and may not wholly or partially be reproduced nor disclosed without prior written permission of Revolution Energy Services Ltd
DO NOT SCALE FROM THIS DRAWING

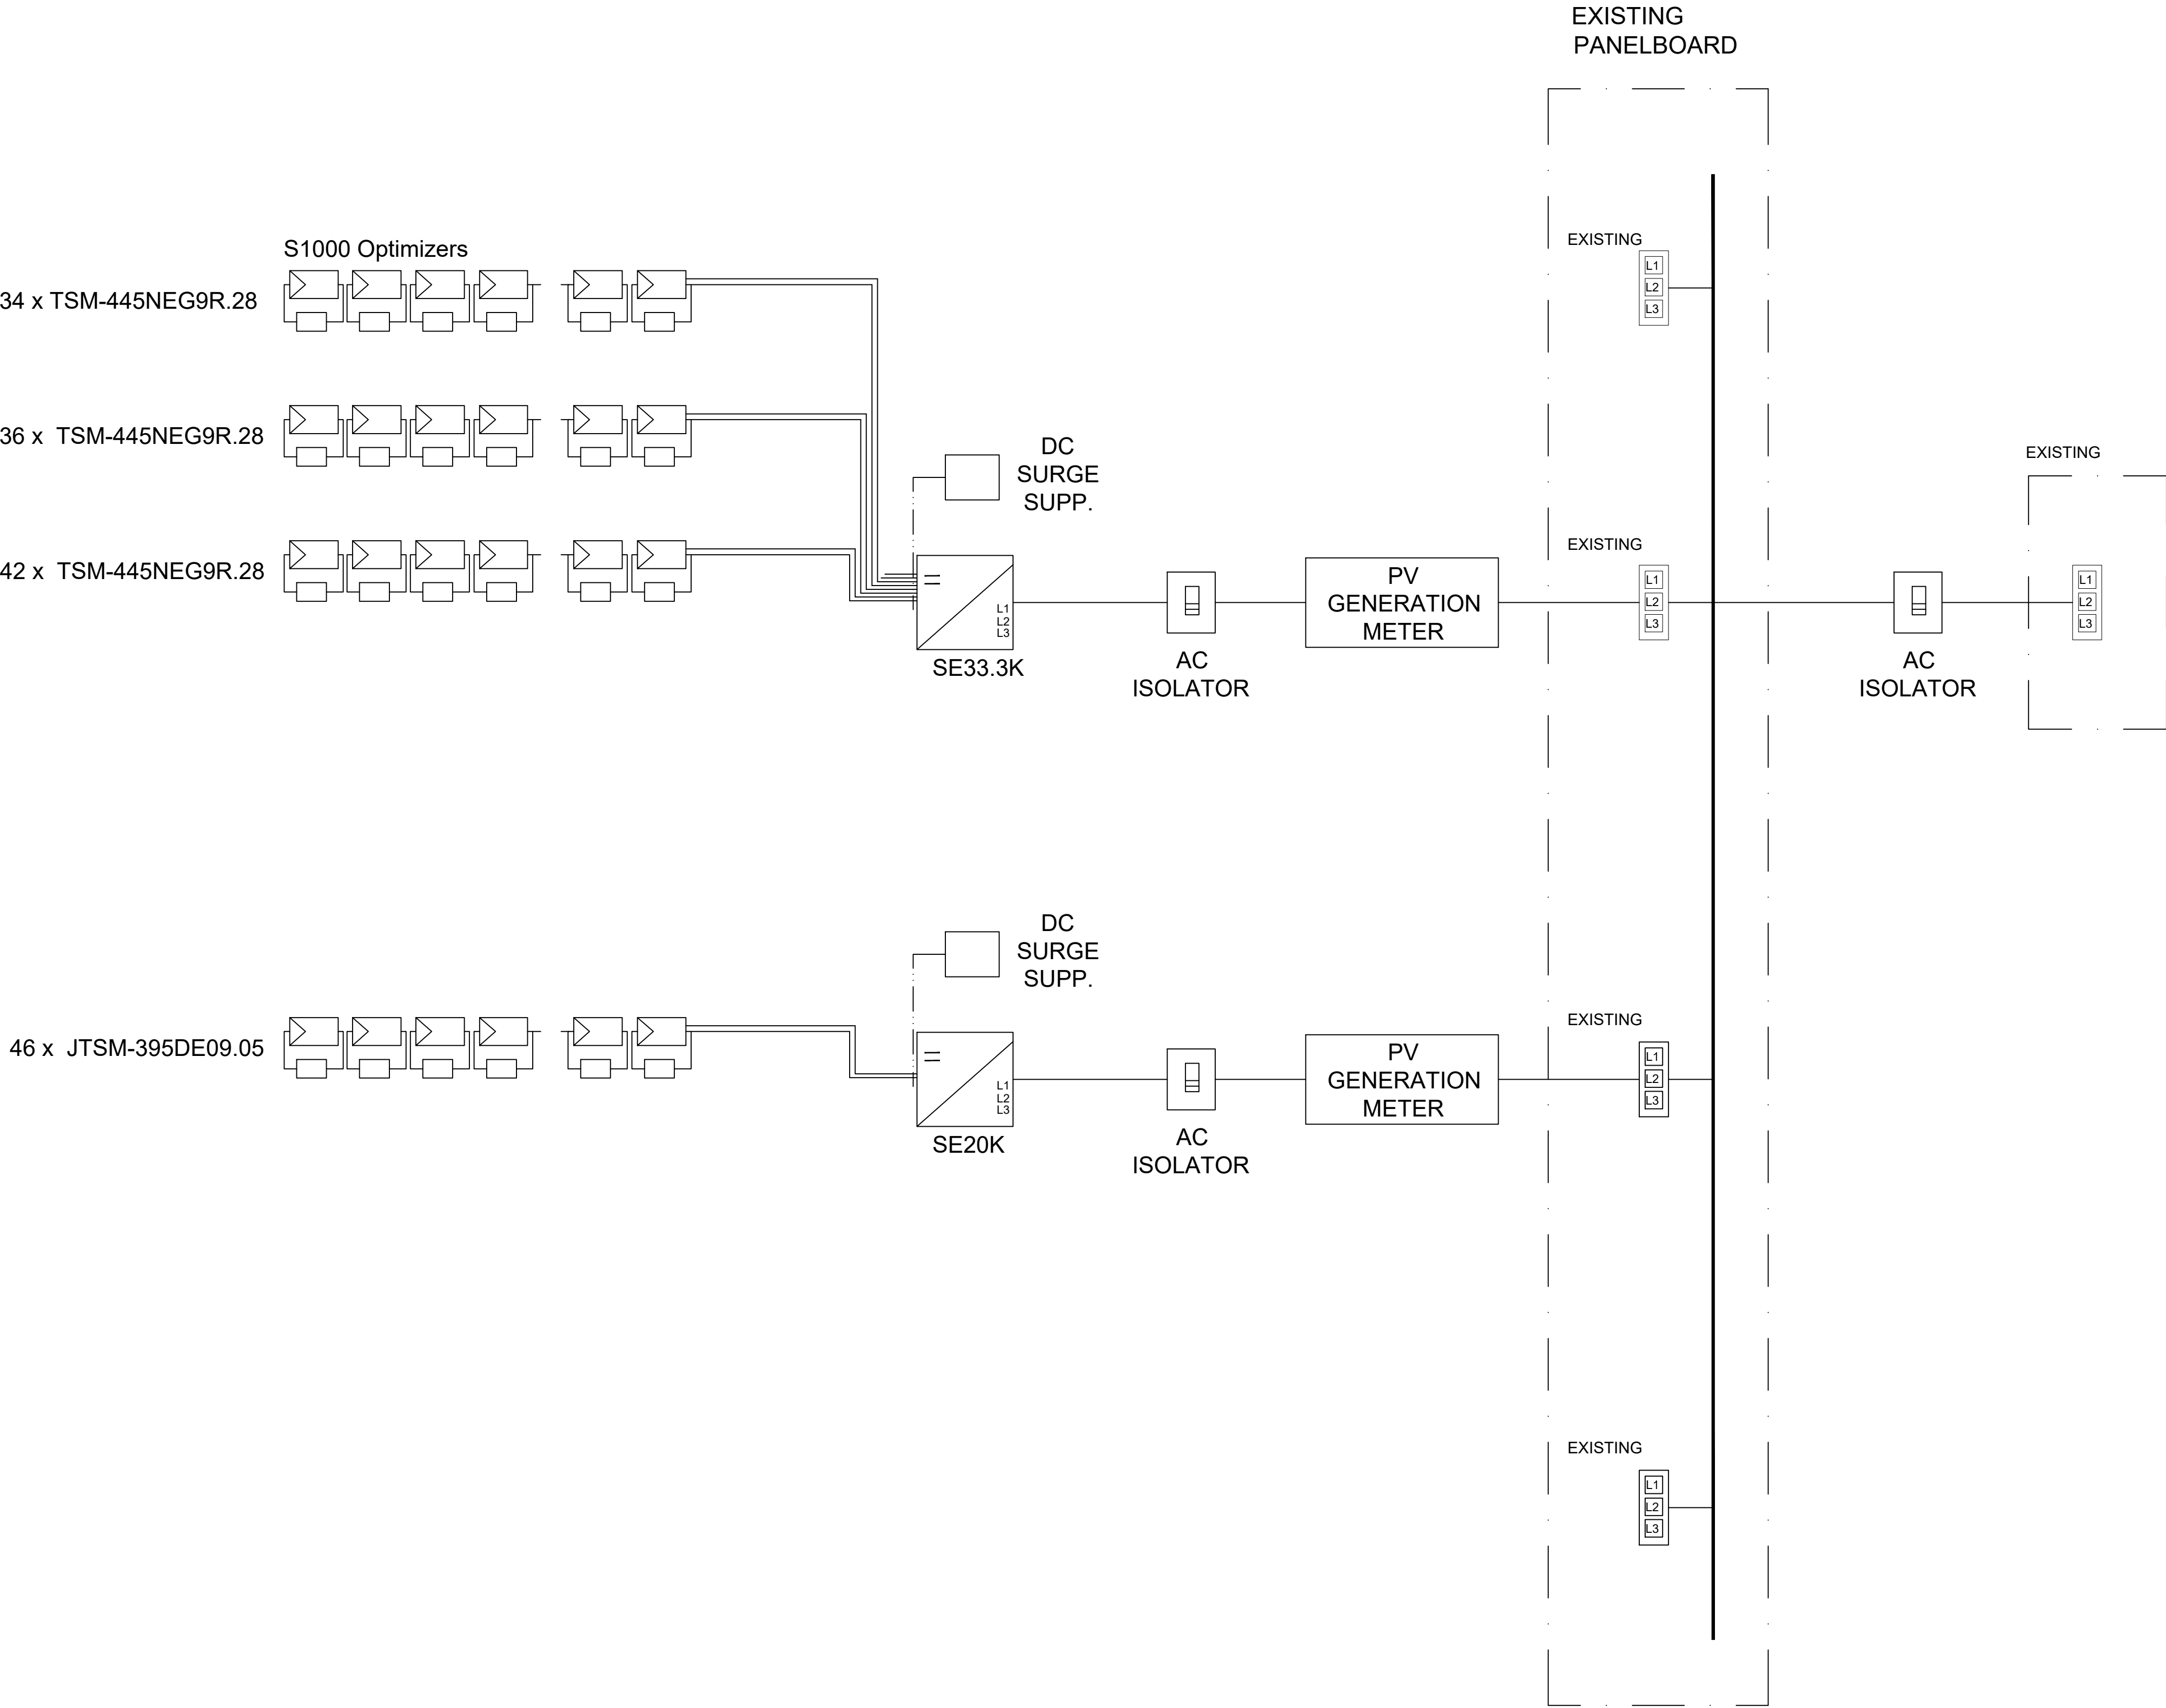

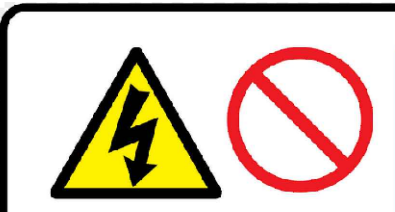

WARNING
Dual Supply

Do not work on this equipment until it is isolated from both mains and on-site generation supplies.

Isolate on-site generator at

Isolate mains supply at

Revisions:

Rev	Date	Comments	Drawn
00	11.25	FIRST ISSUE	CB

Client: SOUTH NEWTON HOSPITAL
Location: WARMINSTER ROAD
SOUTH NEWTON, SP2 0QD

Title: SOUTH NEWTON HOSPITAL
PV SINGLE LINE DIAGRAM

Drawn: RES
Scale: NTS@A1
Drawing No: RES00385-4

Checked: AM
Date: 22/04/26
Rev: 00