
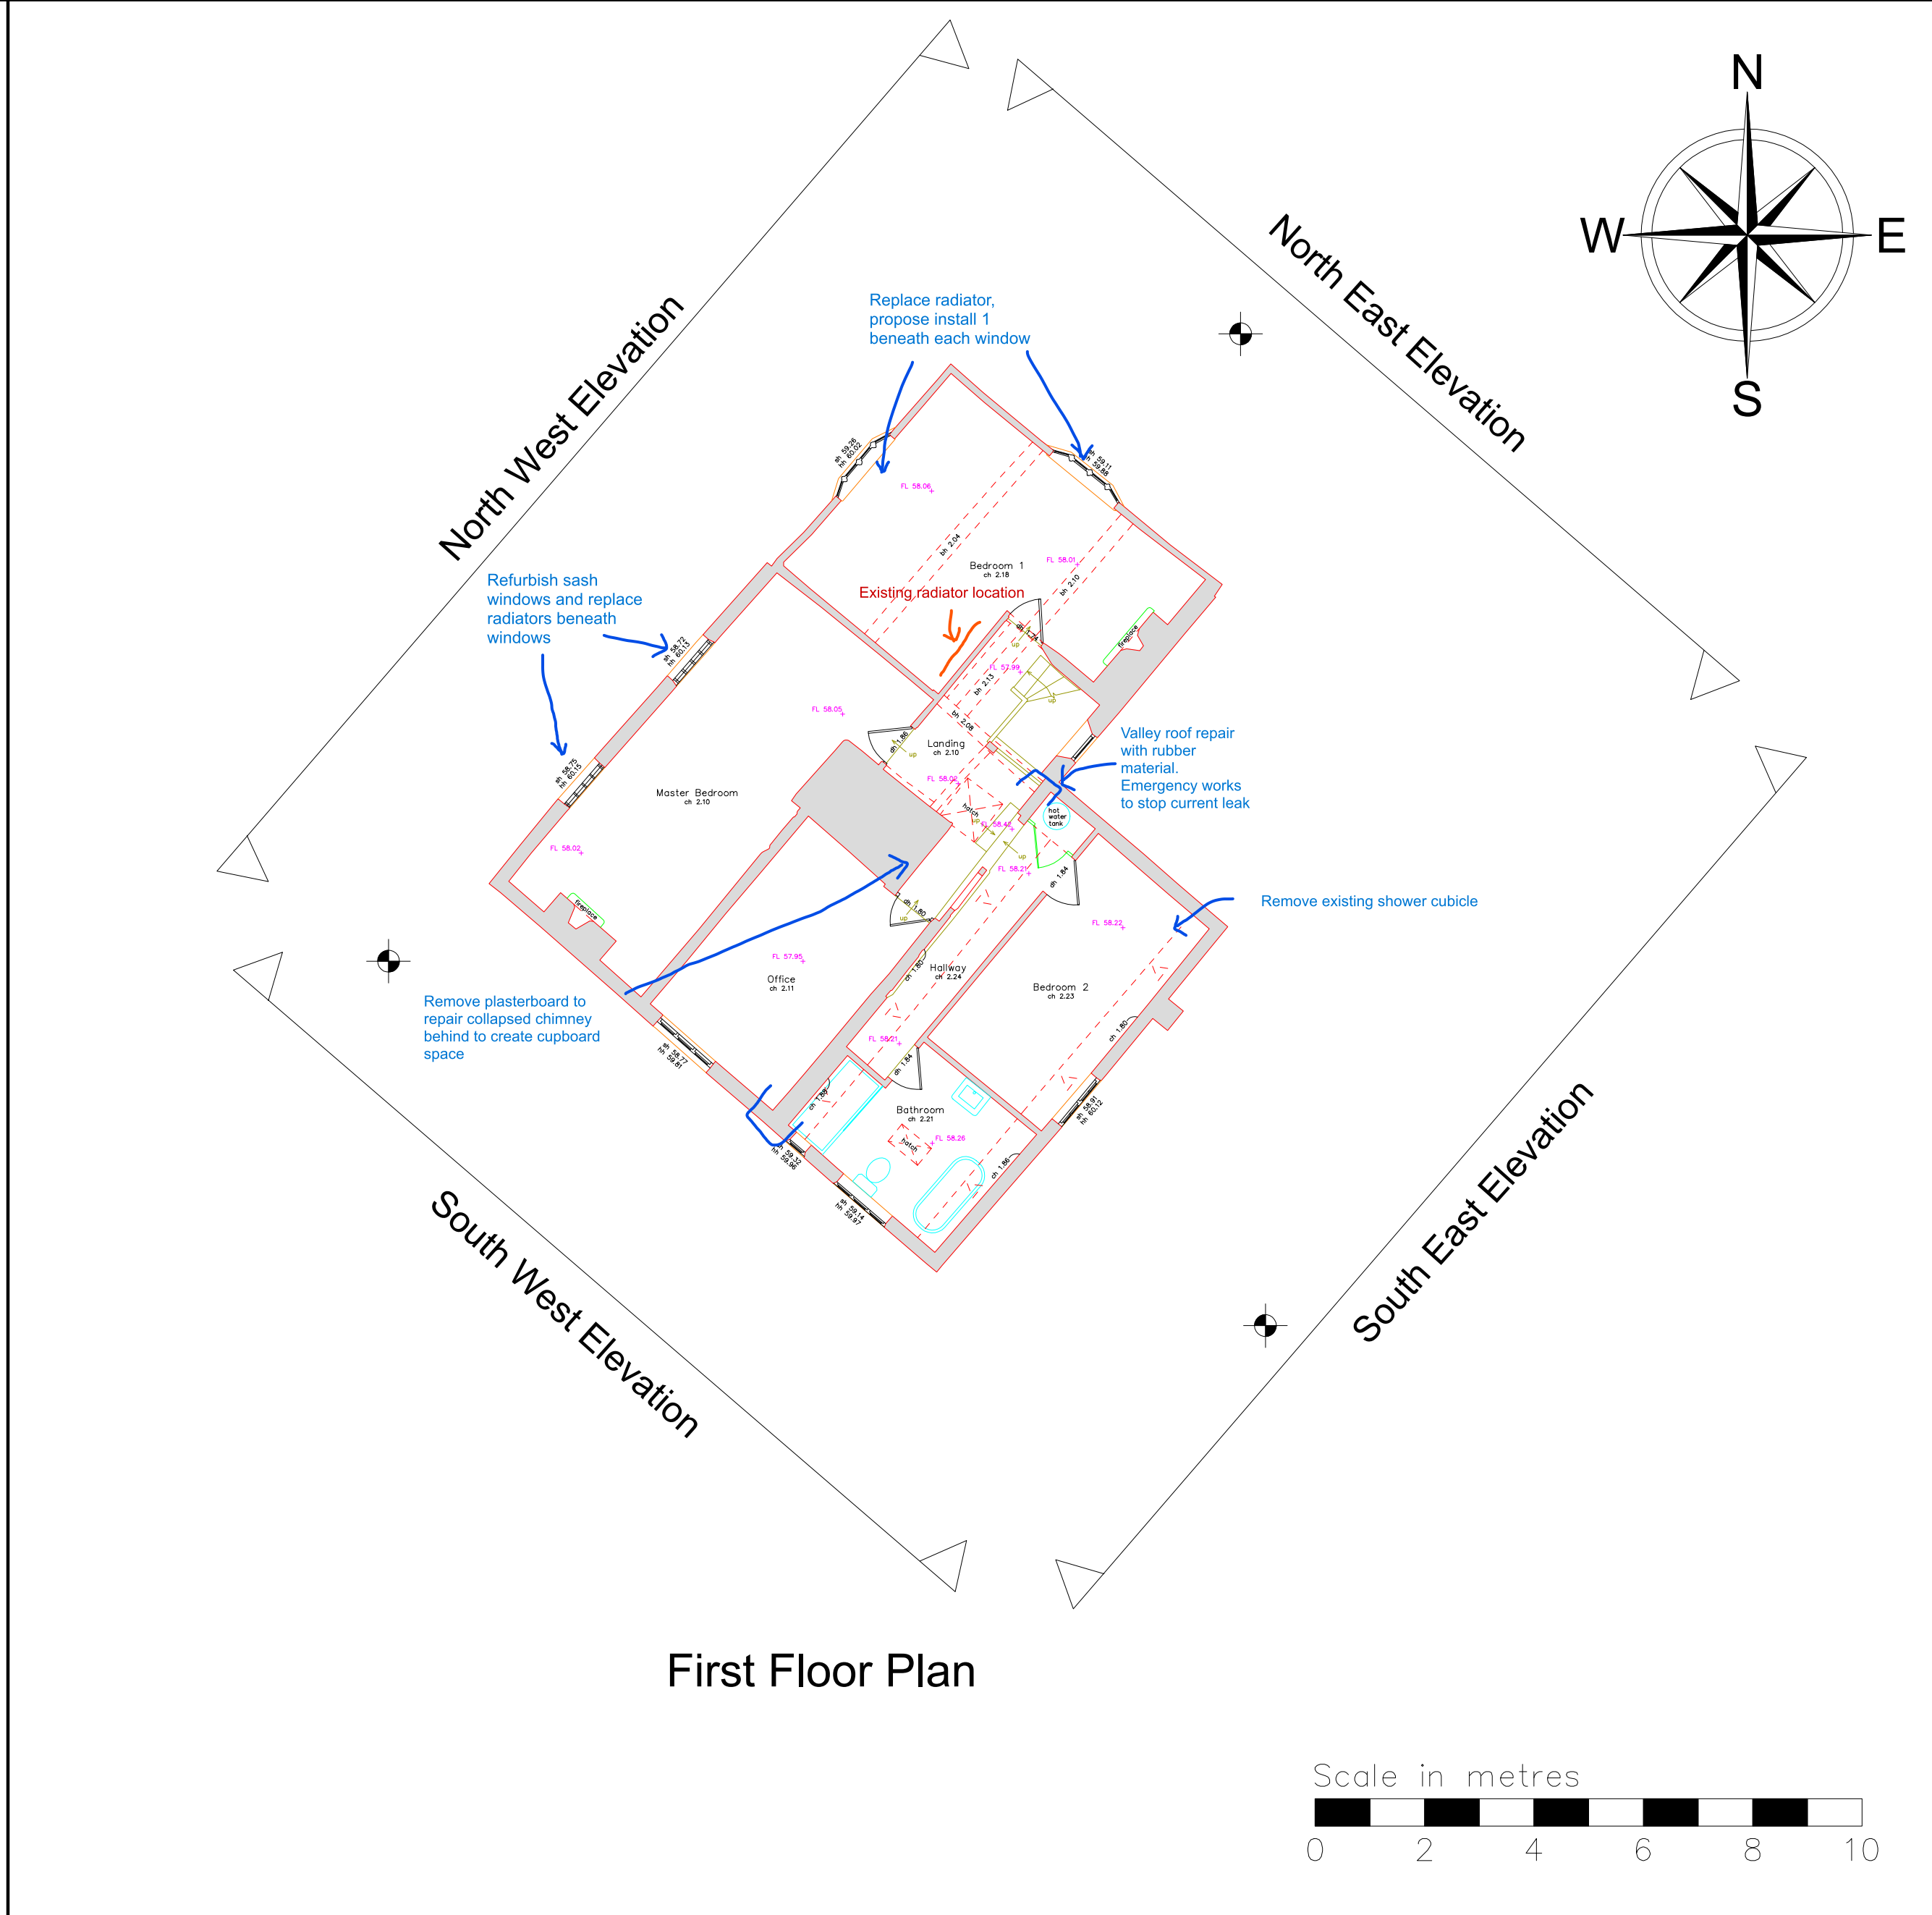


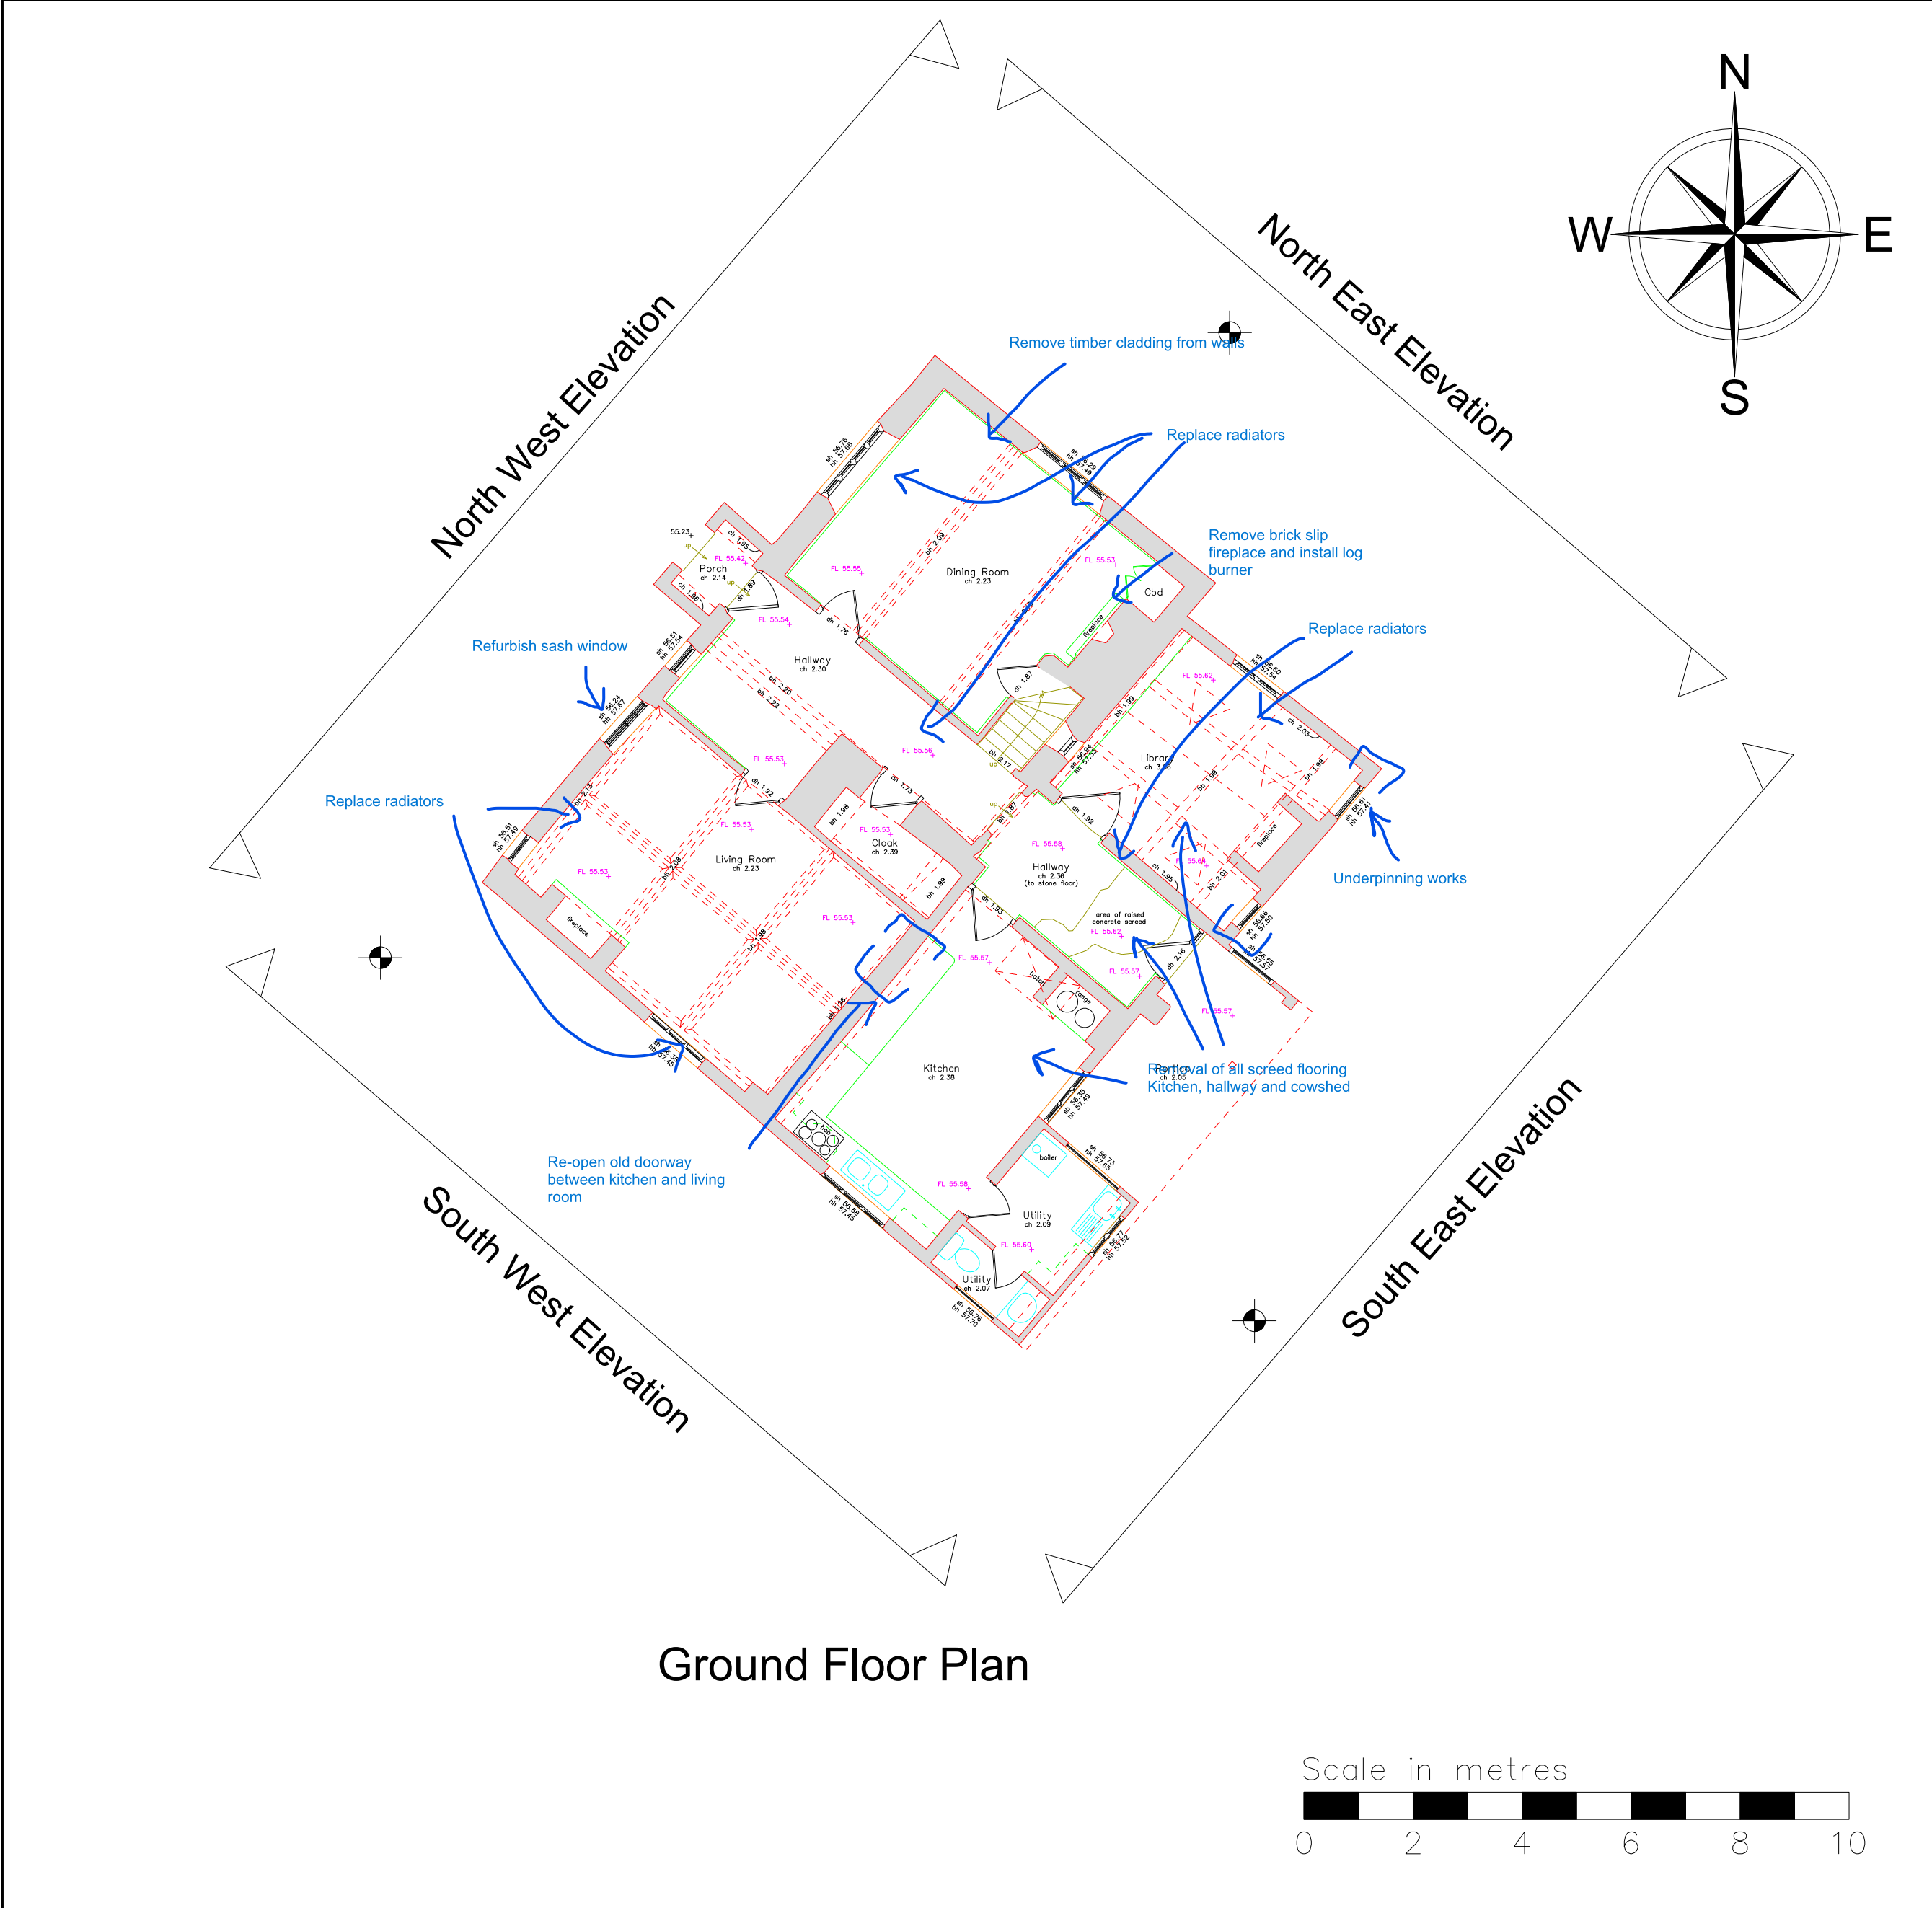

- Notes
- This survey has been computed and drawn about Ordnance Survey (OS) grid co-ordinates and is orientated to grid North by GPS Survey.
 - All levels are in metres and relate to the Ordnance Survey (OS) National Datum by GPS Survey. Station 01 has been used as the site datum and has an accepted level of 54.43m.
 - This survey was surveyed for a scale of 1:200, any subsequent enlargements should be verified on site.
 - All eave levels are measured at bottom of fascia board or end of roofing sheets if no fascia board is present.
 - Whilst every care has been taken, no responsibility can be accepted for errors or omissions caused by detail obscured or not accessible at the time of this survey.
 - Visible features in the vicinity of the boundaries, as shown on this survey, may not represent the extent of legally conveyed ownership.
 - Floor plan measurements have been taken at 1m above floor level and an indicative outline of the structure has been drawn. The walls may slope and curve therefore any critical building alteration dimensions should be verified with on-site checks, in particular for any cob or traditionally plastered walls.

Topographic Survey Legend			
AC	Air Conditioning Unit	MKR	Marker Post
AE	Aerial	MP	Milepost
AV	Air Valve	MS	Milestone
BB	Belisha Beacon	NB	Notice Board
BL	Best Level	OHC	Overhead Cable
BOL	Bollard	P	Post
BS	Borehole	B/W	Barbed Wire Fence
BS	Bus Stop	P/C	Post and Chain Fence
BT	BT Inspection Chamber	P/R	Post and Rail Fence
C/B	Close Boarded Fence	P/W	Post and Wire Fence
C/L	Chain Link Fence	PB	Post Box
C/PL	Corrugated Plastic	PBOX	Post Box
CATV	Cable Television	RM	Rodding Eye
CCTV	Control Box	RG	Road Gully
CL	Cover Level	RIS	Reflector Post
CPS	Concrete Paving Slabs	RS	Road Sign
DK	Drop Kerb	R/S	Road Traffic Signal
DWP	Down Water Pipe	RWP	Rain Water Pipe
EP	Electricity Pole	SC	Stop Cook
ER	Earth Rod	S/F	Security Fencing
FB	Flower Bed	SOS	Emergency Telephone
FH	Fire Hydrant	SP	Sign Post
FL	Floor Level	SPC	Speed Camera
FWS	Foul Water Sewer	SV	Stop Valve
G	Gully	SVP	Soil & Vent Pipe
G 0.8	Girth of Tree 0.8m	sws	Storm Water Sewer
GB	Gate Post	TGB	Telephone Call Box
GP	Gas Post	THL	Threshold Level
GV	Gas Valve	TP	Triolith
HH	Header Height	T/P	Timber Palling Fence
IR	Iron Rolling Fence	TOW	Top of Wall Level
IW	Interwoven Fence	UTR	Unable to Raise
IC	Inspection Cover	V	Valve
IL	Insulation Level	VP	Vent Pipe
JB	Junction Box	W/M	Wiremesh Fence
KO	Kerb Outlet	WM	Water Meter
LB	Lamp Post	WSV	Water stop valve
LP	Lamp Post		
MH	Manhole		
Channel and Drop Kerb Line		Walls	
Building		Fence	
Fence		Banks	
Ridge Line		Ridge Line	
Overhead Cables		Overhead Cables	
Verge		Verge	
Foliage / Hedgerow		Foliage / Hedgerow	
Canopy		Canopy	
Tree Height		Tree Height	

Measured Building Survey Legend

ab	Air Brick	hh	Head Height
ah	Apex Height	ic	Inspection Cover
bh	Beam Height	il	Invert Level
ch	Ceiling Height	mh	Manhole
cl	Cover Level	rad	Radiator
dh	Door Height	rw	Rainwater Pipe
dpc	Damp Proof Course	sh	Sill Height
fch	False Ceiling Height	sph	Spring Height
fl	Floor Level	avp	Air Vent Pipe
gfl	Ground Floor Level	utr	Unable to Raise
ffl	First Floor Level	vhh	Vent Head Height
hh	Head Height	vsh	Vent Sill Height
ic	Inspection Cover		
il	Invert Level		

Cob or Plaster

Drainage

Steps and stairs

Structure

Structure Overhead

Stud walls

Thatch Roof

Timber Fittings

Window and Door detail

Radiator



0	10	Millimetres	100		
Rev.	Description	By	Date	Chk'd	Auth
FORCE TEN SURVEY Office 1, The Grove, The Underfleet, Seaton, Devon, EX12 2FU. 01297 300705 07940 522974 admin@forcetensurvey.com www.forcetensurvey.com					
Client Tim Humpage Esq.					
Project Eastfield House Plough Lane, Marston Devizes, Wiltshire, SN10 5SR					
Title Floor Plans & Elevations					
Original Scale 1:100@A1	Surveyor AR	Checked AP	Authorised Draft		
Drawing Number 2025_119_01	Date 21.10.25				Rev 0

Scale in metres

0 2 4 6 8 10

Sheet 4