


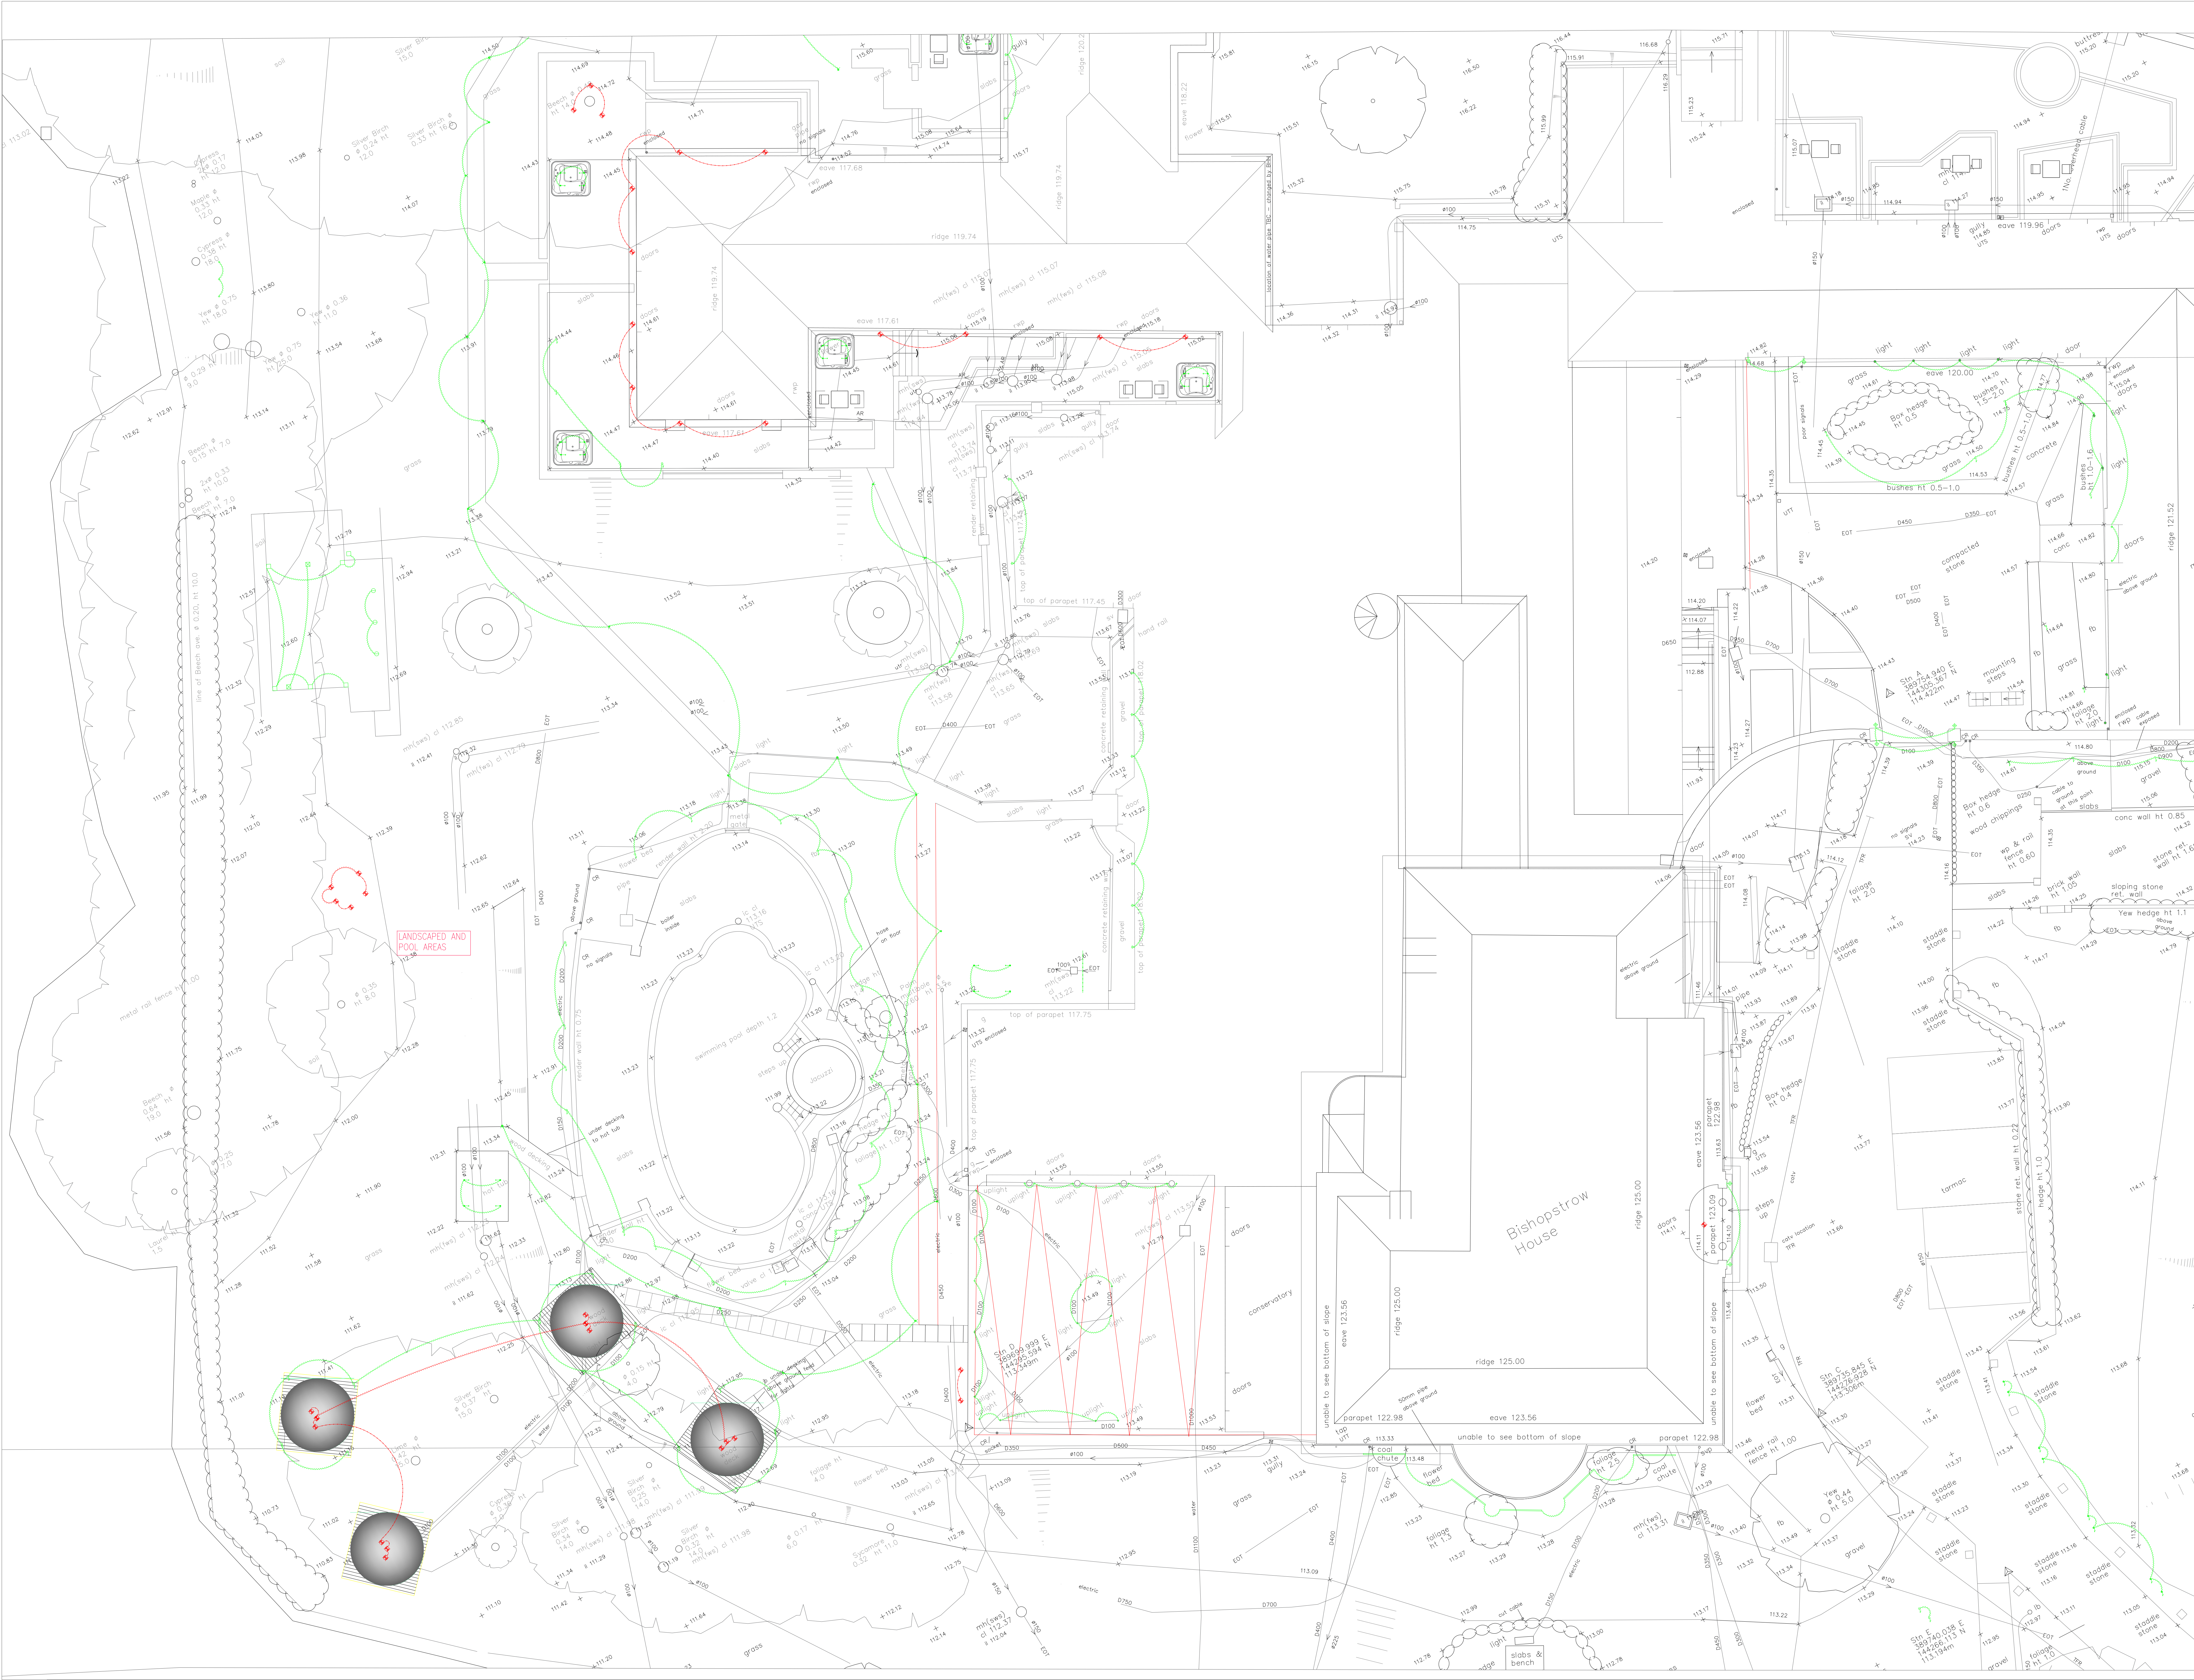

SUSAN LAKE LIGHTING DESIGN LTD
THE HIVE, 66 HIGH STREET
LEWES BN7 1XG
E: susan@sld.lighting
T: 01273 934 381 M: 0774 3963 851

DRAWING TO BE READ IN CONJUNCTION WITH
SPECIFICATION DOCUMENT 141-501.
DO NOT SCALE FROM THIS DRAWING.
ANY DISCREPANCIES ARE TO BE RAISED WITH SLD FOR
FURTHER CLARIFICATION.

SYMBOL	L. REF.	DESCRIPTION
		FLOOR RECESSED SMALL UPLIGHTER
		FLOOR RECESSED LARGE UPLIGHTER
		SPIKE MOUNTED UPLIGHT TO PLANTER
		SPIKE MOUNTED UPLIGHT TO SMALL TREES
		SPIKE MOUNTED UPLIGHT TO LARGE TREES
		WALL RECESSED STEP LIGHT
		PATH LIGHTS
		HOT TUB UNDERBATH SPOT LIGHTS
		SURFACE MOUNTED SQUARE UPLIGHT
		SURFACE MOUNTED UPLIGHT
		WALL LIGHT
		DECORATIVE PENDANTS TO TREES
		DECORATIVE WALL LANTERNS
GREEN		LOW LEVEL LIGHTING
RED		HIGH LEVEL LIGHTING

0 1 2 3 4 5 10

SCALE BAR 1:100 @ A0

REV	DESCRIPTION	DATE
--	ISSUED FOR INFORMATION	18.07.2025

EXTERIOR LIGHTING PLAN

PROJECT NAME	BISHOPSTROW HOUSE HOTEL		
DRAWING No:	141-04		
1-100 @ A0	18.07.2025	REV: --	