
 


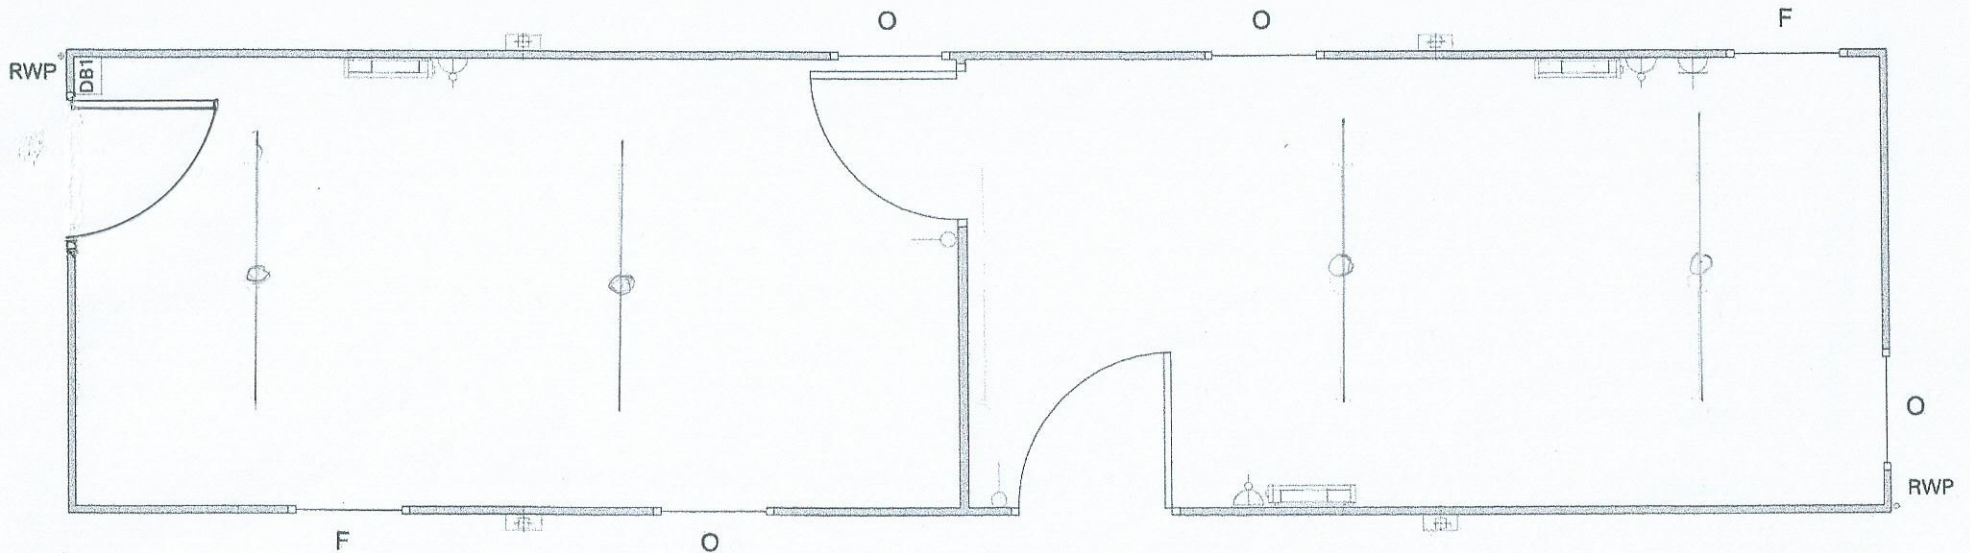

Carpeting Throughout

KEY

	- Cat 2 Lighting		- Window Blinds		- Opening Window
	- Cat 1 Lighting		- Window Shutter		- Fixed Window
	- Consumer Unit		- Coat Hooks		- Sliding Window
	- Double Socket		- Background Vent		- Rain Water Pipe
	- Single Socket		- Std Partition		- Wire Mesh Guards
	- Heater With Spur		- 30min Fire Partition		- Obscure Window
	- Wall Light Switch				



SCALE BAR 1:50 on A4

Title:- Sunday School Floor Plans		Client:- Emmanuel Church Chippenham		Drawing Provided By :- Swindon Hire Centre	DO NOT SCALE OFF THIS DRAWING	Portakabin Quality this time - next time – every time
Date:- 21/7/26	Scale:- 1:50 on A4	Drawn By:- NEC				
Revision:- A	Drawing Number:- 1	Unit Number:- HFH0524873				