



©2020 Cellnex
All rights reserved. No part of this publication may be reproduced, stored in a retrieval system or transmitted in any form or by any means (Electronic, Mechanical, Photocopying, Recording or otherwise), without the prior written consent of the Company.

NOTES

PROJECT No. COL.MOD.UK.0009912

BTEE No. 94094

MBNL ID. ECA004

H3G ID. CB0299

6	COL.MOD.UK.0009912 PLANNING	09-07-26	WHP	WHP
5	172476 AS BUILT	27/04/17	WHP	JH
4	172476 AS BUILT	27/11/15	DAL	JH
3	172476 PLANNING	18/08/15	DAL	CGP
2	164588 AS BUILT	06/11/14	AT	JW
ISS	REVISION	DATE	DRN	APP



CELLNEX UK
R+, 4TH FLOOR, 2 BLAGRAVE STREET, READING, RG1 1AZ
Tel. 020 4526 8553

SITE No. UK-WI-005296
CASTLE COMBE RACING CIRCUIT
CASTLE COMBE
CHIPPENHAM
WILTSHIRE
SN14 7EY

NGR ST 85645 77100


OS GRID 385645 177100

TITLE
SITE PLAN
PROPOSED
BTEE - PRIMARY AREA POWER RESILIENCE

SCALE 1:100

DRAWN	IM	19/08/11
APPROVED	WHP	09-07-26

DRG No.	Sheet 1 of 1	Rev
UKWI005296-02-100-MD006		6

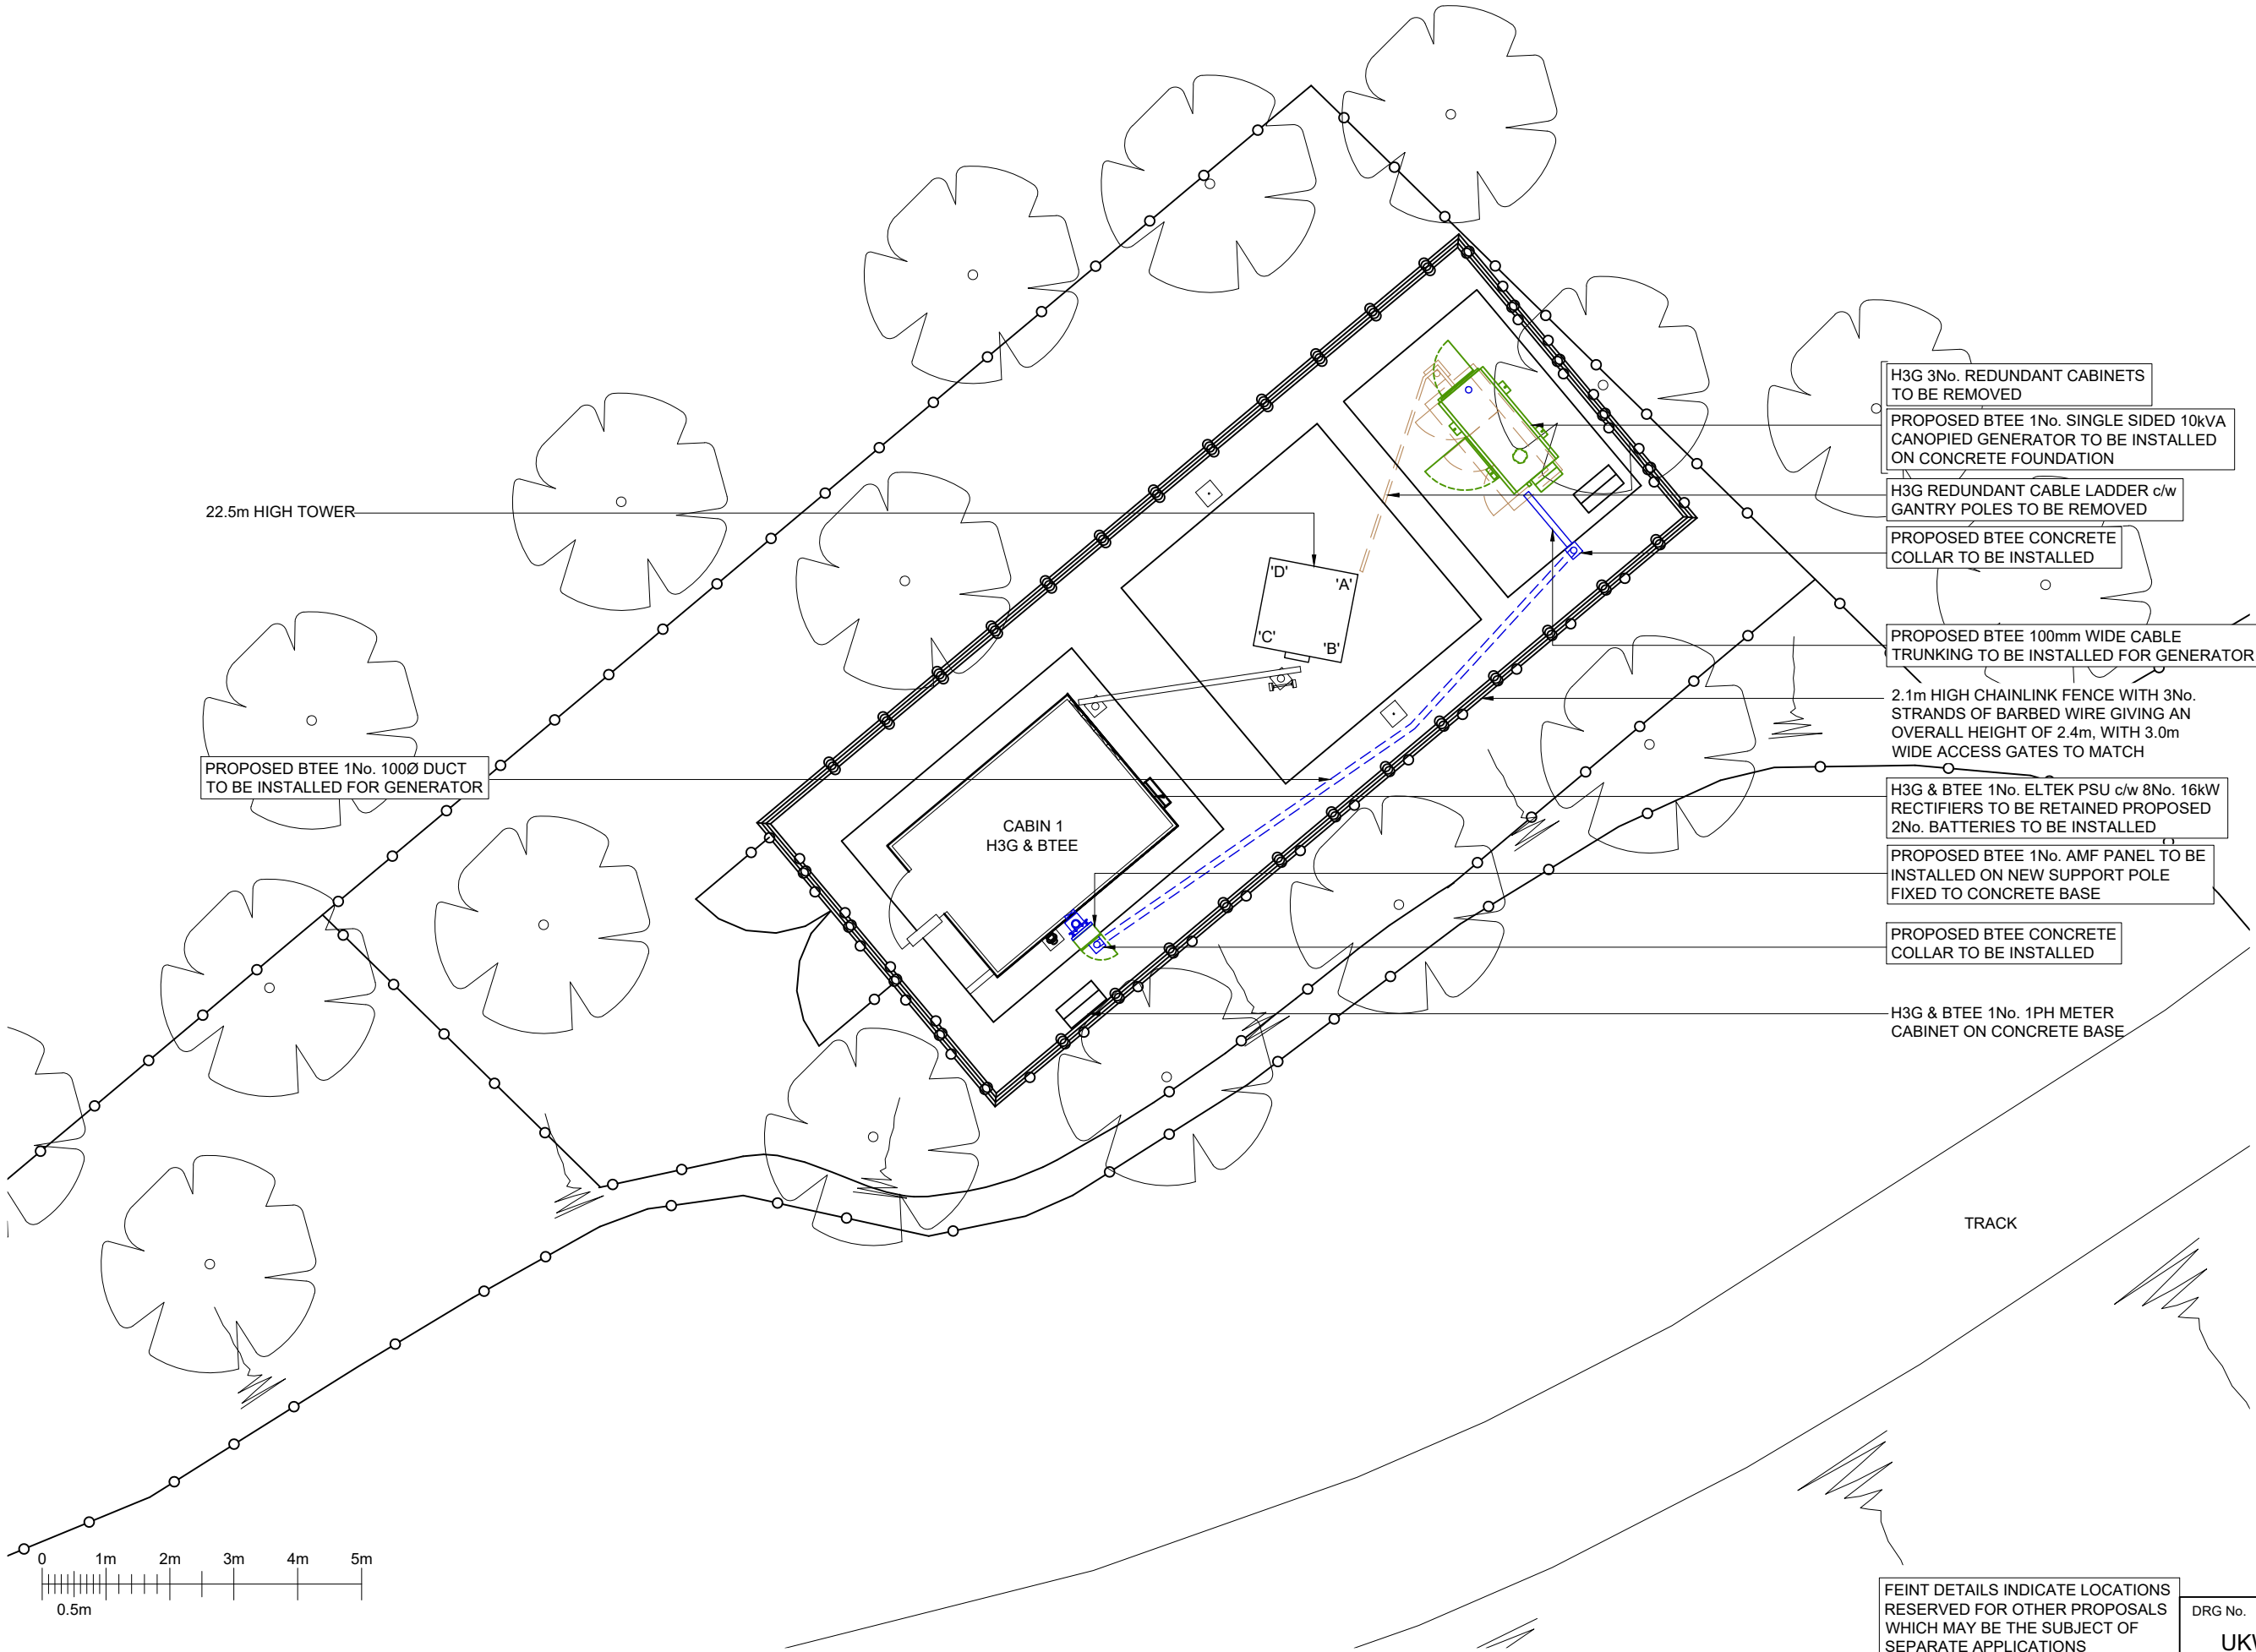

22.5m HIGH TOWER

PROPOSED BTEE 1No. 100Ø DUCT
TO BE INSTALLED FOR GENERATOR

CABIN 1
H3G & BTEE

H3G 3No. REDUNDANT CABINETS
TO BE REMOVED

PROPOSED BTEE 1No. SINGLE SIDED 10kVA
CANOPIED GENERATOR TO BE INSTALLED
ON CONCRETE FOUNDATION

H3G REDUNDANT CABLE LADDER c/w
GANTRY POLES TO BE REMOVED

PROPOSED BTEE CONCRETE
COLLAR TO BE INSTALLED

PROPOSED BTEE 100mm WIDE CABLE
TRUNKING TO BE INSTALLED FOR GENERATOR

2.1m HIGH CHAINLINK FENCE WITH 3No.
STRANDS OF BARBED WIRE GIVING AN
OVERALL HEIGHT OF 2.4m, WITH 3.0m
WIDE ACCESS GATES TO MATCH

H3G & BTEE 1No. ELTEK PSU c/w 8No. 16kW
RECTIFIERS TO BE RETAINED PROPOSED
2No. BATTERIES TO BE INSTALLED

PROPOSED BTEE 1No. AMF PANEL TO BE
INSTALLED ON NEW SUPPORT POLE
FIXED TO CONCRETE BASE

PROPOSED BTEE CONCRETE
COLLAR TO BE INSTALLED

H3G & BTEE 1No. 1PH METER
CABINET ON CONCRETE BASE

FEINT DETAILS INDICATE LOCATIONS
RESERVED FOR OTHER PROPOSALS
WHICH MAY BE THE SUBJECT OF
SEPARATE APPLICATIONS