



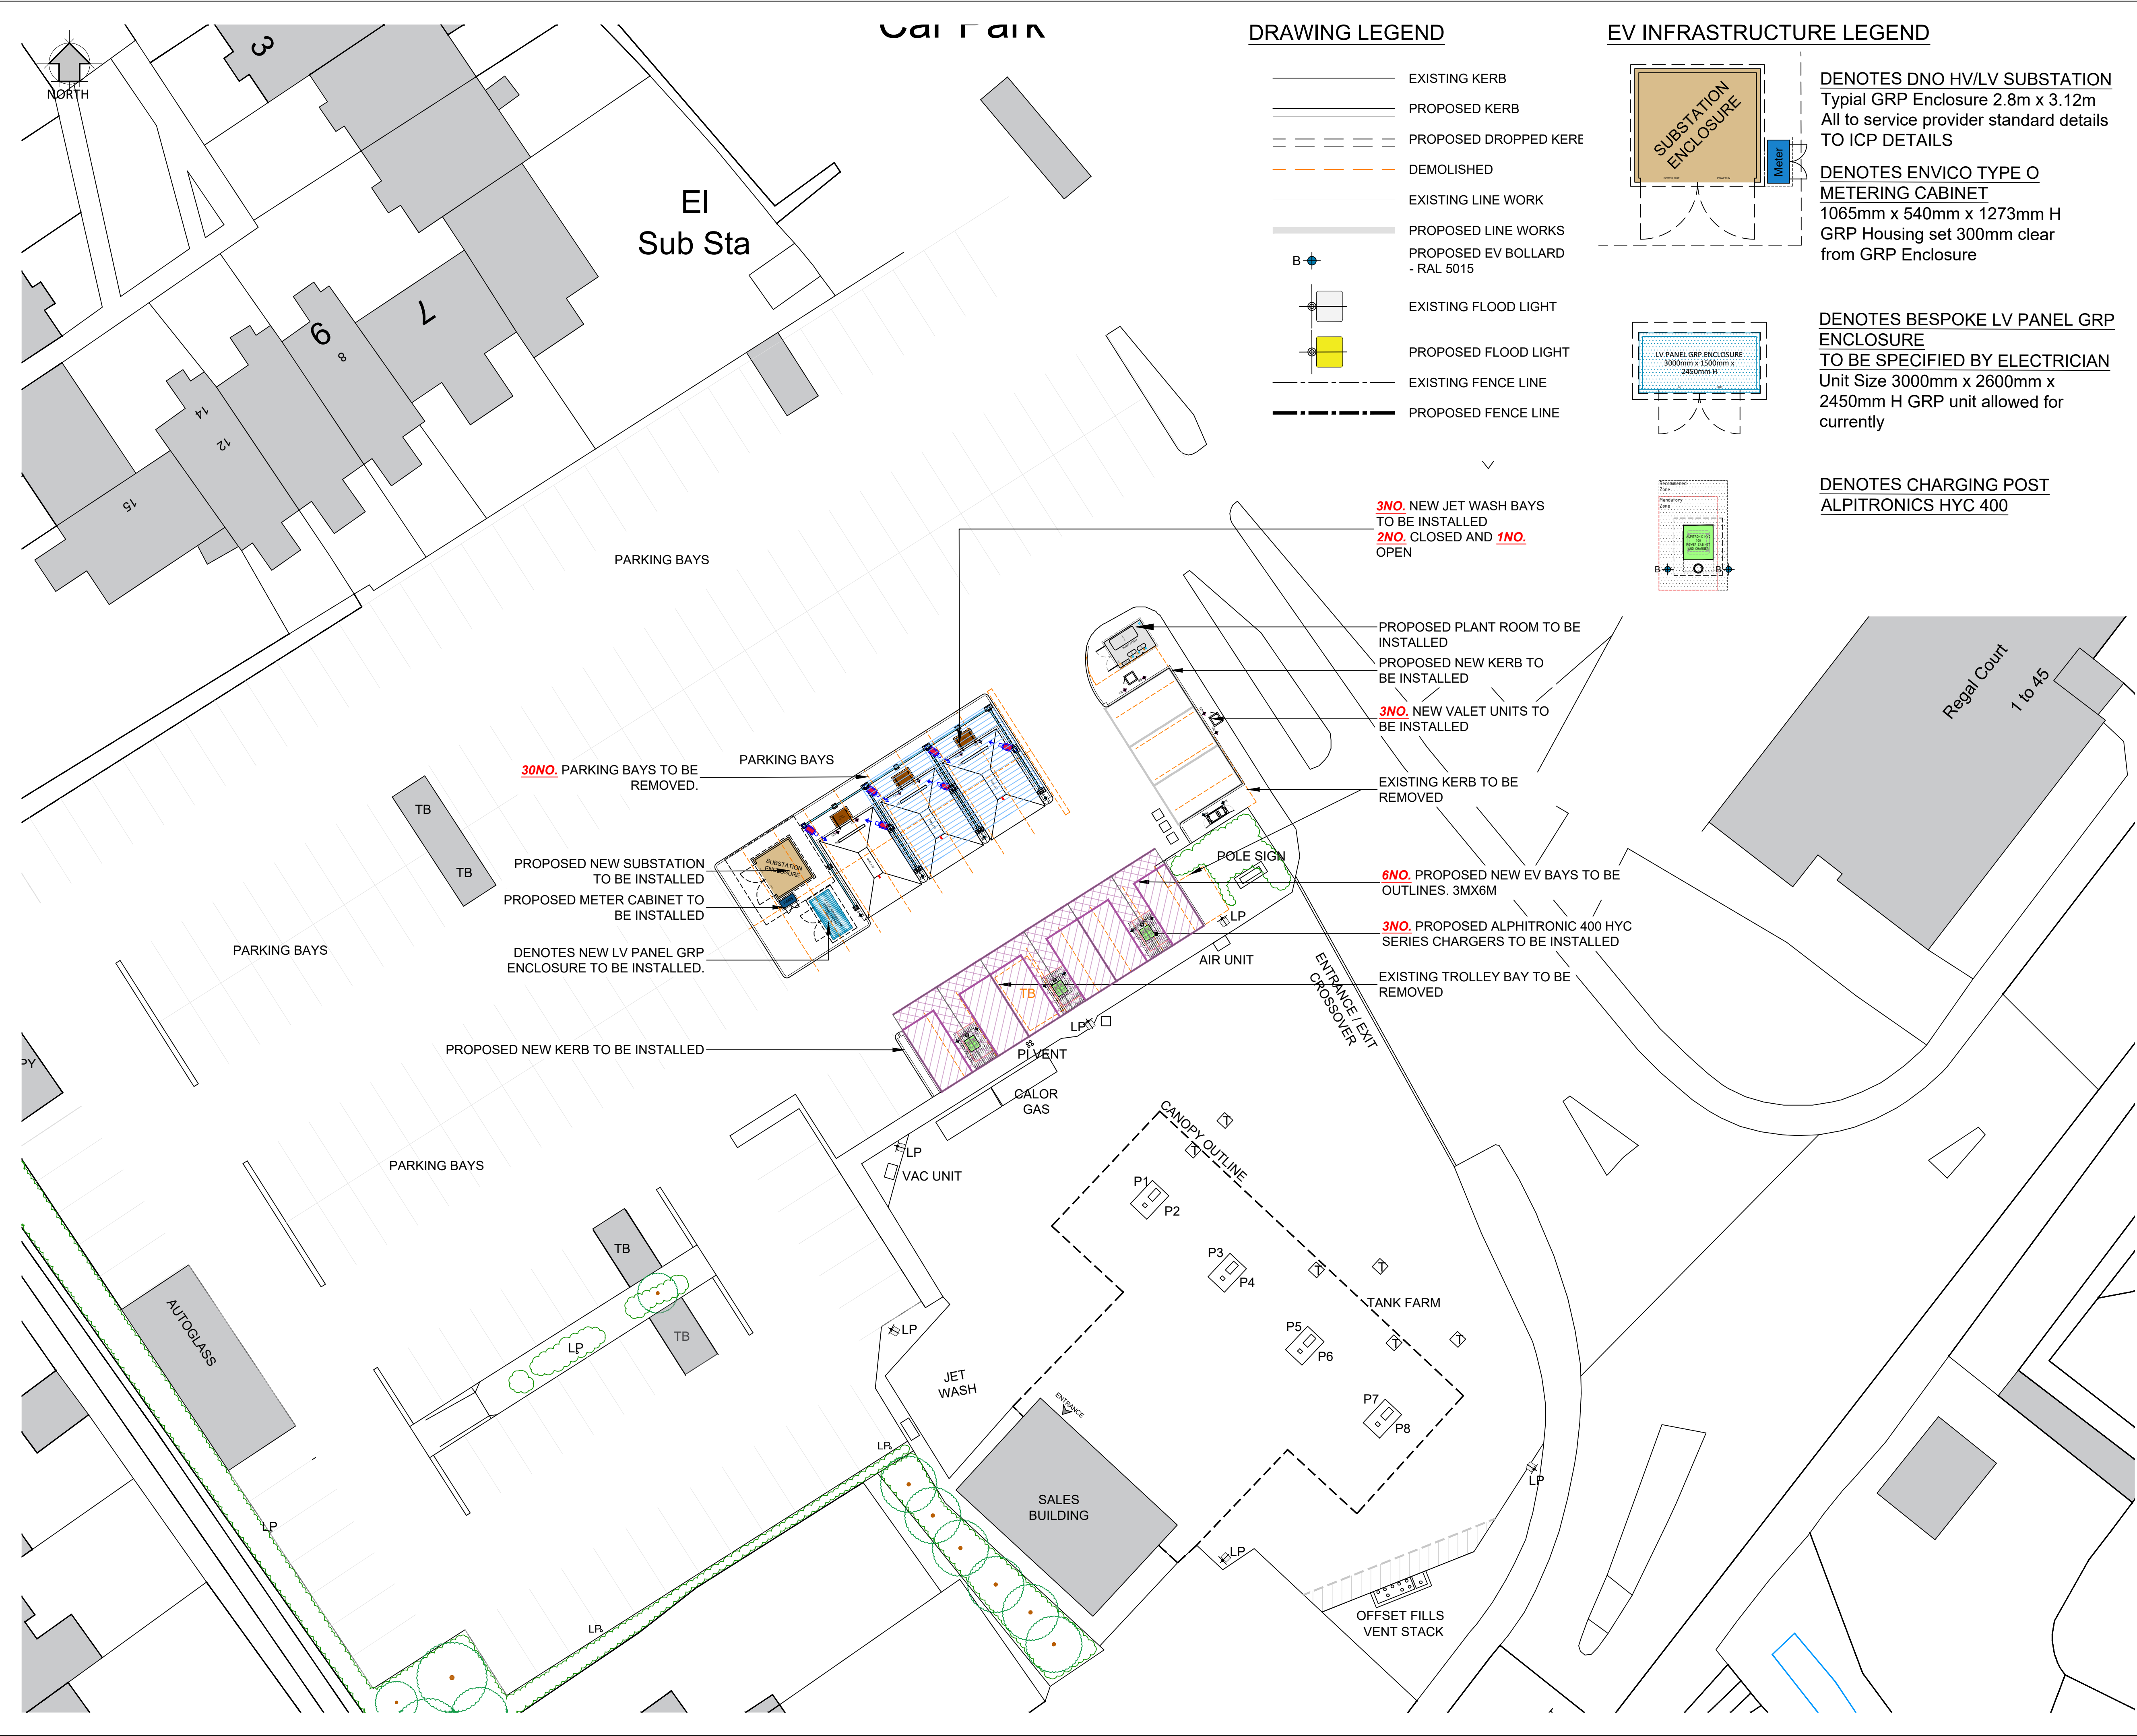


DRAWING LEGEND

- EXISTING KERB
- PROPOSED KERB
- PROPOSED DROPPED KERE
- DEMOLISHED
- EXISTING LINE WORK
- PROPOSED LINE WORKS
- PROPOSED EV BOLLARD - RAL 5015
- EXISTING FLOOD LIGHT
- PROPOSED FLOOD LIGHT
- EXISTING FENCE LINE
- PROPOSED FENCE LINE


EV INFRASTRUCTURE LEGEND

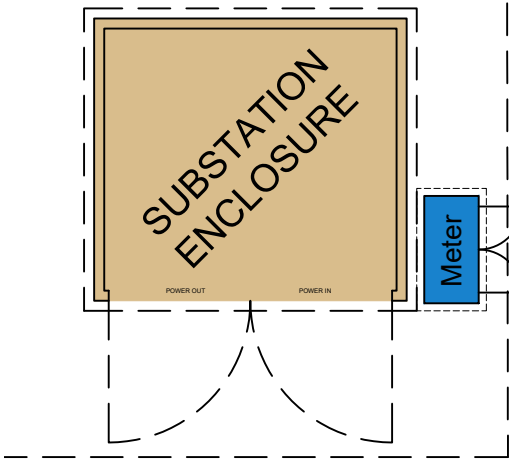

DENOTES DNO HV/LV SUBSTATION
Typical GRP Enclosure 2.8m x 3.12m
All to service provider standard details
TO ICP DETAILS

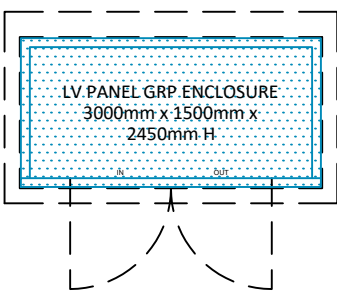

DENOTES ENVICO TYPE O
METERING CABINET
1065mm x 540mm x 1273mm H
GRP Housing set 300mm clear
from GRP Enclosure

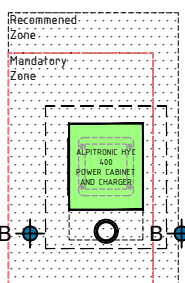

DENOTES BESPOKE LV PANEL GRP
ENCLOSURE
TO BE SPECIFIED BY ELECTRICIAN
Unit Size 3000mm x 2600mm x
2450mm H GRP unit allowed for
currently

DENOTES CHARGING POST
ALPITRONICS HYC 400

3NO. NEW JET WASH BAYS
TO BE INSTALLED
2NO. CLOSED AND **1NO.**
OPEN

PROPOSED PLANT ROOM TO BE
INSTALLED
PROPOSED NEW KERB TO
BE INSTALLED

3NO. NEW VALET UNITS TO
BE INSTALLED

EXISTING KERB TO BE
REMOVED

6NO. PROPOSED NEW EV BAYS TO BE
OUTLINES. 3MX6M

3NO. PROPOSED ALPHITRONIC 400 HYC
SERIES CHARGERS TO BE INSTALLED

EXISTING TROLLEY BAY TO BE
REMOVED

30NO. PARKING BAYS TO BE
REMOVED.

PROPOSED NEW SUBSTATION
TO BE INSTALLED
PROPOSED METER CABINET TO
BE INSTALLED

DENOTES NEW LV PANEL GRP
ENCLOSURE TO BE INSTALLED.

PROPOSED NEW KERB TO BE INSTALLED


DRAWING NOTES

COPYRIGHT ©
This drawing and the details herein are the copyright of MBH Design Studio Ltd. and must
not be reproduced, altered or passed to any third party without prior written consent.
This drawing has been produced for the project listed below, is submitted in support of this
application application to the Local Planning Authority and is not intended for use by any
other person or for any other purpose.
Every effort has been made to ensure the accuracy of these drawings, however MBH Design
Studio Ltd. accept no responsibility for any discrepancies arising from the reuse of survey
information and preliminary drawings commissioned by the Applicant from others.

GENERAL NOTES

- This drawing has been prepared for the sole purpose of obtaining
planning permission.
- This drawing is to be read in conjunction with drawings numbered:

14313-3340-LP	Location Plan
14313-3340-BP	Block Plan
14313-3340-200	Existing Site Plan
14313-3340-201	Proposed Site Plan
14313-3340-206	EV Canopy and Charger Details
14313-3340-207	Substation Enclosure Details
14313-3340-208	LV Enclosure Details
14313-3340-209	Meter Cabinet Details
14313-3340-210	Jet Wash Plan and Elevations
14313-3340-211	Air/Water and Vac Details
14313-3340-212	Plant Room Elevations
- Any advertisements are indicative and are subject to a separate
advertisement application
- Any neighbouring buildings shown on the elevations are
diagrammatic and have been extrapolated from site photographs.
They have not been measured.

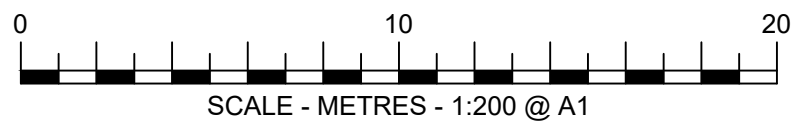

REV	DATE	DESCRIPTION	DRAWN/CHECKED
REVISION NOTES			

PLANNING

MBH Design Studio Ltd.
Rosemount House, Rosemount Avenue, West Byfleet, Surrey, KT14 6LB
www.mbhstd.com t: 01932 352 727 f: 01932 351 545

CLIENT

PROJECT

FS3340 - WARMINSTER MORRISONS
WEYMOUTH STREET,
WARMINSTER,
BA12 9NT

DRAWING TITLE

PROPOSED SITE PLAN

DRAWN BY	DATE	SCALE	PAPER SIZE
KL	20.07.2026	1:200	A1
CHECKED BY	DRAWING NUMBER	REV.	
RRB/RRB	14313-3340-201	-	