




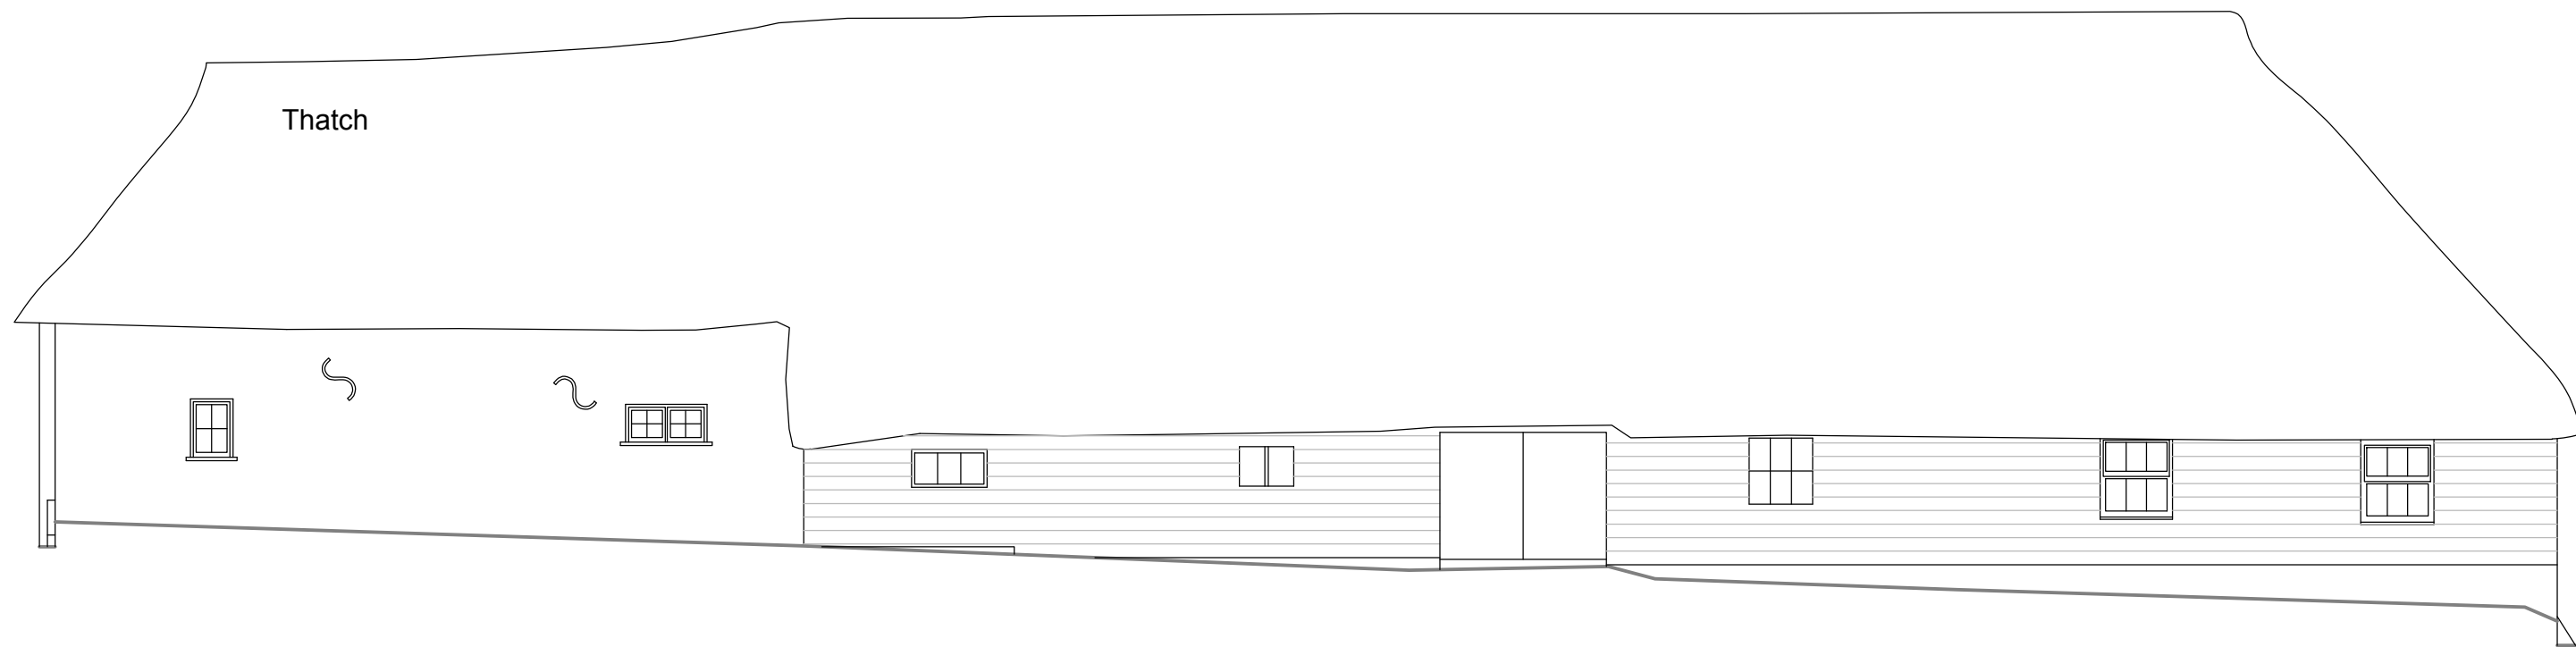


Existing north elevation 1:100

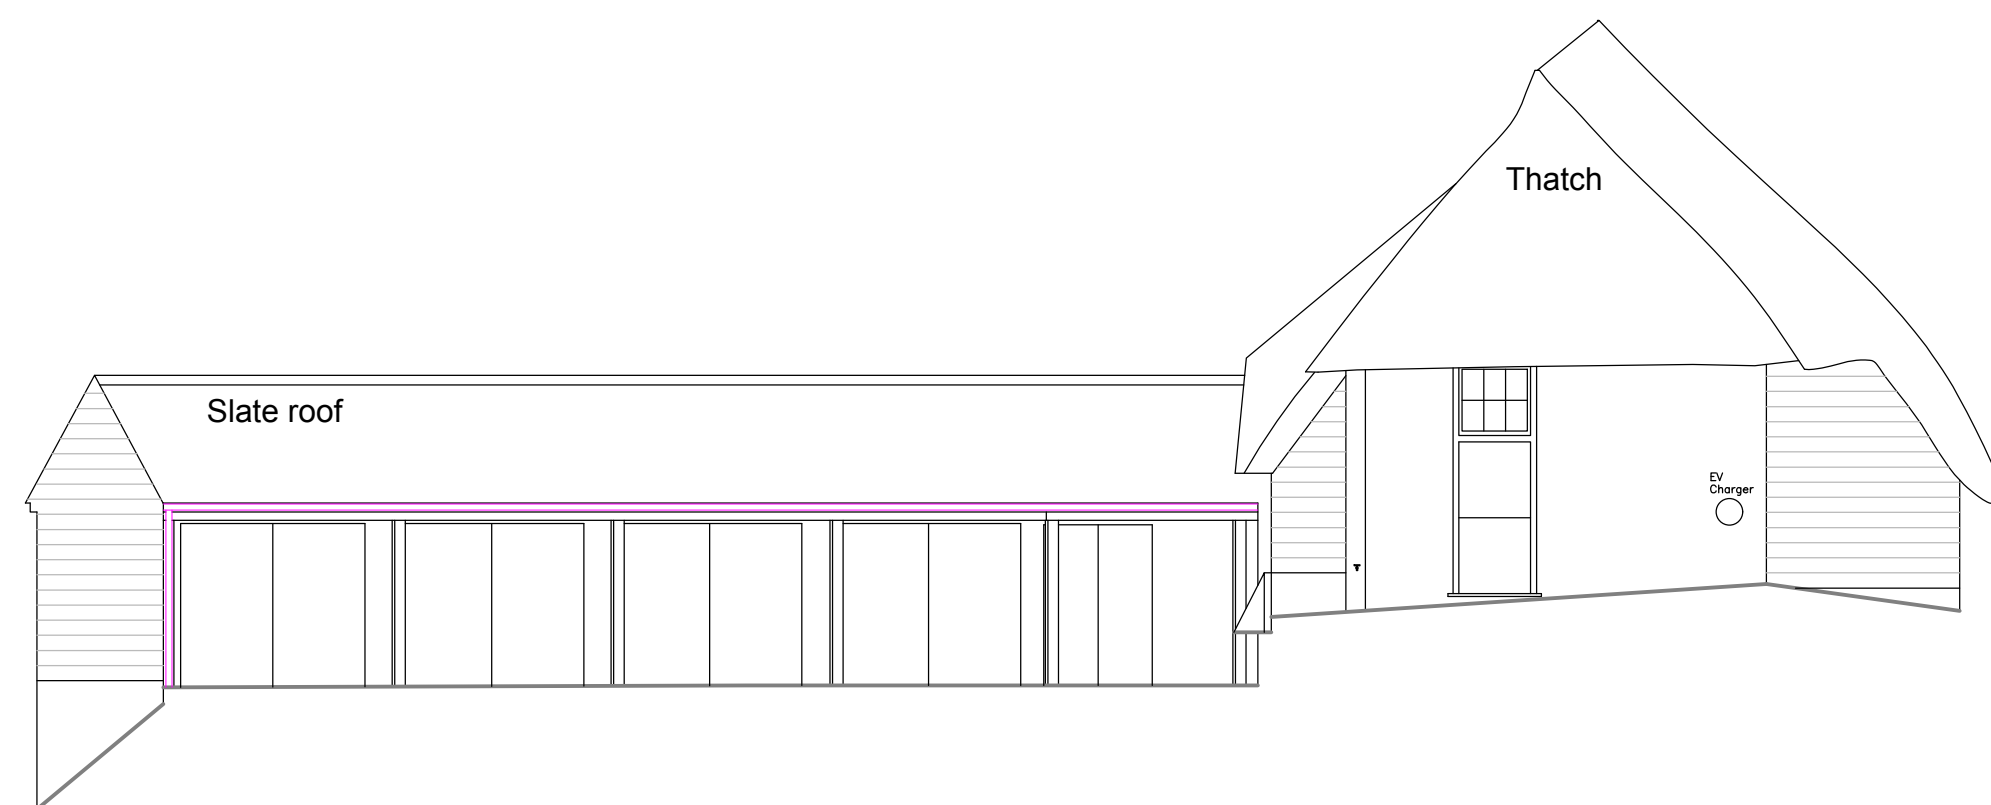


Existing east elevation 1:100

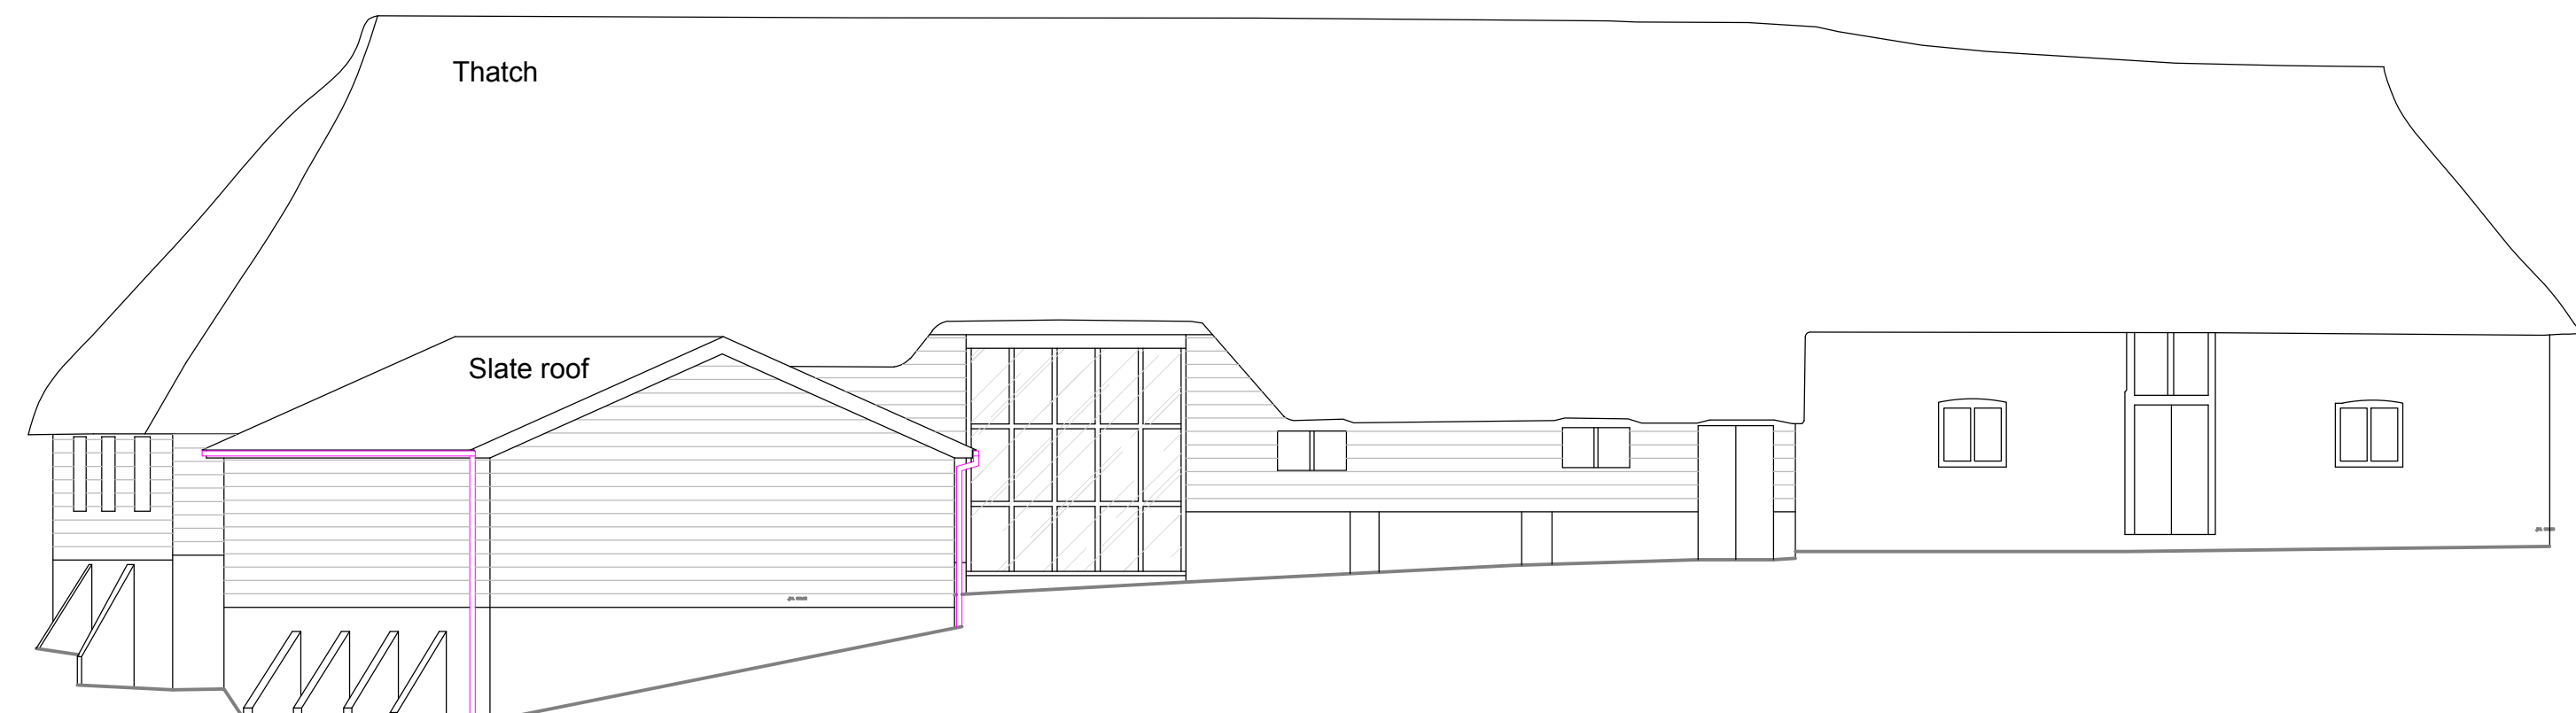


Existing south elevation 1:100

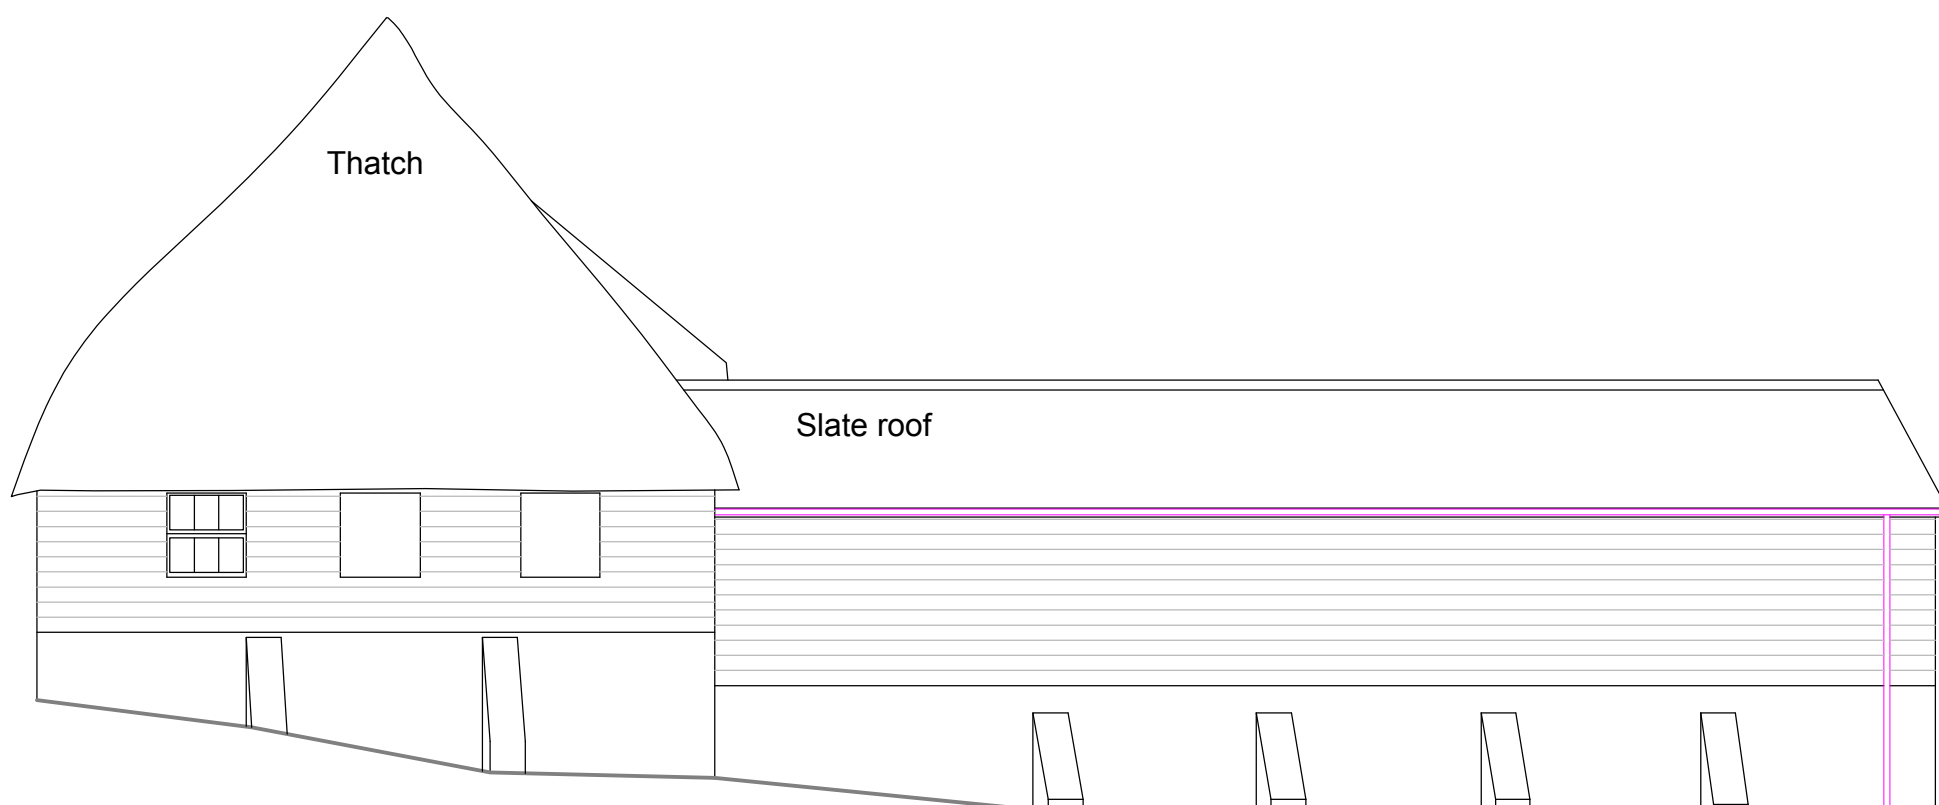


Existing west elevation 1:100

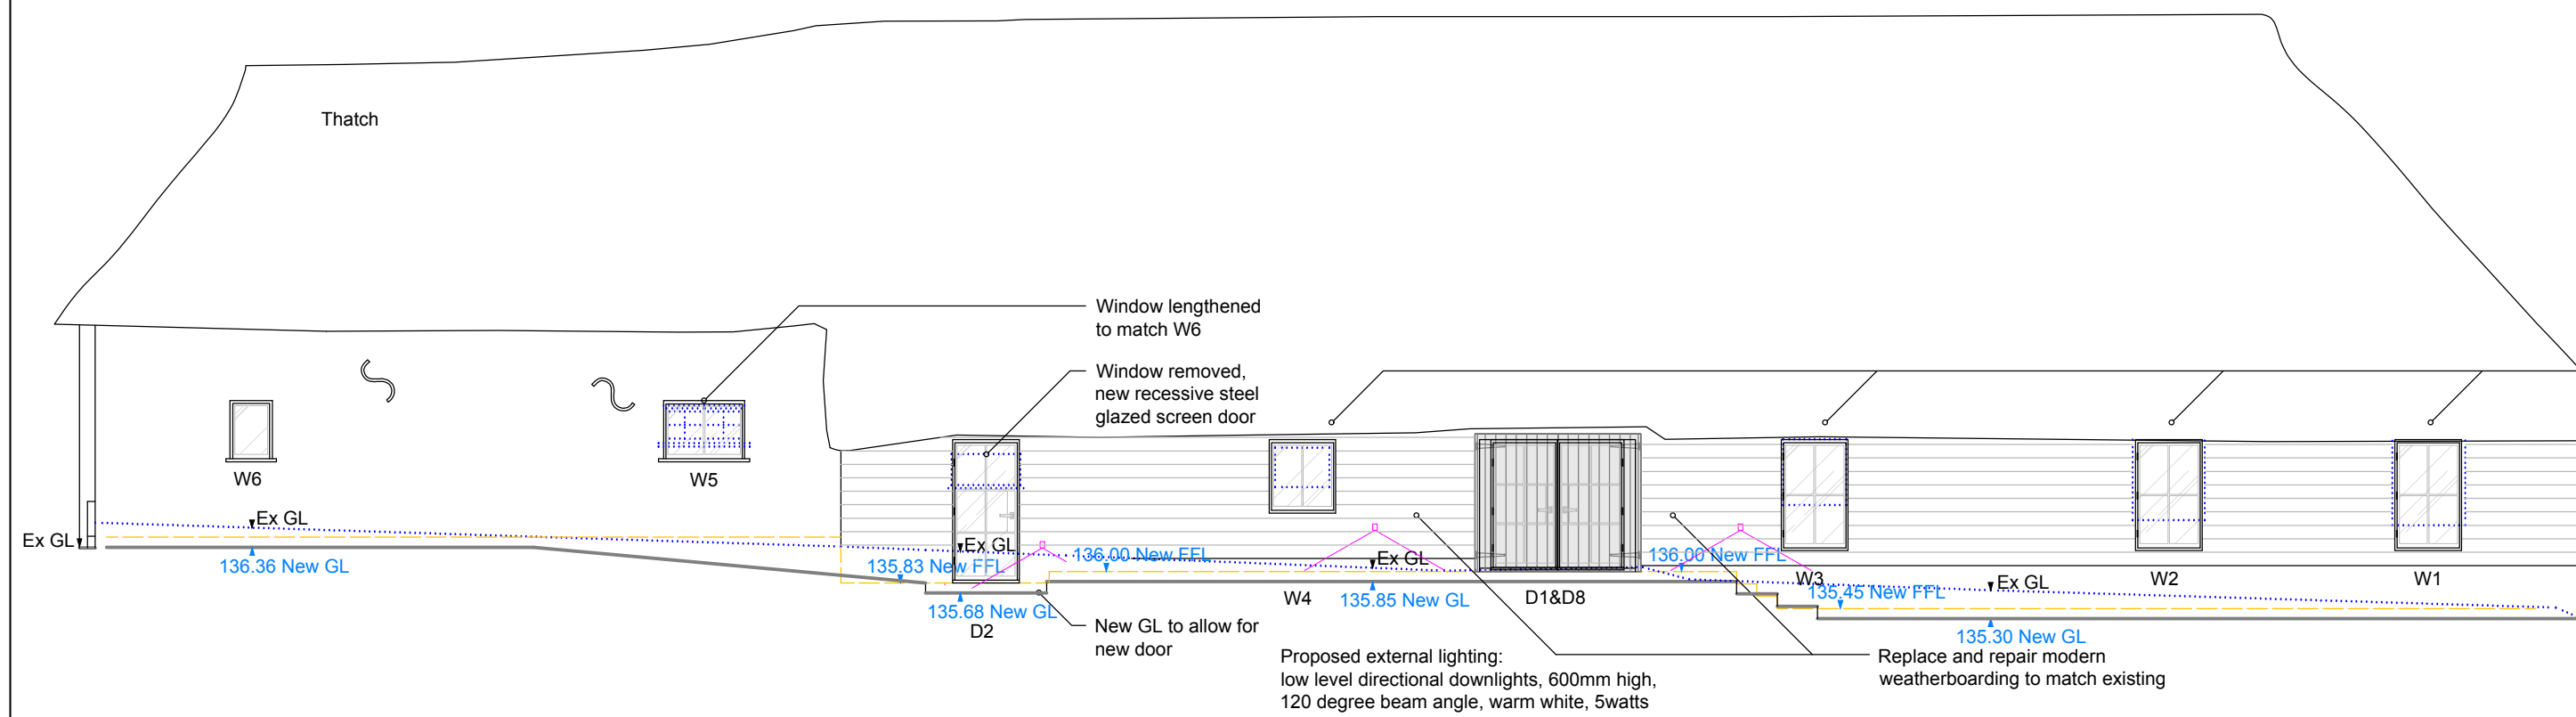


Proposed north elevation 1:100

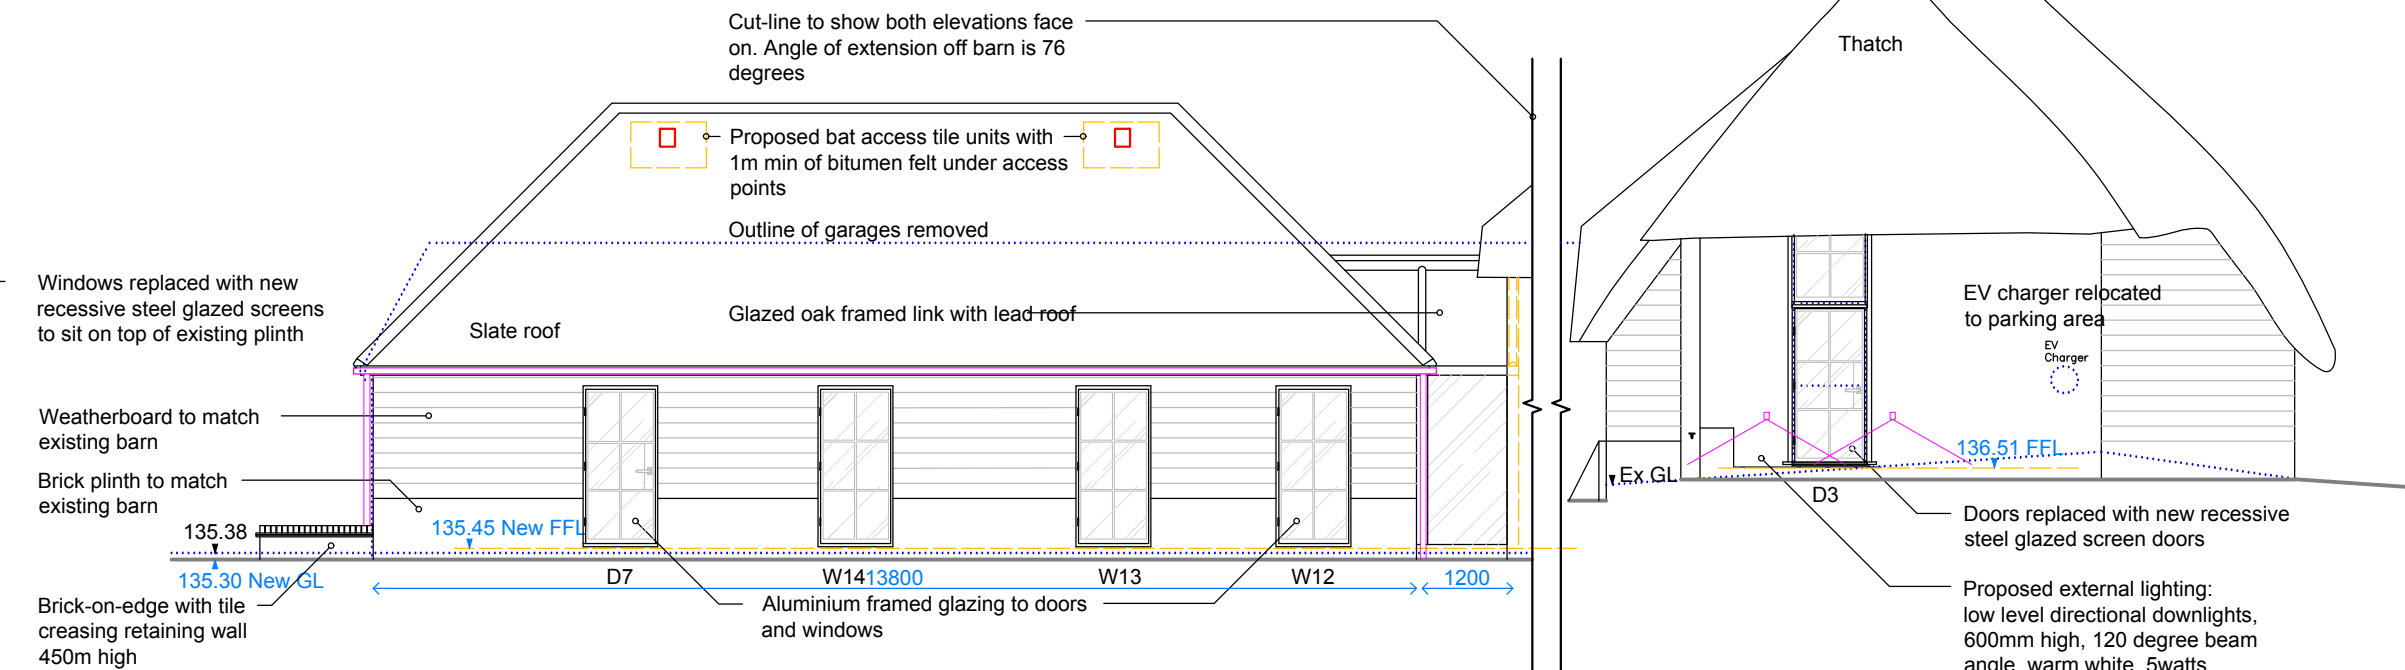


Proposed east elevation 1:100

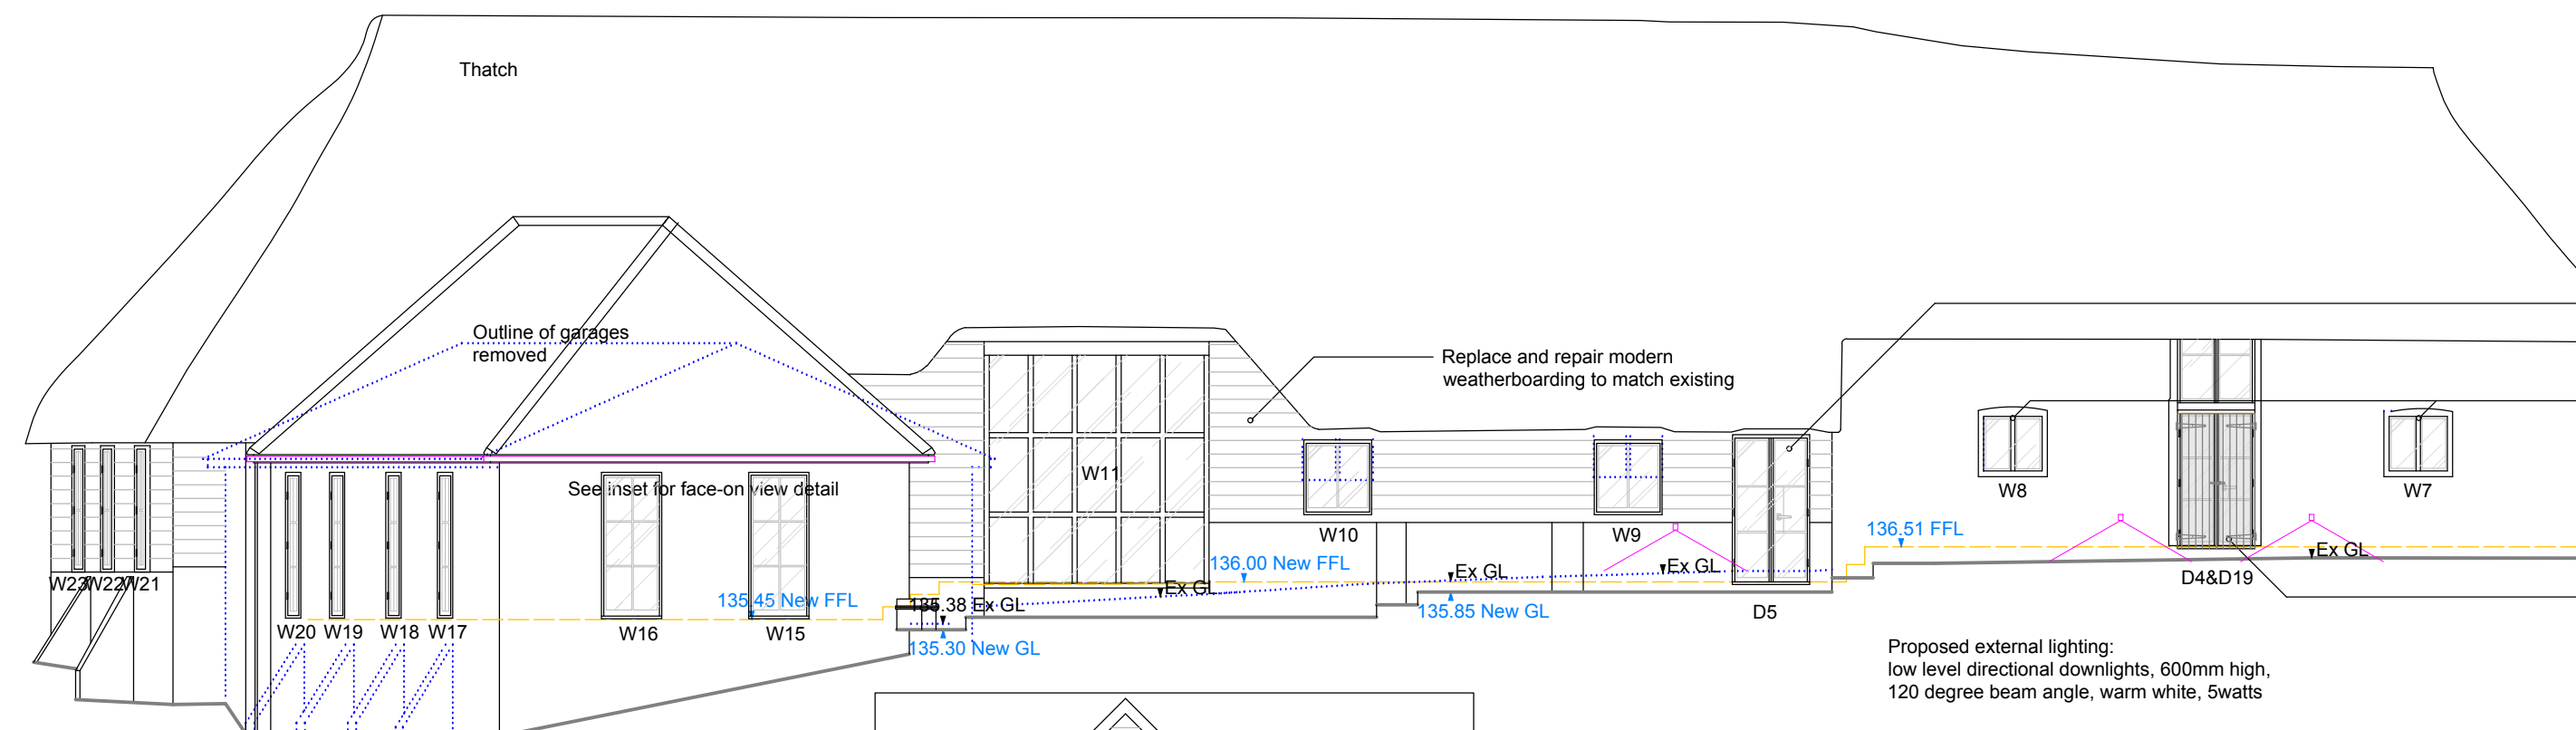


Proposed south elevation 1:100

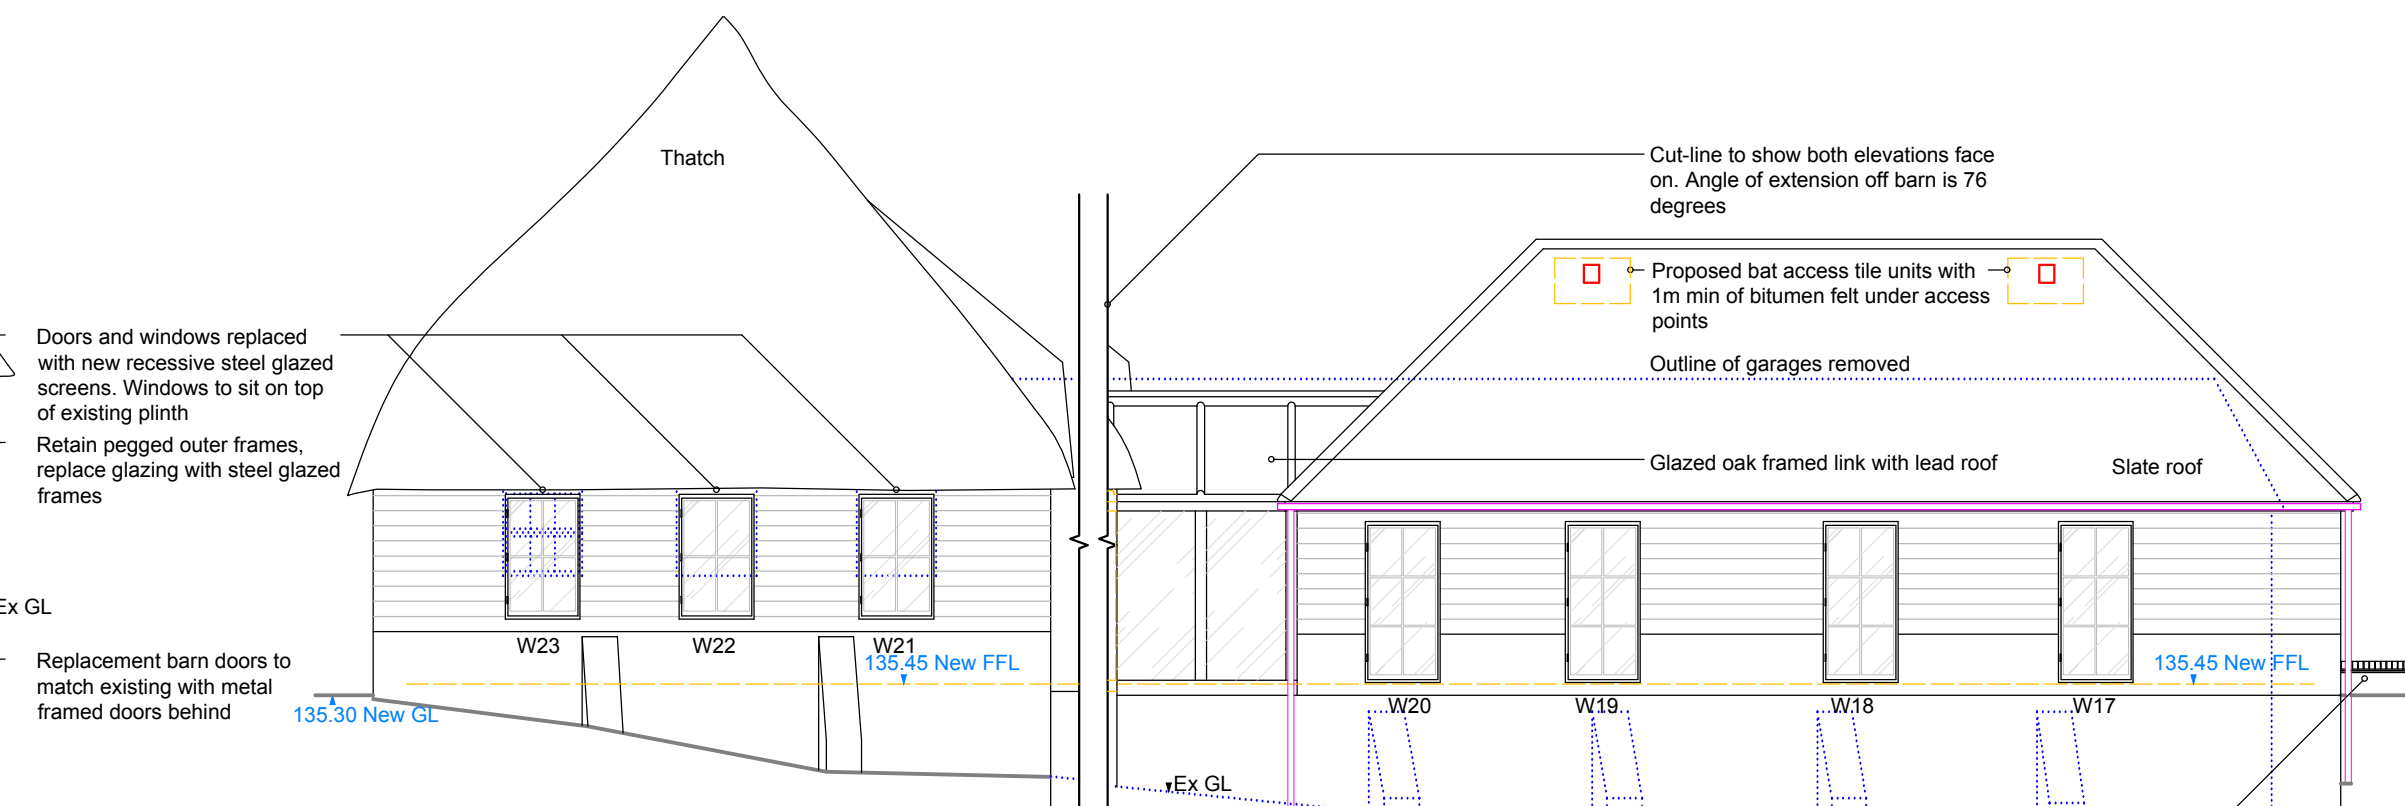

Proposed west elevation 1:100

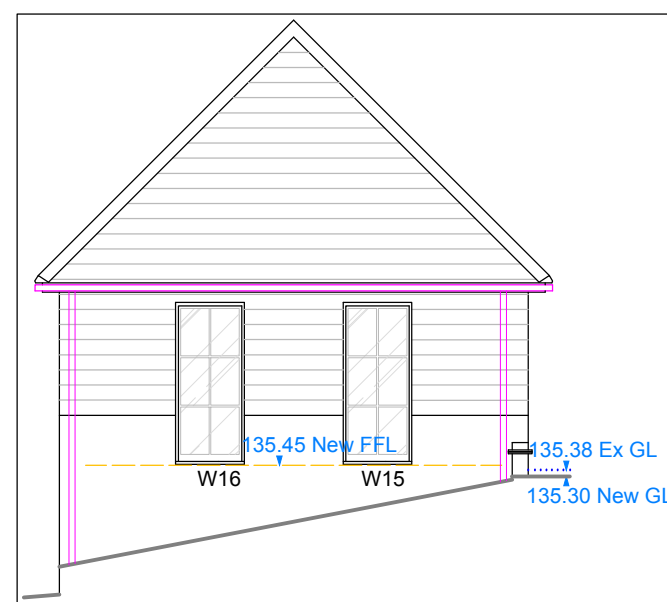

Proposed extension south elevation 1:100

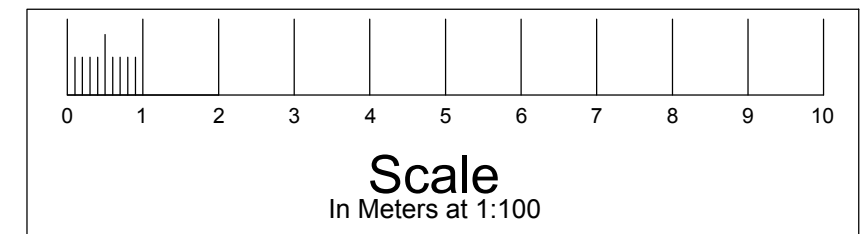

Do not scale from drawing, use figured dimensions only. Subject to site survey and all necessary consents. All dimensions to be checked by user and any discrepancies, errors or omissions to be reported to the Architect before work commences. This drawing is to be read in conjunction with other relevant documents.

REV	DESCRIPTION	DATE	AUTH
-	Issued for client review	180825	LR
A	Issued for client review	180925	LR
B	Issued for client review	171025	LR
C	Issued for pre-planning	111125	LR
D	Issued for review	300526	LR
E	Issued for Consultants' review and reports	290626	LR
F	Issued for client review	080726	LR
G	Issued for planning	210726	LR
H	Issued for planning	070826	LR

KEY	
	Boundary
	Area
	Elevation
	Finishes
	Groundline
	Landscaping
	New build
	Plan
	Engineer
	Overhead Hidden
	Removed
	Services existing runs
	Services fittings
	Services proposed runs
	Setting out
	Survey
	Tact
	Viewport
	Paneling
	Flat panel radiator
	Storage radiator
	Heating element
	Towel radiator
	Radiator in cabinet
	Storage heater
	13 amp double socket
	13 amp double socket countertop
	13 amp USB double socket
	5 amp lighting socket
	Switched spur
	Electric vehicle charge point
	Floor socket
	Rear socket
	External quality socket
	Lightswitch / Dimmer lightswitch
	Lightswitch 2-way / 3-way
	Lightswitch with timer
	5 amp lightswitch
	Pulcator lightswitch
	Overhead pendant light
	Wall light 1800 height
	External wall light
	Wall light low level 450 high
	LED light (directional) (wide angle)
	Directional spot light
	Star or pin light
	Intra red sensor Light
	Extrast lavaghe combination
	Flue or duct
	Strip light under cabinet/shelf
	Closest light and jamb switch
	Smoke / Heat detector (wired)
	Alarm sensor / PIR sensor
	Alarm panel / External alarm box
	Alarm keypad
	Speaker point wall or ceiling
	Remote control eye
	Cooler socket
	CCU/Fuseboard
	Meters gas and electricity
	Audio visual control panel
	Booster for vsm signal
	Air conditioning
	Underfloor heating manifold
	Heating timer control panel
	Telephone socket wired to services cdd
	CAT5 cables x2 wired to services cdd
	Television aerial socket wired to services cdd
	Cdd to aerial feed from roof
	Sty socket wired to services cdd to dish feed from roof
	TV position with socket at LL includes BT, CT, aerial and Sty points
	Standpipe
	Thermostat
	Doorbell / Doorbell sounder
	Culley
	Shower controls
	Insulation
	Floor to ceiling height
	Cill and window head heights
	Stair rise
	Joint run
	Service at high / low level

DRAWING ISSUE
Planning

LUKE ROSE
ARCHITECT
Beck Cottage, Abbots Ann
Hampshire SP11 7NW
tel: +44 (0) 1264 710163
email: info@lukerose.co.uk
www.lukerose.co.uk

Architecture | Construction | Design | Development

JOB
Barn at Shalbourne Manor
Kingston Road
Shalbourne SN8 3QD

TITLE
Existing and proposed
elevations

SCALE	DATE	AUTHOR
1:100	Jul 26	LR
DRAWING NO	REV	
25/436/102	H	