

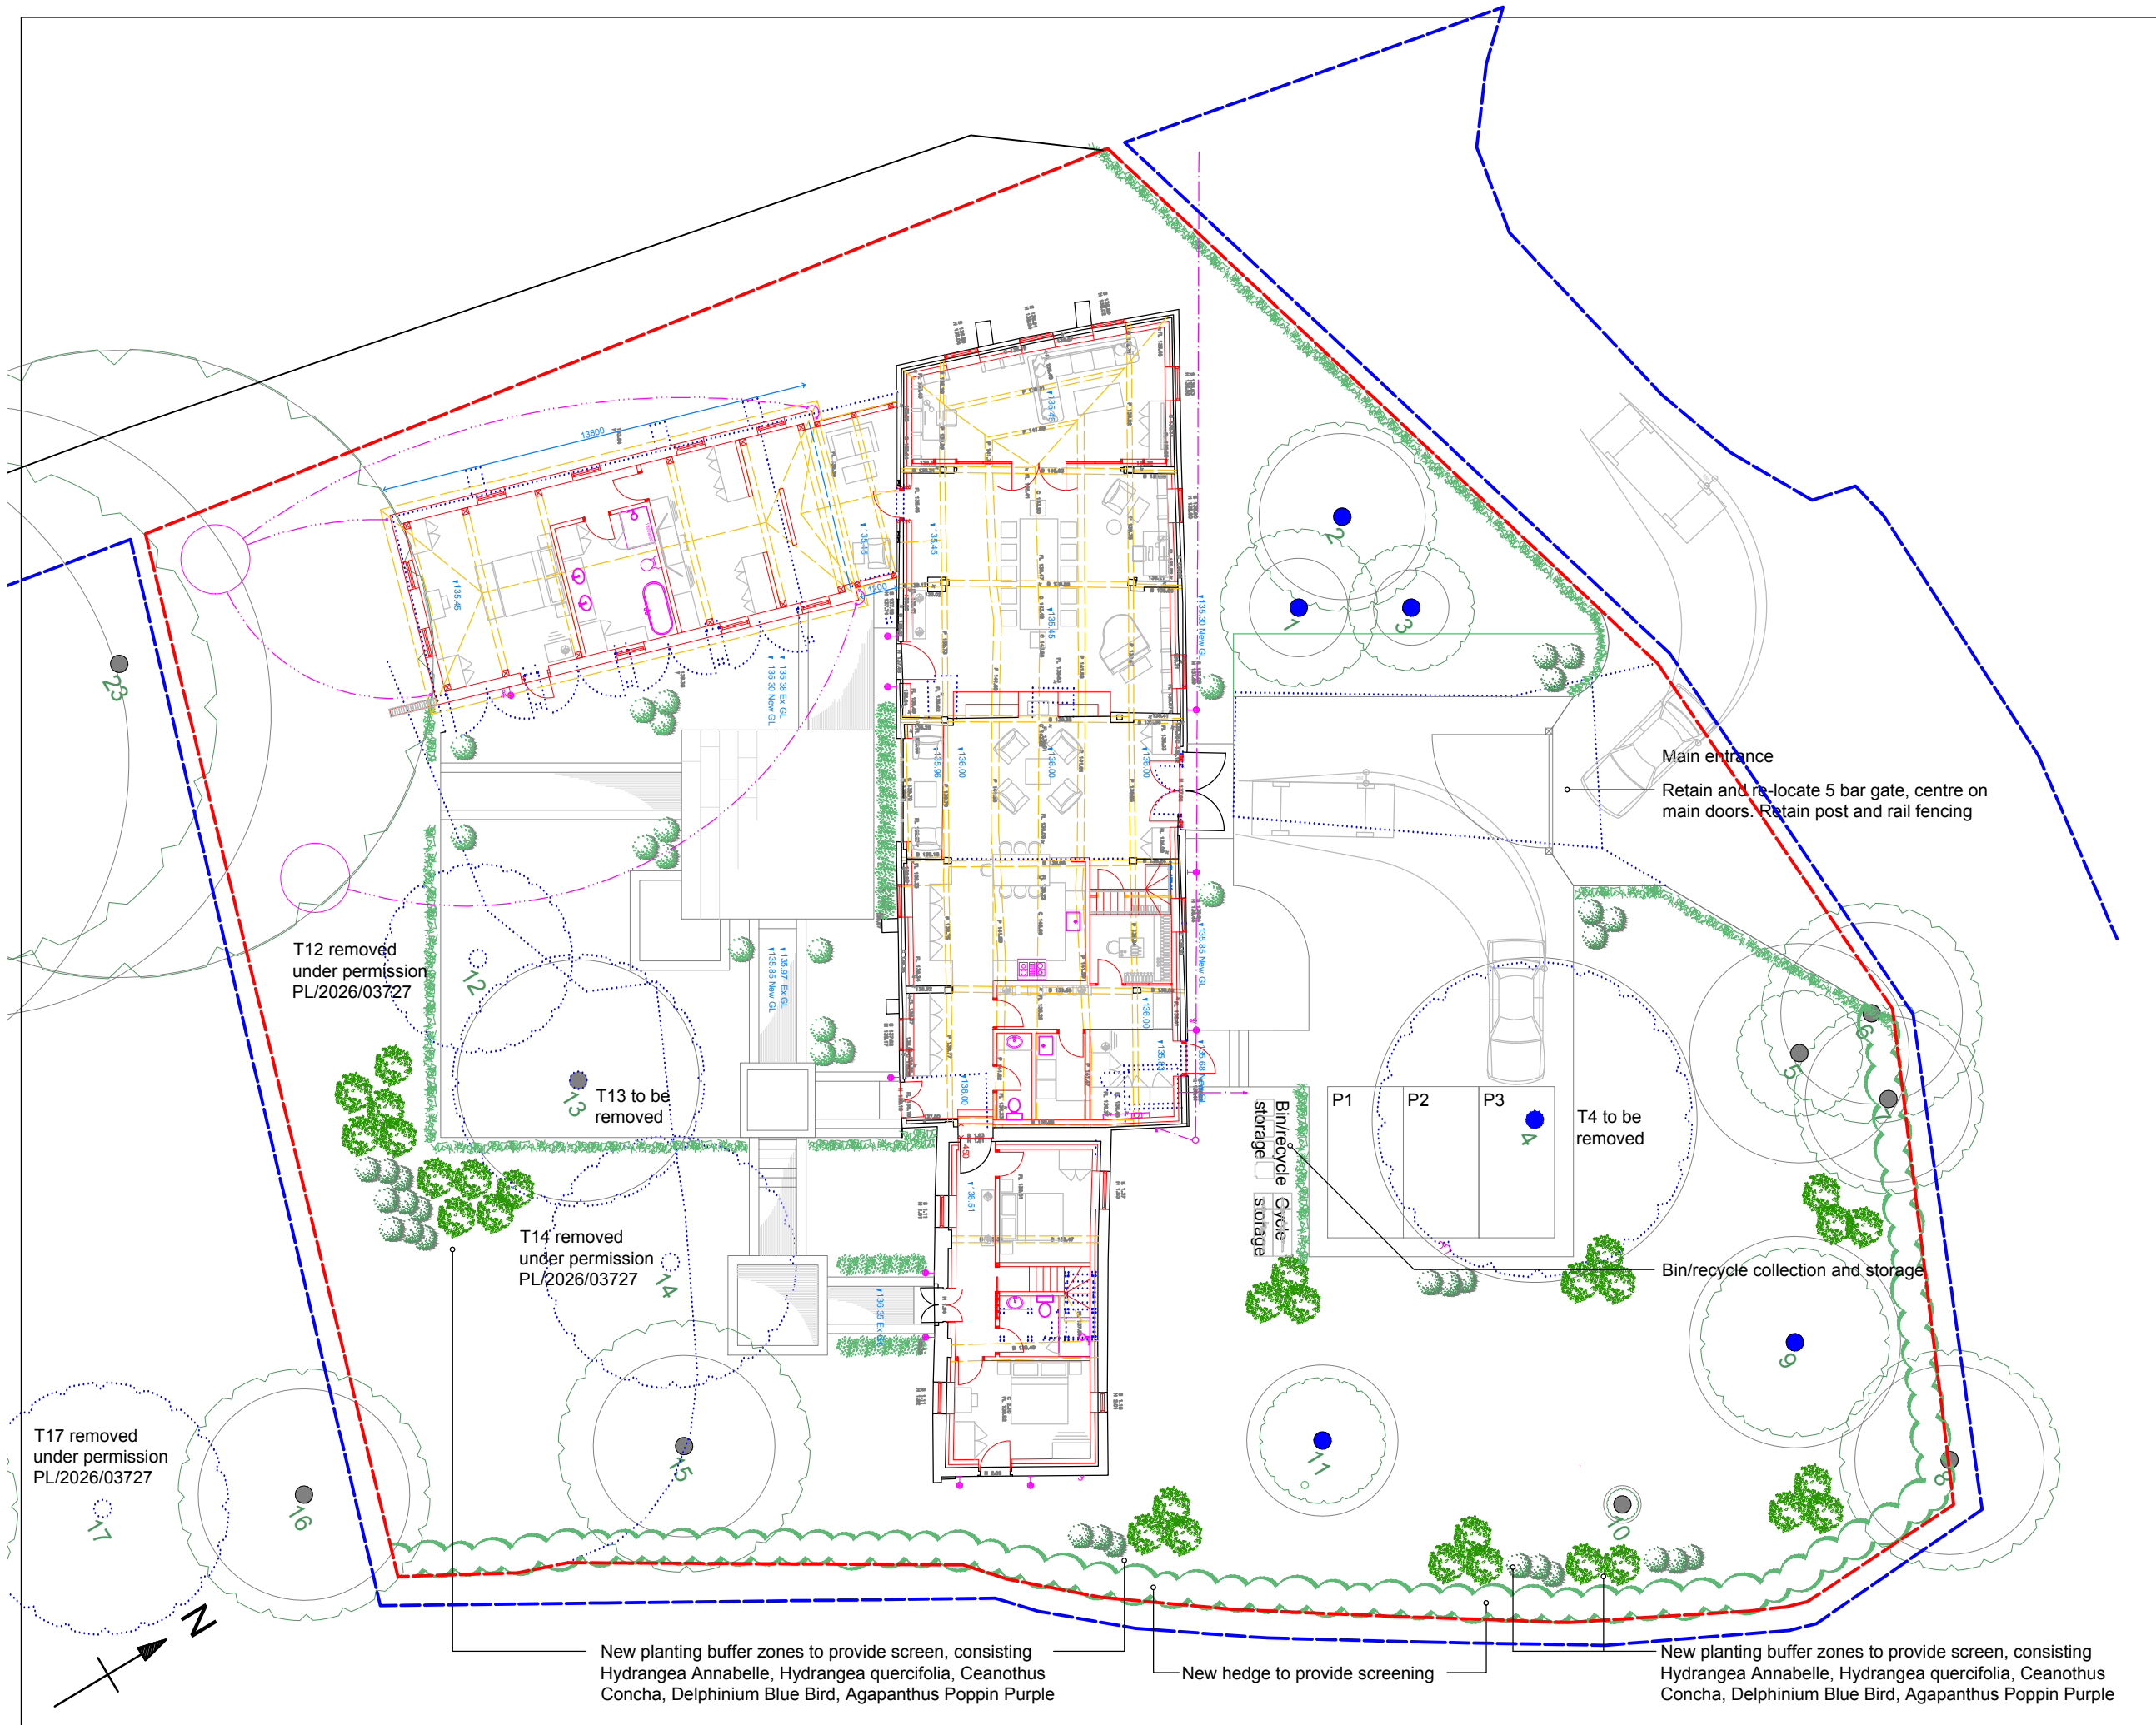
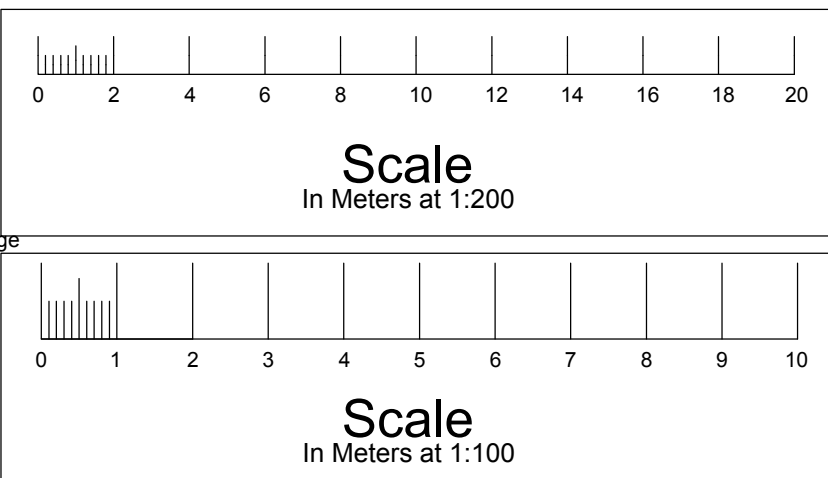


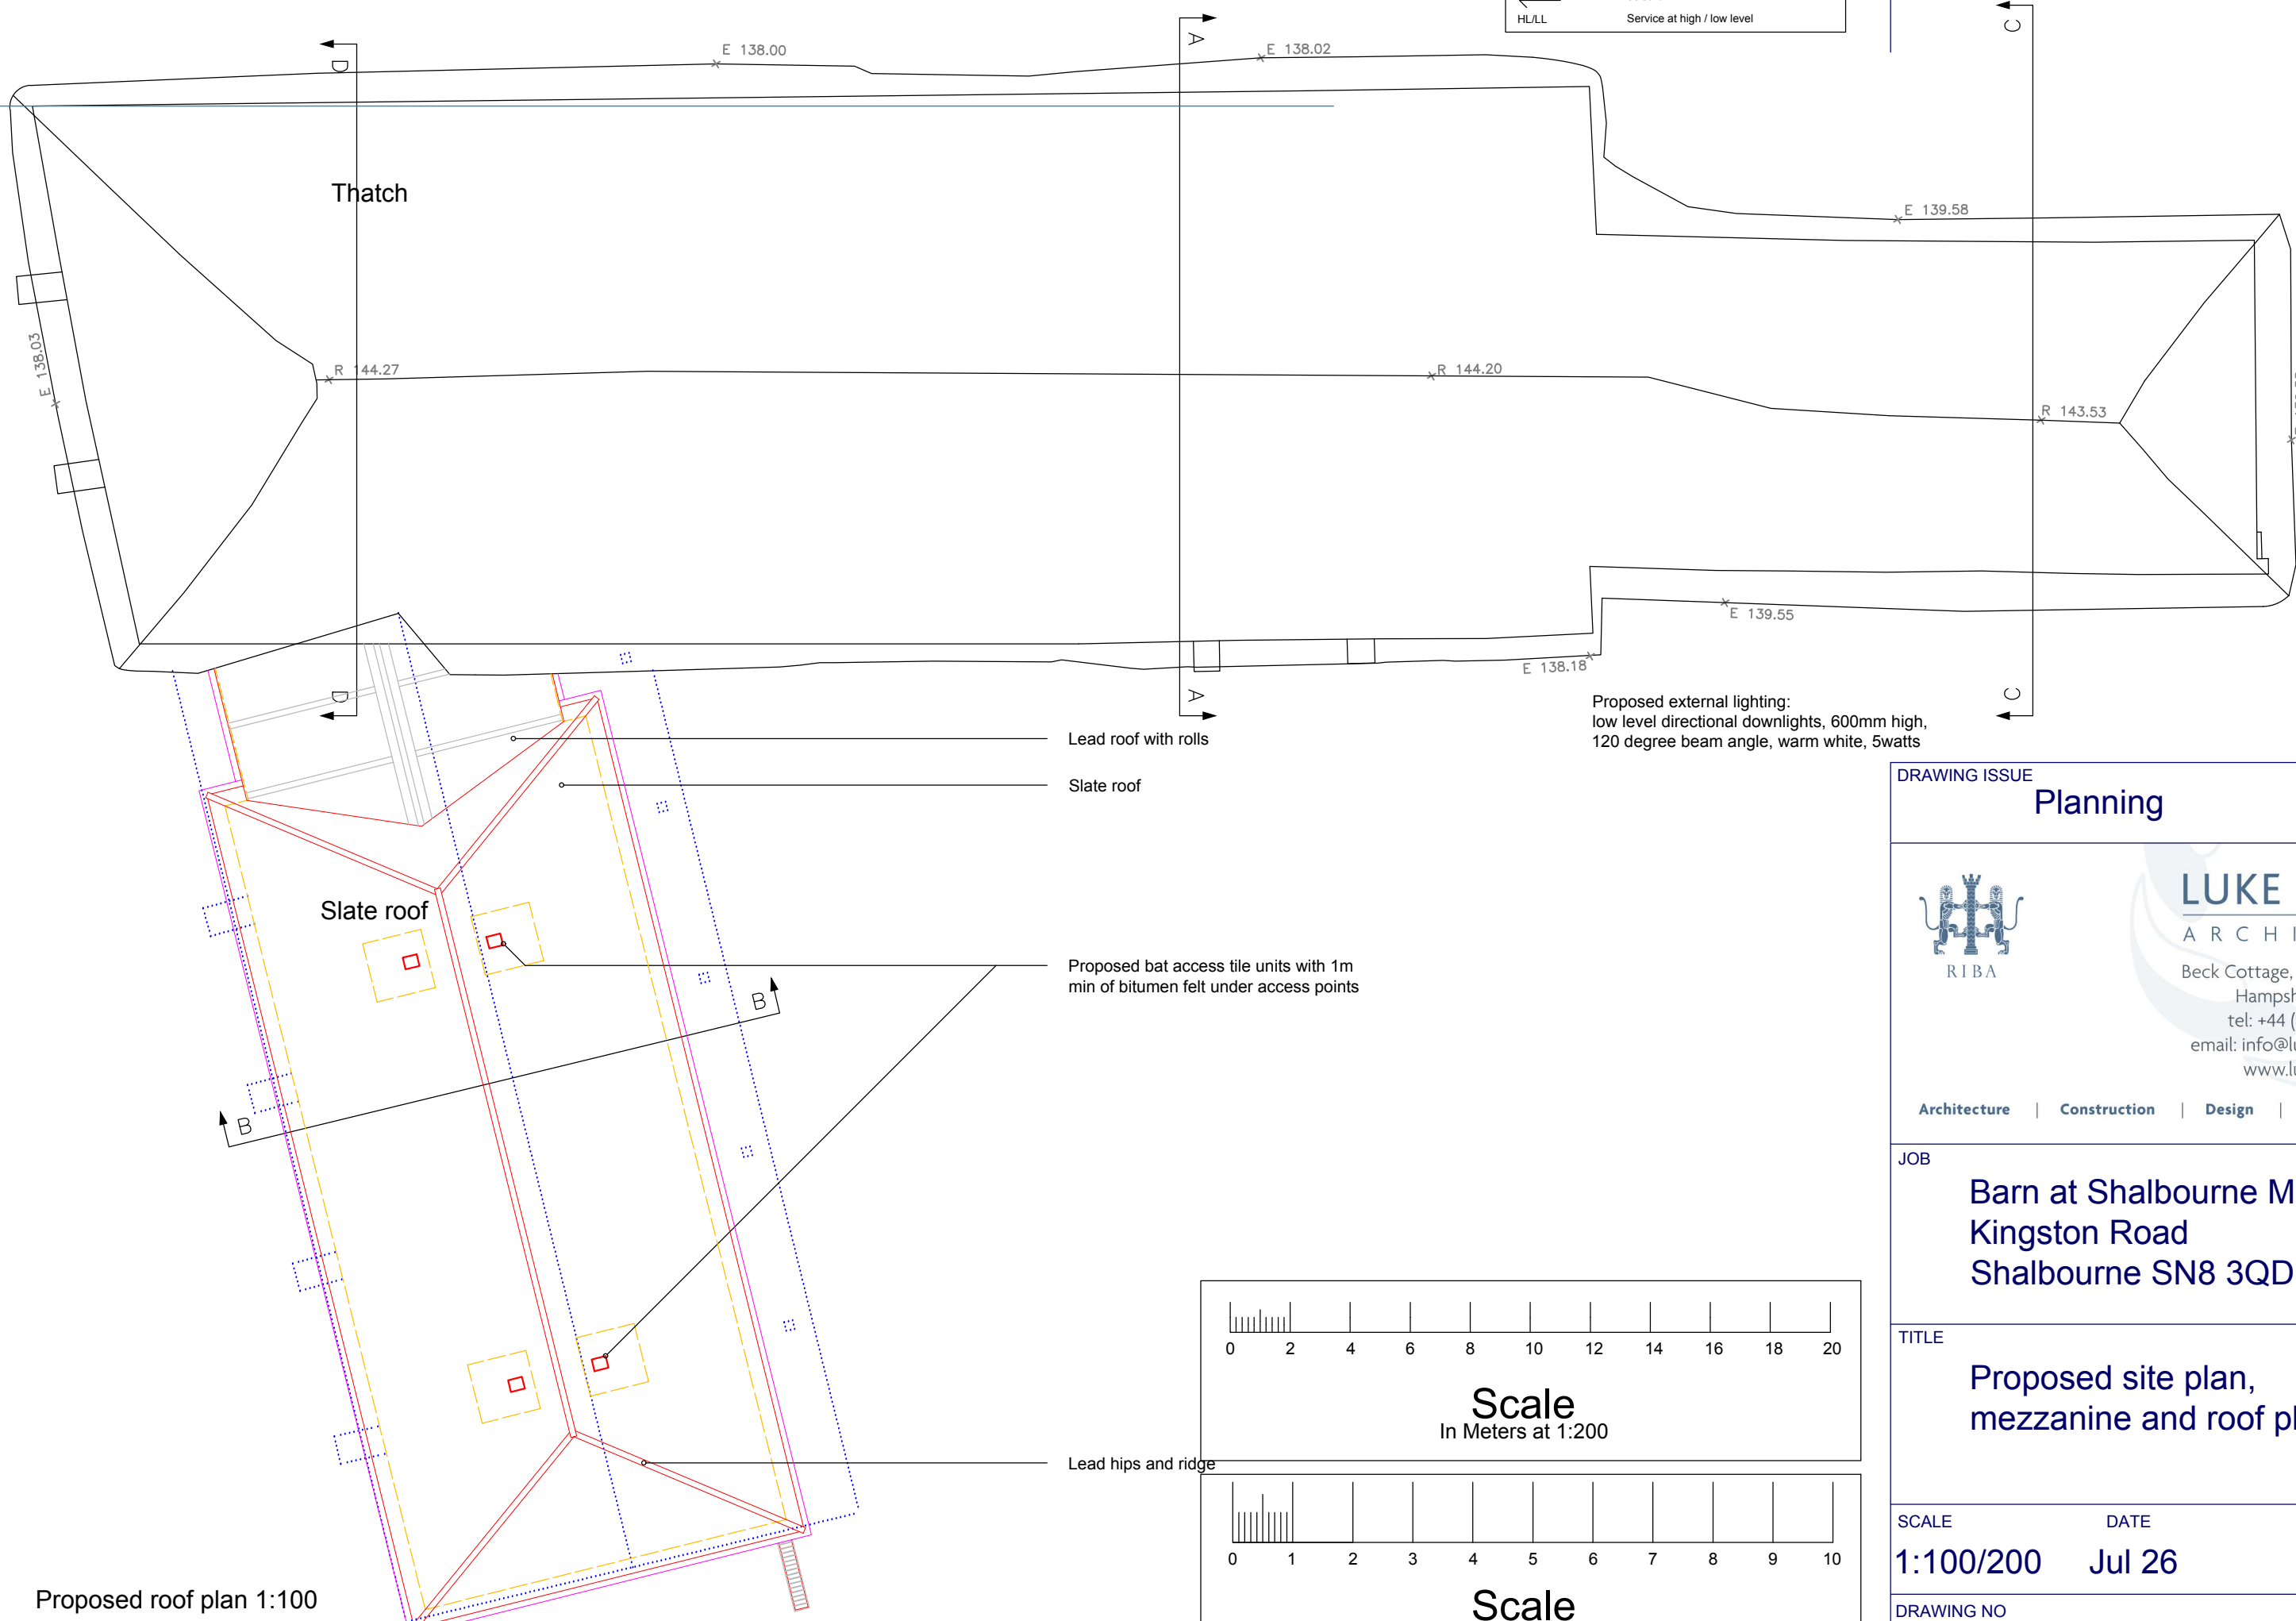

KEY	
[Symbol]	Boundary
[Symbol]	Area
[Symbol]	Elevation
[Symbol]	Finishes
[Symbol]	Groundline
[Symbol]	Landscaping
[Symbol]	New build
[Symbol]	Plan
[Symbol]	Overhead Hidden
[Symbol]	Overhead
[Symbol]	Removed
[Symbol]	Services existing runs
[Symbol]	Service fittings
[Symbol]	Services proposed runs
[Symbol]	Setting out
[Symbol]	Survey
[Symbol]	Text
[Symbol]	Viewpoint
[Symbol]	Paneling
[Symbol]	Flat panel radiator
[Symbol]	Storage heater
[Symbol]	13 amp double socket
[Symbol]	13 amp double socket countertop
[Symbol]	13 amp USB double socket
[Symbol]	5 amp lighting socket
[Symbol]	Switched spur
[Symbol]	Electric vehicle charge point
[Symbol]	Floor socket
[Symbol]	Recess socket
[Symbol]	External quality socket
[Symbol]	Lightswitch / Dimmer lightswitch
[Symbol]	Lightswitch 2-way / 3-way
[Symbol]	Lightswitch with timer
[Symbol]	5 amp lightswitch
[Symbol]	Pullcord lightswitch
[Symbol]	Overhead pendant light
[Symbol]	Wall light 1800 height
[Symbol]	External wall light
[Symbol]	Wall light low level 450 high
[Symbol]	LED light (directional) (wide angle)
[Symbol]	Directional spot light
[Symbol]	Star or pin light
[Symbol]	Intra red sensor Light
[Symbol]	Extract fanlight combination
[Symbol]	Fluo or dust
[Symbol]	Strip light under cabinets/shelf
[Symbol]	Closet light and jamb switch
[Symbol]	Smoke / Heat detector (wired)
[Symbol]	Alarm sensor / PIR sensor
[Symbol]	Alarm panel / External alarm box
[Symbol]	Alarm keypad
[Symbol]	Speaker point wall or ceiling
[Symbol]	Remote control eye
[Symbol]	Cooker socket
[Symbol]	CCLU/Loadboard
[Symbol]	Meters gas and electricity
[Symbol]	Audio visual control panel
[Symbol]	Booster for WIFI signal
[Symbol]	Air conditioning
[Symbol]	Underfloor heating manifold
[Symbol]	Heating timer control panel
[Symbol]	Telephone socket wired to services cdb
[Symbol]	CAT 5 cables x2 wired to services cdb
[Symbol]	Television aerial socket wired to services cdb to aerial feed from roof
[Symbol]	Bay socket wired to services cdb to dish feed from roof
[Symbol]	TV position with socket at LL includes BT, DT, aerial and Sky points
[Symbol]	Standpipe
[Symbol]	Thermostat
[Symbol]	Doorbell / Doorbell sounder
[Symbol]	Gully
[Symbol]	Shower controls
[Symbol]	Insulation
[Symbol]	Floor to ceiling height
[Symbol]	Cit and window head heights
[Symbol]	Up
[Symbol]	Stair rise
[Symbol]	Joist run
[Symbol]	Service at high / low level

Do not scale from drawing, use figured dimensions only. Subject to site survey and all necessary consents. All dimensions to be checked by user and any discrepancies, errors or omissions to be reported to the Architect before work commences. This drawing is to be read in conjunction with other relevant documents.			
REV	DESCRIPTION	DATE	AUTH
-	Issued for client review	180825	LR
A	Issued for client review	180925	LR
B	Issued for client review	171025	LR
C	Issued for pre-planning	111125	LR
D	Issued for review	300526	LR
E	Issued for Consultants' review and reports	290626	LR
F	Issued for client review	080726	LR
G	Issued for planning	210726	LR
H	Issued for planning	070826	LR

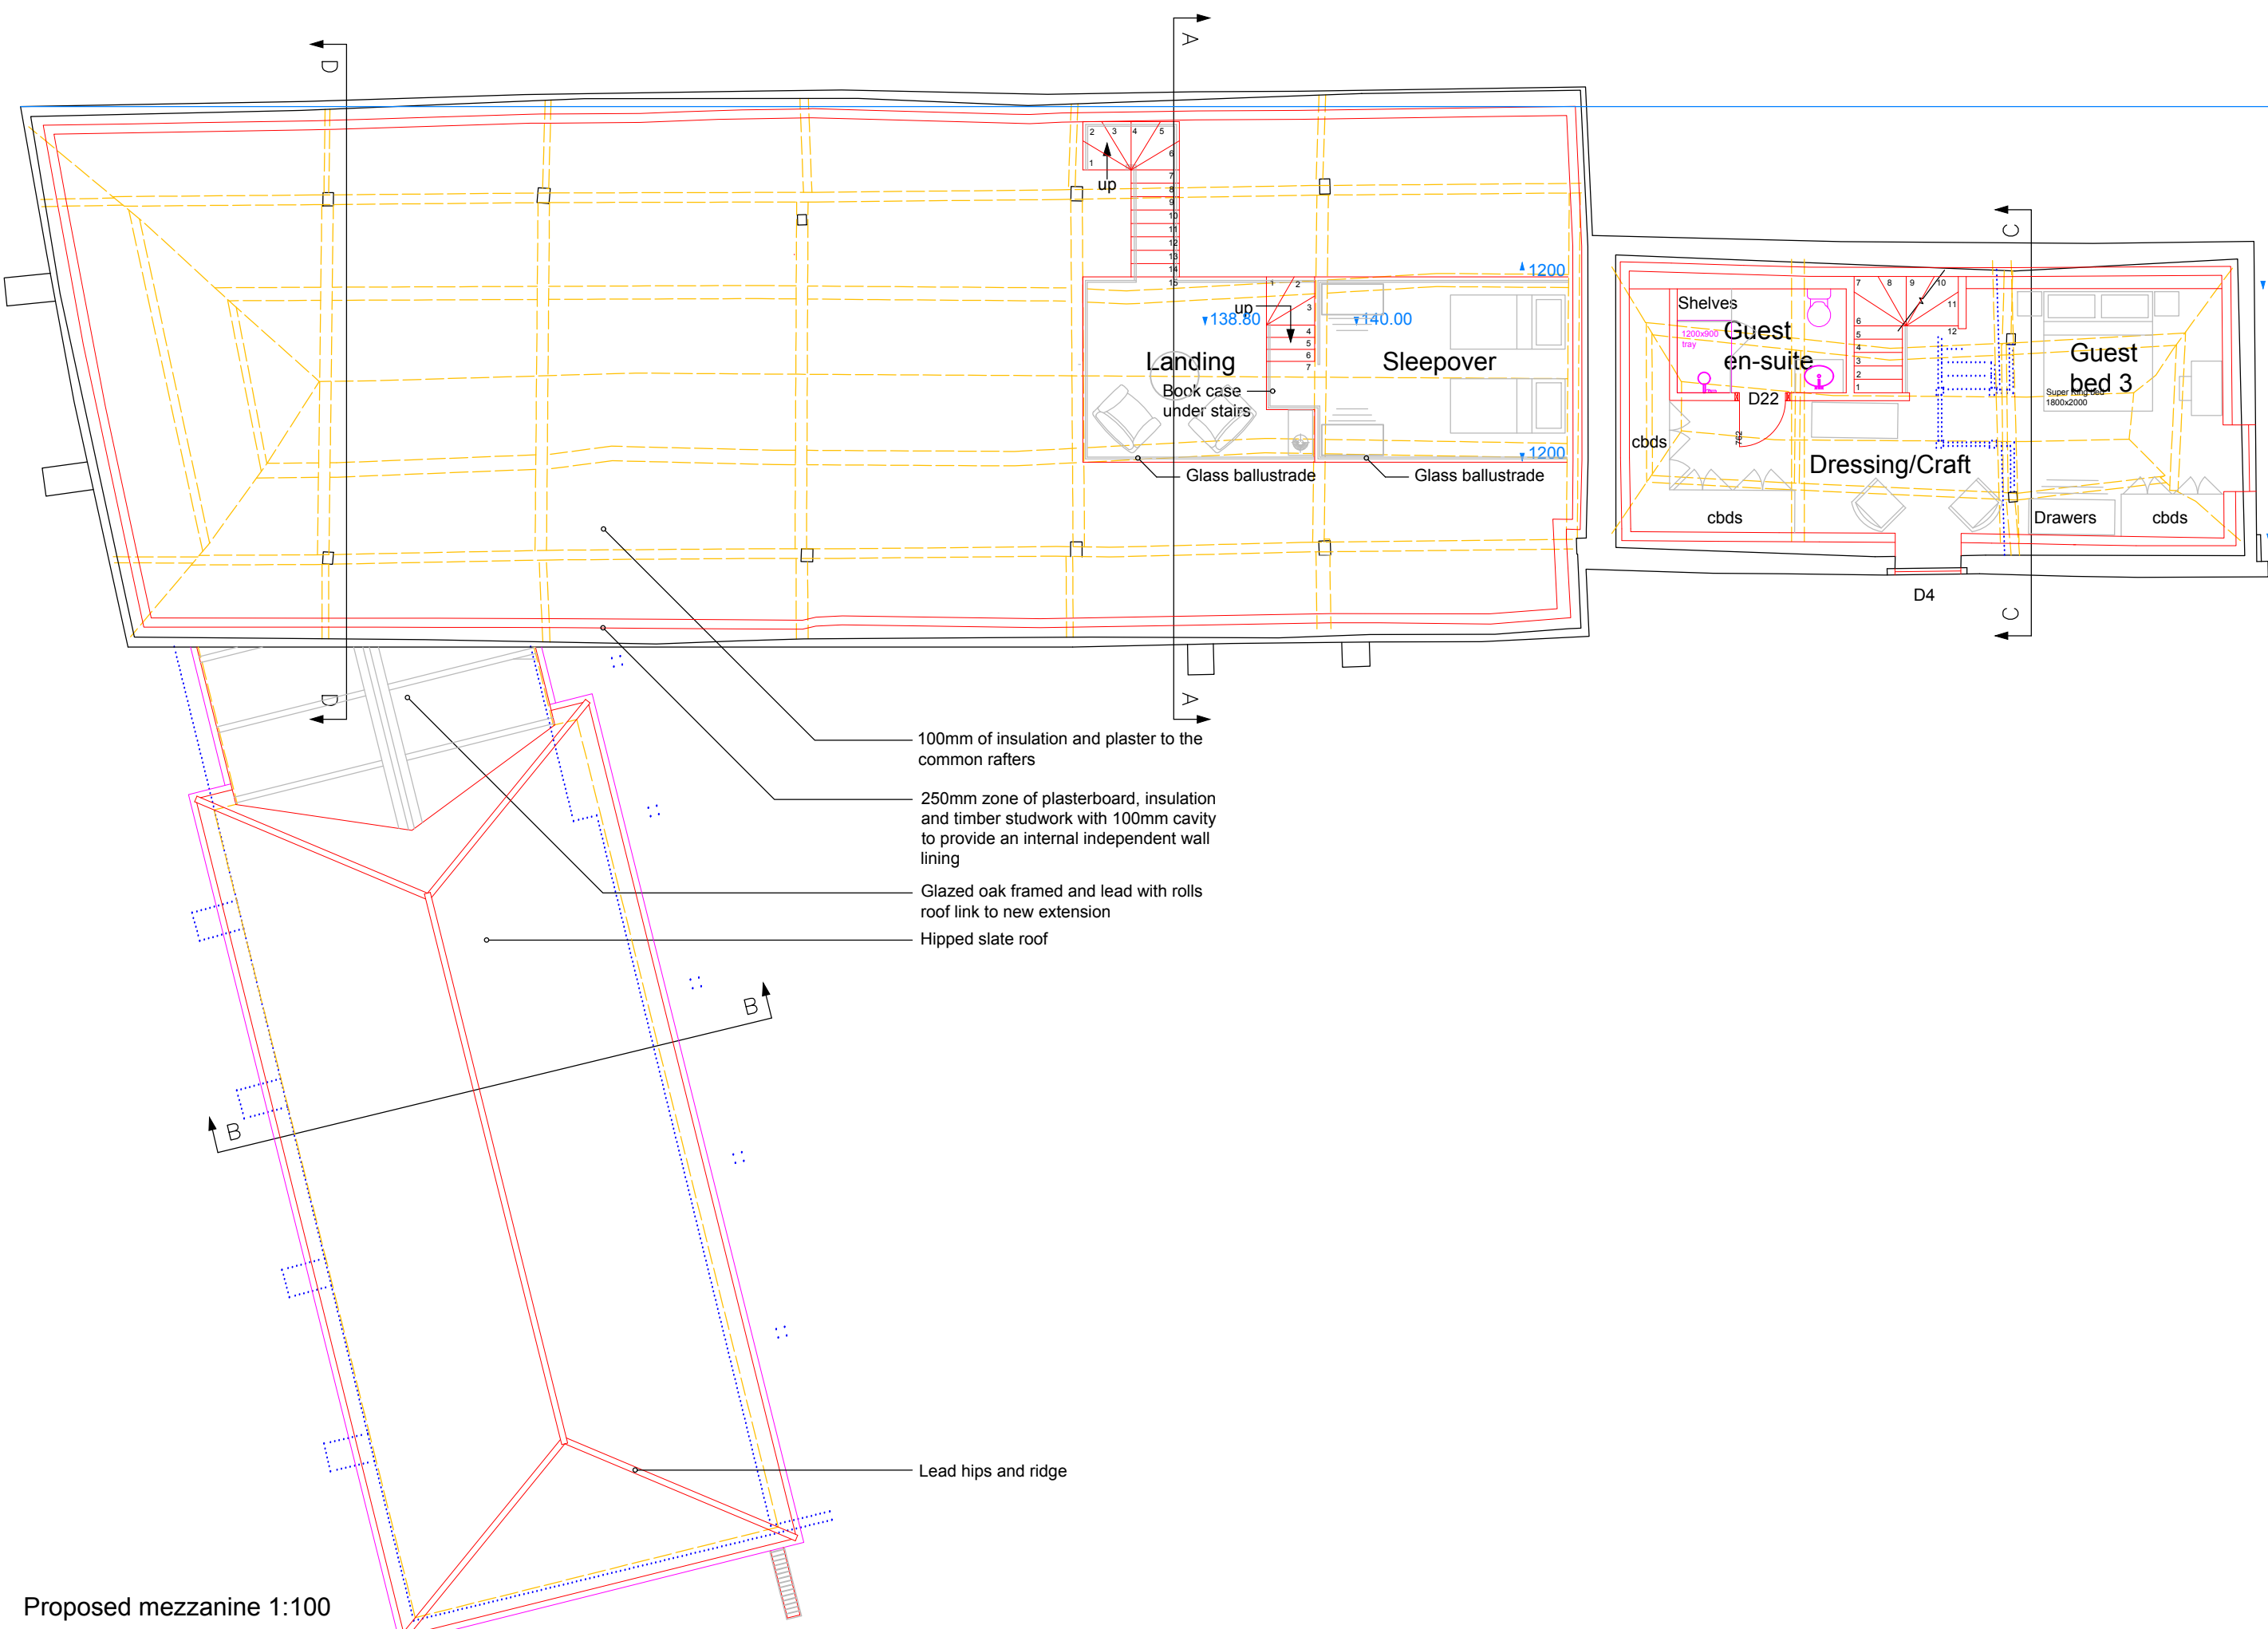

DRAWING ISSUE

Planning

Beck Cottage, Abbots Ann
Hampshire SP11 7NW
tel: +44 (0) 1264 710163
email: info@lukerose.co.uk
www.lukerose.co.uk

Architecture | Construction | Design | Development

JOB

Barn at Shalbourne Manor
Kingston Road
Shalbourne SN8 3QD

TITLE

Proposed site plan,
mezzanine and roof plans

SCALE	DATE	AUTHOR
1:100/200	Jul 26	LR
DRAWING NO	REV	
25/436/104	H	